

	REDLEONARD ASSOCIATES		
1340 Kemper Meadow Dr, Forest Park, OH 45240			

513-574-9500 | redleonard.com

R1	DAR	5/21/25	RE
		•	

# DESCRIPTION EVISED PER UPDATED BASE PLAN, RELOCATED AREA LIGHTS TO AVOID UTILITY CONFLICTS

ANY SITE PLAN(S), FLOOR PLAN(S), RENDERING(S), LIGHTING LAYOUT(S) AND PHOTOMETRIC PLAN(S) INCLUDING BUT NOT LIMITED TO ANY PROJECT(S) CREATED/PRODUCED BY RED LEONARD ASSOCIATES INC., ARE ONLY INTENDED FOR ILLUSTRATION AND QUOTING PURPOSES ONLY. RED LEONARD ASSOCIATES HAS THE RIGHT TO USE THIRD PARTY LASERS, SCANNERS, AND CAMERAS BUT ACTUAL PROJECT CONDITIONS, DIMENSIONS, AND ACCURACY OF MEASUREMENTS MAY DIFFER FROM THESE OR ANY PARAMETERS. RED LEONARD ASSOCIATES INC. ASSUMES NO LIABILITY FOR WHAT IS CREATED/PRODUCED IN THESE RECREATIONS. THIS INCLUDES BUT IS NOT LIMITED TO THE USE OF, INSTALLATION OF AND/OR INTEGRITY OF EXISTING BUILDING(S), SURROUNDING AREA FOR PRODUCT(S) SUCH AS EXISTING POLE(S), ANCHOR BOLT(S), BASE(S), ARCHITECTURAL AND SIGNAGE STRUCTURE(S), LANDSCAPING PLAN(S), LIGHTING PLAN(S), FIXTURE SELECTION(S) AND PLACEMENT, MATERIAL(S), COLOR ACCURACY, TEXTURE(S), AND ANYTHING ATTRIBUTED TO PHOTO REALISM THAT IS CREATED. FURTHERMORE, RED LEONARD ASSOCIATES INC., DOES NOT ASSUME LIABILITY WHATSOEVER FOR ANY PURCHASES MADE BY CLIENT BEFORE, DURING, OR AT THE CONCLUSION OF THE PUBLISHED WORK. THE CUSTOMER, ITS RELATIVE AFFILIATES, AS WELL AS ANY OTHER PERSON(S) IN VIEWING OF THIS PRODUCT IS RESPONSIBLE FOR VERIFYING COMPLIANCE WITH NOT LIMITED TO ALL CODES, PERMITS, RESTRICTIONS, INSTRUCTIONS, PURCHASES, AND INSTALLATIONS OF OBJECTS VIEWED WITHIN THIS DOCUMENT(S) OR PROJECT(S). SYMBOLS ARE NOT DRAWN TO SCALE. SIZE IS FOR CLARITY PURPOSES ONLY. SIZES AND DIMENSIONS ARE APPROXIMATE, ACTUAL MEASUREMENTS MAY VARY. DRAWINGS ARE NOT INTENDED FOR ENGINEERING OR CONSTRUCTION USE. THIS DOCUMENT, ANY RED LEONARD DRAWING(S), OR PROJECT(S) IS NOT TO BE USED AND/OR INTENDED FOR ENGINEERING OR CONSTRUCTION USE. THIS DOCUMENT, ANY RED LEONARD DRAWING(S), OR PROJECT(S) IS NOT TO BE USED AND/OR INTENDED FOR ENGINEERING OR CONSTRUCTION DURPOSES, BUT FOR ILLUSTRATIVE PURPOSES ONLY. ANY LOCATIONS OF EMERGENCY LIGHTING SHOWN WERE PROVIDED BY OTHERS. RED LEONARD ASSOCIATES IS NOT RESPONSIBLE FOR INSUFFICIENT LIGHTING DURING

 
ANY USE OF THIS DOCUMENTATION AND/OR OTHER ARTICLES PRODUCED BY RED LEONARD WITHOUT WRITTEN AUTHORIZATION FROM JAYME J. LEONARD IS STRICTLY PROHIBITED.

SCALE:	LAYOUT BY:
1" = 30'	DAR
DWG SIZE:	DATE:
D	4/16/25

SHEETZ #416
ZEBULON, NC
DRAWING NUMBER:
RL-10222-S1-R1











ADDITIONAL FIXTURE INFO

Width:

Weight





ADDITIONAL FIXTURE INFO

### ORDX4 Open Rated Exterior Downlight Features and Specs Integral LED driver included, 120-277V. · Cast aluminum top housing with integral driver. Dust and water tight (IP66) sealed optical chamber. Primary wiring compartment with power supply. · Die-cast aluminum trim and faceplate. · Standard driver supports (4) different dimming protocols - Stainless steel hardware. TRIAC/ELV/0-10V/PWM. Dimming percentage less than 1% - All dimming methods. · Architectural Grade Polyester Powder Coat. Swing out pressure fit stainless steel mounting clips. Adjustable from 0.07" to 1.25" ceiling thickness. • Beam Spread: 15°, 24°, 36° · CCT: 2700K, 3000K, 4000K CRI: 80 or 90+ typ Polycarbonate TIR optic with white backing for maximum efficacy. • Estimated 50,000+ hour LED lifespan based on IES LM-80 results and TM-21 calculations. Performance Data (with Medium beam) UL listed for wet locations (suitable for use in open or uncovered applications) Assembled in the USA 5 year limited warranty COATED TOUGH 4000K/90+ Ordering Information 3 4 5 4 Beam Spread 5 Finish

N narrow 24°

**40** 4000K/80 CRI **M** medium 36°

SLV silver

BRZ bronze

CSTM-RB custom

amerlux

30 3000K/80 CRI

279 2700K/90+ CRI

309 3000K/90+CRI


merlux reserves the right to change details that do not affect overall function and performance.

LIT-E0202 • 02/14/25 • Page 1 of 1


Amerlux®, LLC •178 Bauer Drive, Oakland, NJ 07436 • P: 973-882-5010 F: 973-882-2605 • amerlux.com

409 4000K/90+ CRI



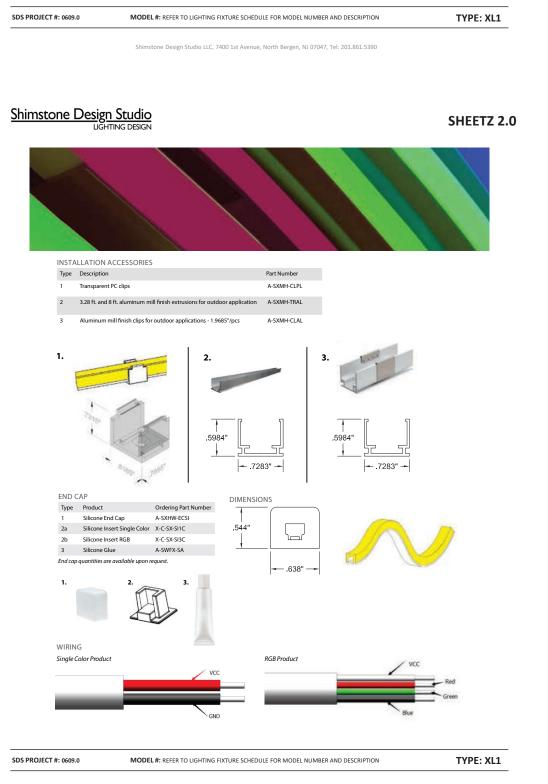

Shimstone Design Studio LLC, 7400 1st Avenue, North Bergen, NJ 07047, Tel: 201.861.5390

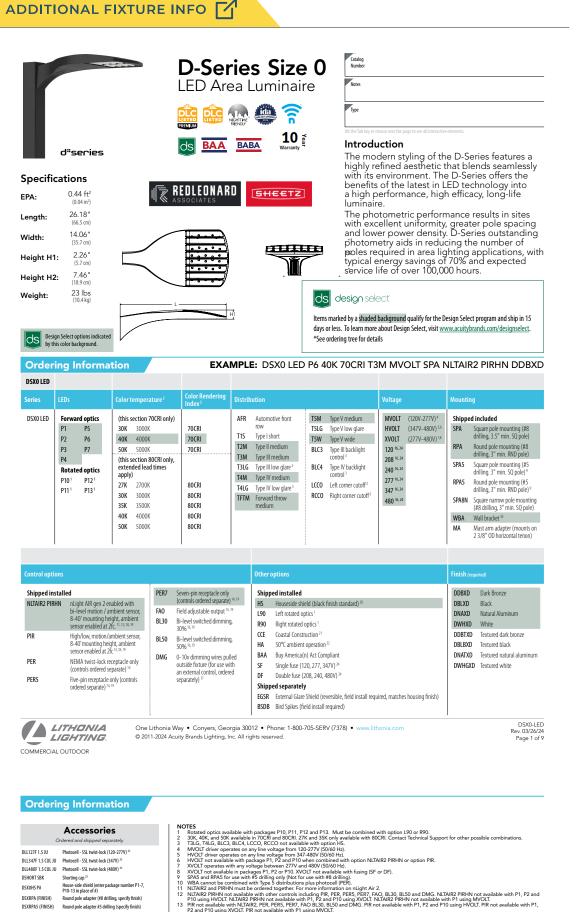


DSXSPA5 (FINISH) Square pole adapter #5 drilling (specify finish)

External Glare Shield (EGSR)





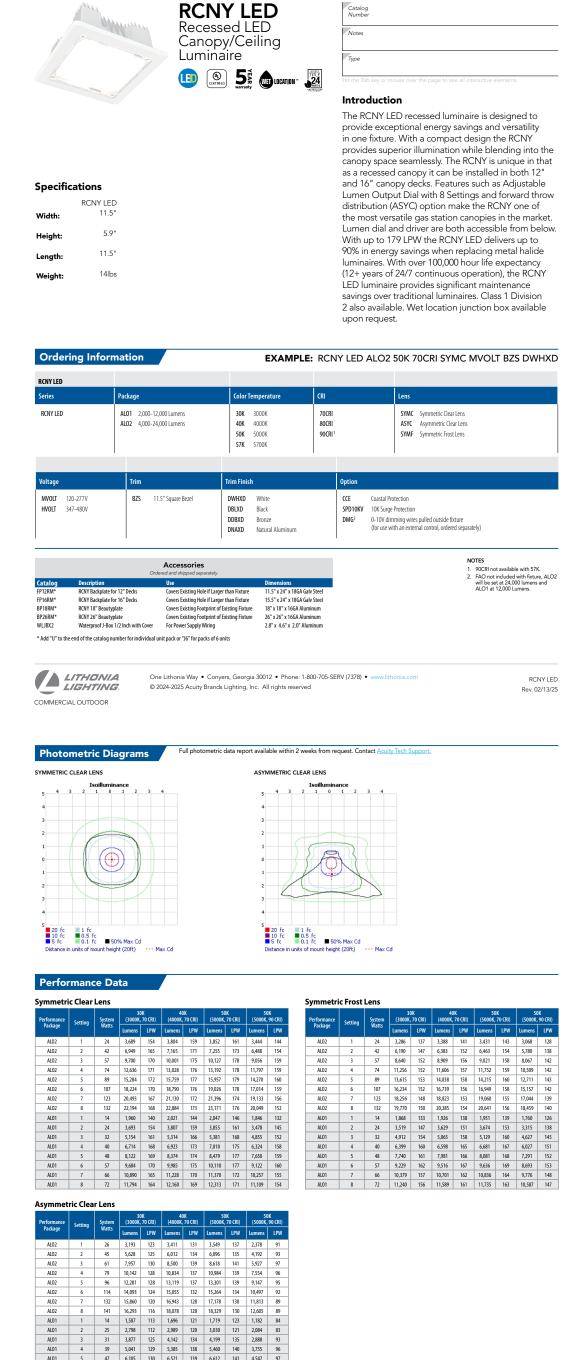



ANY SITE PLAN(S), FLOOR PLAN(S), RENDERING(S), LIGHTING LAYOUT(S) AND PHOTOMETRIC PLAN(S) INCLUDING BUT NOT LIMITED TO ANY PROJECT(S) CREATED/PRODUCED BY RED LEONARD ASSOCIATES INC., ARE ONLY INTENDED FOR ILLUSTRATION AND QUOTING PURPOSES ONLY. RED LEONARD ASSOCIATES HAS THE RIGHT TO USE THIRD PARTY LASERS, SCANNERS, AND CAMERAS BUT ACTUAL PROJECT CONDITIONS, DIMENSIONS, AND ACCURACY OF MEASUREMENTS MAY DIFFER FROM THESE OR ANY PARAMETERS. RED LEONARD ASSOCIATES INC. ASSUMES NO LIABILITY FOR WHAT IS CREATED/PRODUCED IN THESE RECREATIONS. THIS INCLUDES BUT IS NOT LIMITED TO THE USE OF, INSTALLATION OF AND/OR INTEGRITY OF EXISTING BUILDING(S), SURROUNDING AREA FOR PRODUCT(S) SUCH AS EXISTING POLE(S), ANCHOR BOLT(S), BASE(S), ARCHITECTURAL AND SIGNAGE STRUCTURE(S), LANDSCAPING PLAN(S), LIGHTING PLAN(S), FIXTURE SELECTION(S) AND PLACEMENT, MATERIAL(S), COLOR ACCURACY, TEXTURE(S), AND ANYTHING ATTRIBUTED TO PHOTO REALISM THAT IS CREATED, FURTHERMORE, RED LEONARD ASSOCIATES INC., DOES NOT ASSUME LIABILITY WHATSOEVER FOR ANY PURCHASES MADE BY CLIENT BEFORE, DURING, OR AT THE CONCLUSION OF THE PUBLISHED WORK, THE CUSTOMER, ITS RELATIVE AFFILIATES, AS WELL AS ANY OTHER PERSON(S) IN VIEWING OF THIS PRODUCT IS RESPONSIBLE FOR VERIFYING COMPLIANCE WITH ANY BUT NOT LIMITED TO ALL CODES, PERMITS, RESTRICTIONS, INSTRUCTIONS, PURCHASES, AND INSTALLATIONS OF OBJECTS VIEWED WITHIN THIS DOCUMENT(S) OR PROJECT(S). SYMBOLS ARE NOT DRAWN TO SCALE, SIZE IS FOR CLARITY PURPOSES ONLY, SIZES AND DIMENSIONS ARE APPROXIMATE, ACTUAL MEASUREMENTS MAY VARY, DRAWINGS ARE NOT INTENDED FOR ENGINEERING OR CONSTRUCTION USE. THIS DOCUMENT, ANY RED LEONARD DRAWING(S), OR PROJECT(S) IS NOT TO BE USED AND/OR INTENDED FOR ENGINEERING OR CONSTRUCTION PURPOSES, BUT FOR ILLUSTRATIVE PURPOSES ONLY. ANY USE OF THIS DOCUMENTATION AND/OR OTHER ARTICLES PRODUCED BY RED LEONARD WITHOUT WRITTEN AUTHORIZATION FROM JAYME J. LEONARD IS STRICTLY PROHIBITED.

COMMERCIAL OUTDOOR

One Lithonia Way • Conyers, Georgia 30012 • Phone: 1-800-705-SERV (7378) • www.lithonia.com



Rev. 02/13/25

7 XT

SEW12146 5FT L20W AN08 120-277V 4000K PSE SMA OAP (6.00 IN.) FIXT. HEAD FACTORY SET TO 50 DEGREE TILT AWAY FROM BLDG.

WALL MOUNTED

QTY LABEL DESCRIPTION

XT1 SEW12146 4FT L16W AN08 120-277V 4000K PSE SMA OAP (6.00 IN.) FIXT. HEAD FACTORY SET TO 50 DEGREE TILT AWAY FROM BLDG.

WALL MOUNTED

1 XT2 SEW12146 6FT L24W AN08 120-277V 4000K SMA PSE OAP12

WALL MOUNTED

QTY LABEL DESCRIPTION 7 XX VWM-H-L17/840-TL-DBZ-CGL-DIM-UNV (BRONZE COLOR 80CRI)



Styk Exterior Wall - Stem

SPILIGHTING PROJECT DETAILS

TYPE: 4' Awning Light NOTES: Fixture head to be fixed at a 50 degree angle down away from the building.

JOB NAME: SHEETZ

**ORDERING CODE:** SEW12146 | 4FT-L16W[AN08] | 120-277V | 4000K | PSE | SMA | OAP[6.00in.] Please Note: Default specifications " **DF\_XXX** " will not appear in the ordering code.

SEW12146 2.20 in

Styk was built to provide the most lumens with the smallest luminaire package, while optimizing life. Not limited to decorative lighting. effective functional lighting is provided through the optimal light control in this minimal package. It's three optical offerings enable tremendous flexibility including wall washing, wall grazing, and asymmetric lighting solutions. It is excellent at lighting signs and facades. The family features wall, ceiling, and pendant models in a variety of stylish, clean mounting options. Available in 1' to 8' lengths, Styk can be mounted individually or configured in runs.

### FEATURES & BENEFITS

standard

- Sleek 1.5" diameter housing A forward throw optic, for even wall wash illumination, is
- Symmetrical optic options are available for more volumetric illumination
- Lamp body can be rotated up to 330° and locks into position for precise fixture alignment
- Up to 1,450 lumens per foot delivered (with Forward Throw distribution)
- Up to 18" projection with no vertical support needed
- Anodized finish provides durable corrosion protection
- All visible fasteners are flush mounted, providing a clean design

### Handcrafted in USA, BABA Compliant

- SPECIFICATIONS LIGHT SOURCE: IP66 white LED light engine
- CRI: 80+ or 90+
- LUMEN MAINTENANCE: L70 = >50,000 Hrs. • EFFICACY: 102 lm/W delivered (with Forward Throw
- distribution)
- CCT: 2700K, 3000K, 3500K, 4000K, 5000K VOLTAGE: 120-277V standard
- DRIVER: Includes one remote damp listed Class 2 power supply and either a damp location or wet location enclosure, except

SPILIGHTING P:262.242.1420 | SPIteam@spilighting.com | Last Revised: 1/24/2025 | Design Rights Reserved | SEW12146 | 1 of 8

- 8FT-L113W which has two. Black power cord standard unless otherwise specified. Max distance to the driver (including OAP) is: #18 AWG = 50', #16 AWG = 75', #14 AWG = 100'. For extended
- DIMMING: 0-10V controls standard to 1%

distances, contact factory.

- CONTROLS: Contact factory for control options (e.g., Lutron Athena, Current NX, nLight, Enlighted, Encelium, Wattstopper, WaveLinx, or Casambi).
- EMERGENCY: Remote battery option is provided with 10W Constant Power Battery back-up, providing 90 Minutes of Emergency operation. Contact factory for other Emergency
- INTEGRATED SURGE PROTECTION: LED components are
- protected against minor surge events
- CONSTRUCTION: Extruded aluminum construction provides durable protection for internal components and is recyclable
- FINISH: Housing available in anodized finishes only. End caps and mounting components painted to match.
- MODIFICATIONS: Consult factory for all modification requests,
- including RGB and static LED colors • APPROVALS: ETL listed to UL standards (US and Canada) for use in wet locations

## Styk Exterior Wall - Stem

SEW12146 2.20 in

JOB NAME: SHEETZ TYPE: 4' Awning Light

NOTES: Fixture head to be fixed at a 50 degree angle down away from the building.

SPILIGHTING

PROJECT DETAILS

**ORDERING CODE:** SEW12146 | 4FT-L16W[AN08] | 120-277V | 4000K | PSE | SMA | OAP[6.00in.] Please Note: Default specifications " **DF\_XXXX** " will not appear in the ordering code.

Styk was built to provide the most lumens with the smallest luminaire package, while optimizing life. Not limited to decorative lighting. effective functional lighting is provided through the optimal light control in this minimal package. It's three optical offerings enable tremendous flexibility including wall washing, wall grazing, and asymmetric lighting solutions. It is excellent at lighting signs and facades. The family features wall, ceiling, and pendant models in a variety of stylish, clean mounting options. Available in 1' to 8' lengths, Styk can be mounted individually or configured in runs.

### FEATURES & BENEFITS

- Sleek 1.5" diameter housing
- A forward throw optic, for even wall wash illumination, is standard
- Symmetrical optic options are available for more volumetric illumination
- Lamp body can be rotated up to 330° and locks into position for precise fixture alignment
- Up to 1,450 lumens per foot delivered (with Forward Throw
- distribution) • Up to 18" projection with no vertical support needed
- Anodized finish provides durable corrosion protection
- All visible fasteners are flush mounted, providing a clean design Handcrafted in USA, BABA Compliant

### SPECIFICATIONS

- LIGHT SOURCE: IP66 white LED light engine
- CRI: 80+ or 90+ • LUMEN MAINTENANCE: L70 = >50,000 Hrs. • EFFICACY: 102 lm/W delivered (with Forward Throw
- CCT: 2700K, 3000K, 3500K, 4000K, 5000K • VOLTAGE: 120-277V standard
- DRIVER: Includes one remote damp listed Class 2 power supply

and either a damp location or wet location enclosure, except

SPILIGHTING P:262.242.1420 | SPIteam@spilighting.com | Last Revised: 1/24/2025 | Design Rights Reserved | SEW12146 | 1 of 8

8FT-L113W which has two. Black power cord standard unless otherwise specified. Max distance to the driver (including OAP)

is: #18 AWG = 50', #16 AWG = 75', #14 AWG = 100'. For extended

- distances, contact factory.
- DIMMING: 0-10V controls standard to 1% • CONTROLS: Contact factory for control options (e.g., Lutron Athena, Current NX, nLight, Enlighted, Encelium, Wattstopper,
- WaveLinx, or Casambi). • EMERGENCY: Remote battery option is provided with 10W Constant Power Battery back-up, providing 90 Minutes of
- Emergency operation. Contact factory for other Emergency • INTEGRATED SURGE PROTECTION: LED components are
- protected against minor surge events CONSTRUCTION: Extruded aluminum construction provides
- durable protection for internal components and is recyclable • FINISH: Housing available in anodized finishes only. End caps
- and mounting components painted to match. • MODIFICATIONS: Consult factory for all modification requests,
- including RGB and static LED colors APPROVALS: ETL listed to UL standards (US and Canada) for use in wet locations

**SPI**LIGHTING Styk Exterior Wall - Stem PROJECT DETAILS

JOB NAME: SHEETZ SEW12146 2.20 in TYPE: 4' Awning Light NOTES: Fixture head to be fixed at a 50 degree angle down

QTY LABEL DESCRIPTION

away from the building. **ORDERING CODE:** SEW12146 | 4FT-L16W[AN08] | 120-277V | 4000K | PSE | SMA | OAP[6.00in.]

### Please Note: Default specifications " **DF\_XXX** " will not appear in the ordering code.

Styk was built to provide the most lumens with the smallest luminaire nackage while ontimizing life. Not limited to decorative lighting effective functional lighting is provided through the optimal light control in this minimal package. It's three optical offerings enable tremendous flexibility including wall washing, wall grazing, and asymmetric lighting solutions. It is excellent at lighting signs and facades. The family features wall, ceiling, and pendant models in a variety of stylish, clean mounting options. Available in 1' to 8' lengths, Styk can be mounted individually or configured in runs.

### FEATURES & BENEFITS

- Sleek 1.5" diameter housing
- A forward throw optic, for even wall wash illumination, is standard
- Symmetrical optic options are available for more volumetric illumination
- Lamp body can be rotated up to 330° and locks into position for precise fixture alignment
- Up to 1,450 lumens per foot delivered (with Forward Throw distribution)
- Up to 18" projection with no vertical support needed Anodized finish provides durable corrosion protection
- All visible fasteners are flush mounted, providing a clean design
- Handcrafted in USA, BABA Compliant

### SPECIFICATIONS

- LIGHT SOURCE: IP66 white LED light engine • CRI: 80+ or 90+
- LUMEN MAINTENANCE: L70 = >50,000 Hrs.
- EFFICACY: 102 lm/W delivered (with Forward Throw
- CCT: 2700K, 3000K, 3500K, 4000K, 5000K
- VOLTAGE: 120-277V standard
- DRIVER: Includes one remote damp listed Class 2 power supply and either a damp location or wet location enclosure, except

SPILIGHTING P:262.242.1420 | SPIteam@spilighting.com | Last Revised: 1/24/2025 | Design Rights Reserved | SEW12146 | 1 of 8

### 8FT-L113W which has two. Black power cord standard unless otherwise specified. Max distance to the driver (including OAP) is: #18 AWG = 50', #16 AWG = 75', #14 AWG = 100'. For extended

- distances, contact factory. • **DIMMING:** 0-10V controls standard to 1%
- CONTROLS: Contact factory for control options (e.g., Lutron Athena, Current NX, nLight, Enlighted, Encelium, Wattstopper, WaveLinx, or Casambi).
- EMERGENCY: Remote battery option is provided with 10W Constant Power Battery back-up, providing 90 Minutes of Emergency operation. Contact factory for other Emergency
- INTEGRATED SURGE PROTECTION: LED components are
- protected against minor surge events • CONSTRUCTION: Extruded aluminum construction provides
- durable protection for internal components and is recyclable • FINISH: Housing available in anodized finishes only. End caps
- and mounting components painted to match. • MODIFICATIONS: Consult factory for all modification requests, including RGB and static LED colors
- APPROVALS: ETL listed to UL standards (US and Canada) for use in wet locations

SHEETZ 2.0



MODEL #: REFER TO LIGHTING FIXTURE SCHEDULE FOR MODEL NUMBER AND DESCRIPTION


Shimstone Design Studio LLC, 7400 1st Avenue, North Bergen, NJ 07047, Tel: 201.861.5390

SDS PROJECT #: 0609.0

SHEETZ 2.0

TYPE: XS2

TYPE: XS2

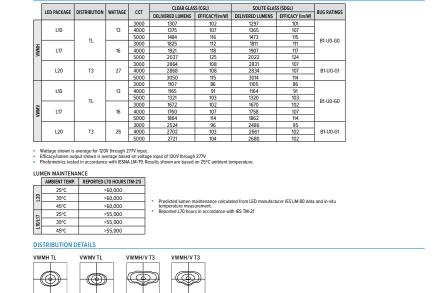

H.E. Williams, Inc. 

Carthage, Missouri 

www.hew.com 

417-358-4065 

Designed and Manufactured in the USA

MODEL #: REFER TO LIGHTING FIXTURE SCHEDULE FOR MODEL NUMBER AND DESCRIPTION

Shimstone Design Studio LLC, 7400 1st Avenue, North Bergen, NJ 07047, Tel: 201.861.5390

SPILIGHTING P:262.242.1420 | SPIteam@spilighting.com | Last Revised: 1/24/2025 | Design Rights Reserved | SEW12146 | 2 of 8

SPILIGHTING P:262.242.1420 | SPIteam@spilighting.com | Last Revised: 1/24/2025 | Design Rights Reserved | SEW12146 | 2 of 8

SPILIGHTING P:262.242.1420 | SPIteam@spilighting.com | Last Revised: 1/24/2025 | Design Rights Reserved | SEW12146 | 2 of 8

ANY SITE PLAN(S), FLOOR PLAN(S), RENDERING(S), LIGHTING LAYOUT(S) AND PHOTOMETRIC PLAN(S) INCLUDING BUT NOT LIMITED TO ANY PROJECT(S) CREATED/PRODUCED BY RED LEONARD ASSOCIATES INC., ARE ONLY INTENDED FOR ILLUSTRATION AND QUOTING PURPOSES ONLY. RED LEONARD ASSOCIATES HAS THE RIGHT TO USE THIRD PARTY LASERS, SCANNERS, AND CAMERAS BUT ACTUAL PROJECT CONDITIONS, DIMENSIONS, AND ACCURACY OF MEASUREMENTS MAY DIFFER FROM THESE OR ANY PARAMETERS. RED LEONARD ASSOCIATES INC. ASSUMES NO LIABILITY FOR WHAT IS CREATED/PRODUCED IN THESE RECREATIONS. THIS INCLUDES BUT IS NOT LIMITED TO THE USE OF, INSTALLATION OF AND/OR INTEGRITY OF EXISTING BUILDING(S), SURROUNDING AREA FOR PRODUCT(S) SUCH AS EXISTING POLE(S), ANCHOR BOLT(S), BASE(S), ARCHITECTURAL AND SIGNAGE STRUCTURE(S), LANDSCAPING PLAN(S), LIGHTING PLAN(S), FIXTURE SELECTION(S) AND PLACEMENT, MATERIAL(S), COLOR ACCURACY, TEXTURE(S), AND ANYTHING ATTRIBUTED TO PHOTO REALISM THAT IS CREATED, FURTHERMORE, RED LEONARD ASSOCIATES INC., DOES NOT ASSUME LIABILITY WHATSOEVER FOR ANY PURCHASES MADE BY CLIENT BEFORE, DURING, OR AT THE CONCLUSION OF THE PUBLISHED WORK, THE CUSTOMER, ITS RELATIVE AFFILIATES, AS WELL AS ANY OTHER

PERSON(S) IN VIEWING OF THIS PRODUCT IS RESPONSIBLE FOR VERIFYING COMPLIANCE WITH ANY BUT NOT LIMITED TO ALL CODES, PERMITS, RESTRICTIONS, INSTRUCTIONS, PURCHASES, AND INSTALLATIONS OF OBJECTS VIEWED

WITHIN THIS DOCUMENT(S) OR PROJECT(S). SYMBOLS ARE NOT DRAWN TO SCALE. SIZE IS FOR CLARITY PURPOSES ONLY. SIZES AND DIMENSIONS ARE APPROXIMATE, ACTUAL MEASUREMENTS MAY VARY. DRAWINGS ARE NOT

INTENDED FOR ENGINEERING OR CONSTRUCTION USE. THIS DOCUMENT, ANY RED LEONARD DRAWING(S), OR PROJECT(S) IS NOT TO BE USED AND/OR INTENDED FOR ENGINEERING OR CONSTRUCTION PURPOSES, BUT FOR

ILLUSTRATIVE PURPOSES ONLY. ANY USE OF THIS DOCUMENTATION AND/OR OTHER ARTICLES PRODUCED BY RED LEONARD WITHOUT WRITTEN AUTHORIZATION FROM JAYME J. LEONARD IS STRICTLY PROHIBITED

PROJECT NAME: SHEETZ #416 ZEBULON, NC DRAWING NUMBER: RL-10222-S1-R1







513-574-9500 ∤ redleonard.com