

LITTLE RIVER PARK - PHASE 1

1800 WEST GANNON AVENUE
ZEBULON, NC 27597

CONSULTANTS

LANDSCAPE ARCHITECT



Alfred Benesch & Company
8000 Regency Parkway, Suite 175
Cary, NC 27518
www.benesch.com
P 984.275.2490

Corp. NC License: F-1320

CIVIL ENGINEER



Alfred Benesch & Company
8000 Regency Parkway, Suite 175
Cary, NC 27518
www.benesch.com
P 984.275.2490

Corp. NC License: F-1320


ELECTRICAL ENGINEER



Lighthouse Engineering
400 W. Morgan Street, Suite 100
Raleigh, NC 27603
P 919.835.9781



NORTH CAROLINA

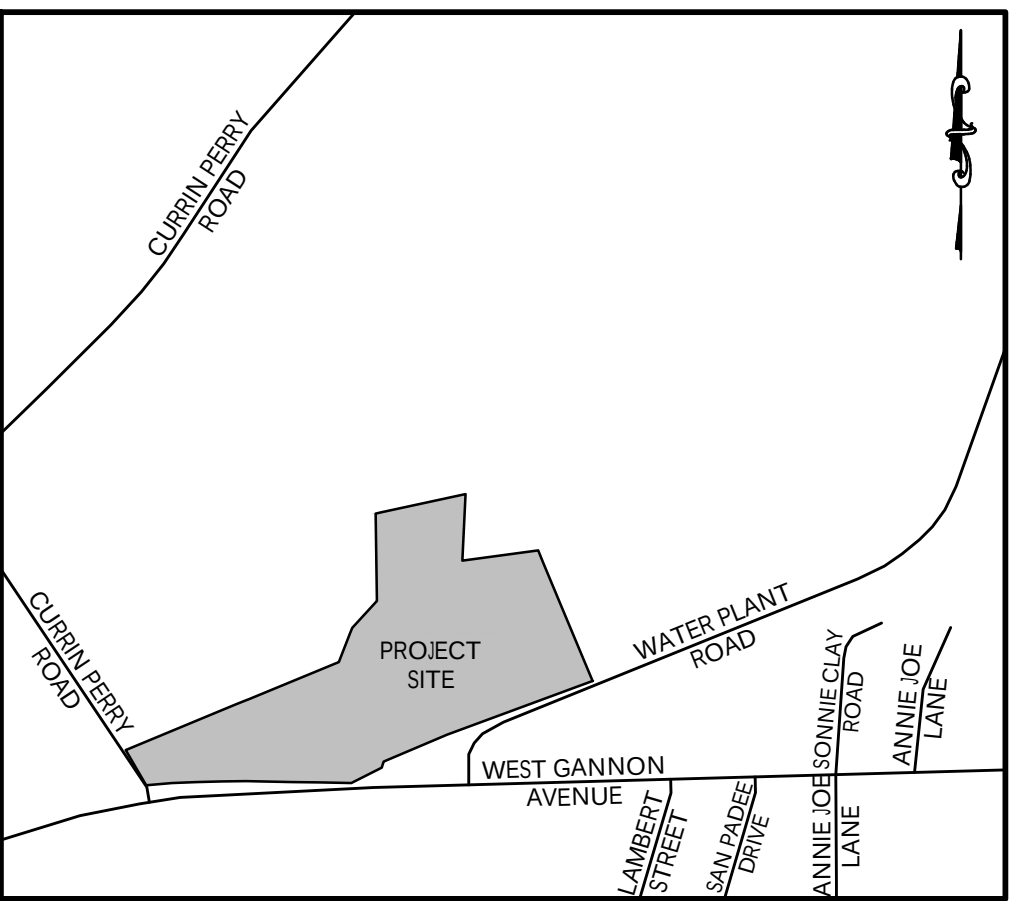

VICINITY MAP

SHEET INDEX	
SHEET NUMBER	SHEET TITLE
--	COVER SHEET
C0.10	SURVEY
C1.00	OVERALL EXISTING CONDITIONS DEMOLITION PLAN
C1.01	ENLARGED EXISTING CONDITIONS DEMOLITION PLAN
C200	OVERALL SITE PLAN
C201	ENLARGED SITE PLAN
C300	OVERALL EROSION CONTROL PLAN
C301	EROSION CONTROL PLAN PHASE 1
C302	EROSION CONTROL PLAN PHASE 2
C303	OVERALL GRADING PLAN
C304	ENLARGED GRADING PLAN
C400	OVERALL UTILITY PLAN
C401	ENLARGED UTILITY PLAN
C500	RESTROOM AND SHELTER DETAILS
C501	SITE CONSTRUCTION DETAILS
C502	SITE CONSTRUCTION DETAILS
C503	EROSION CONTROL DETAILS
C504	SANITARY SEWER DETAILS
C505	WATER DETAILS
C600	OVERALL LANDSCAPE PLAN
C601	LANDSCAPE PLAN
C700	SITE LIGHTING PLAN

ELECTRICAL	
E0.1	ELECTRICAL LEGEND AND NOTES
E0.2	ELECTRICAL SITE PLAN
E1.0	ELECTRICAL FLOOR PLAN AND RISER

EROSION CONTROL, STORMWATER AND FLOODPLAIN MANAGEMENT	
APPROVED	
EROSION CONTROL ☐ SEC-_____	
STORMWATER MGMT. ☐ SWF-_____	
FLOOD STUDY ☐ SWF-_____	
DATE _____	
	ENVIRONMENTAL CONSULTANT SIGNATURE _____

Issued for Permits

DATE OF ISSUE: 4/18/2025 SET NO.: _____


Corp. NC License: F-1320

1800 WEST GANNON AVENUE
ZEBULON, NORTH CAROLINA

Project No: 1725-500672.00
Date: 4.18.25
Revisions:

SURVEY

C0.10

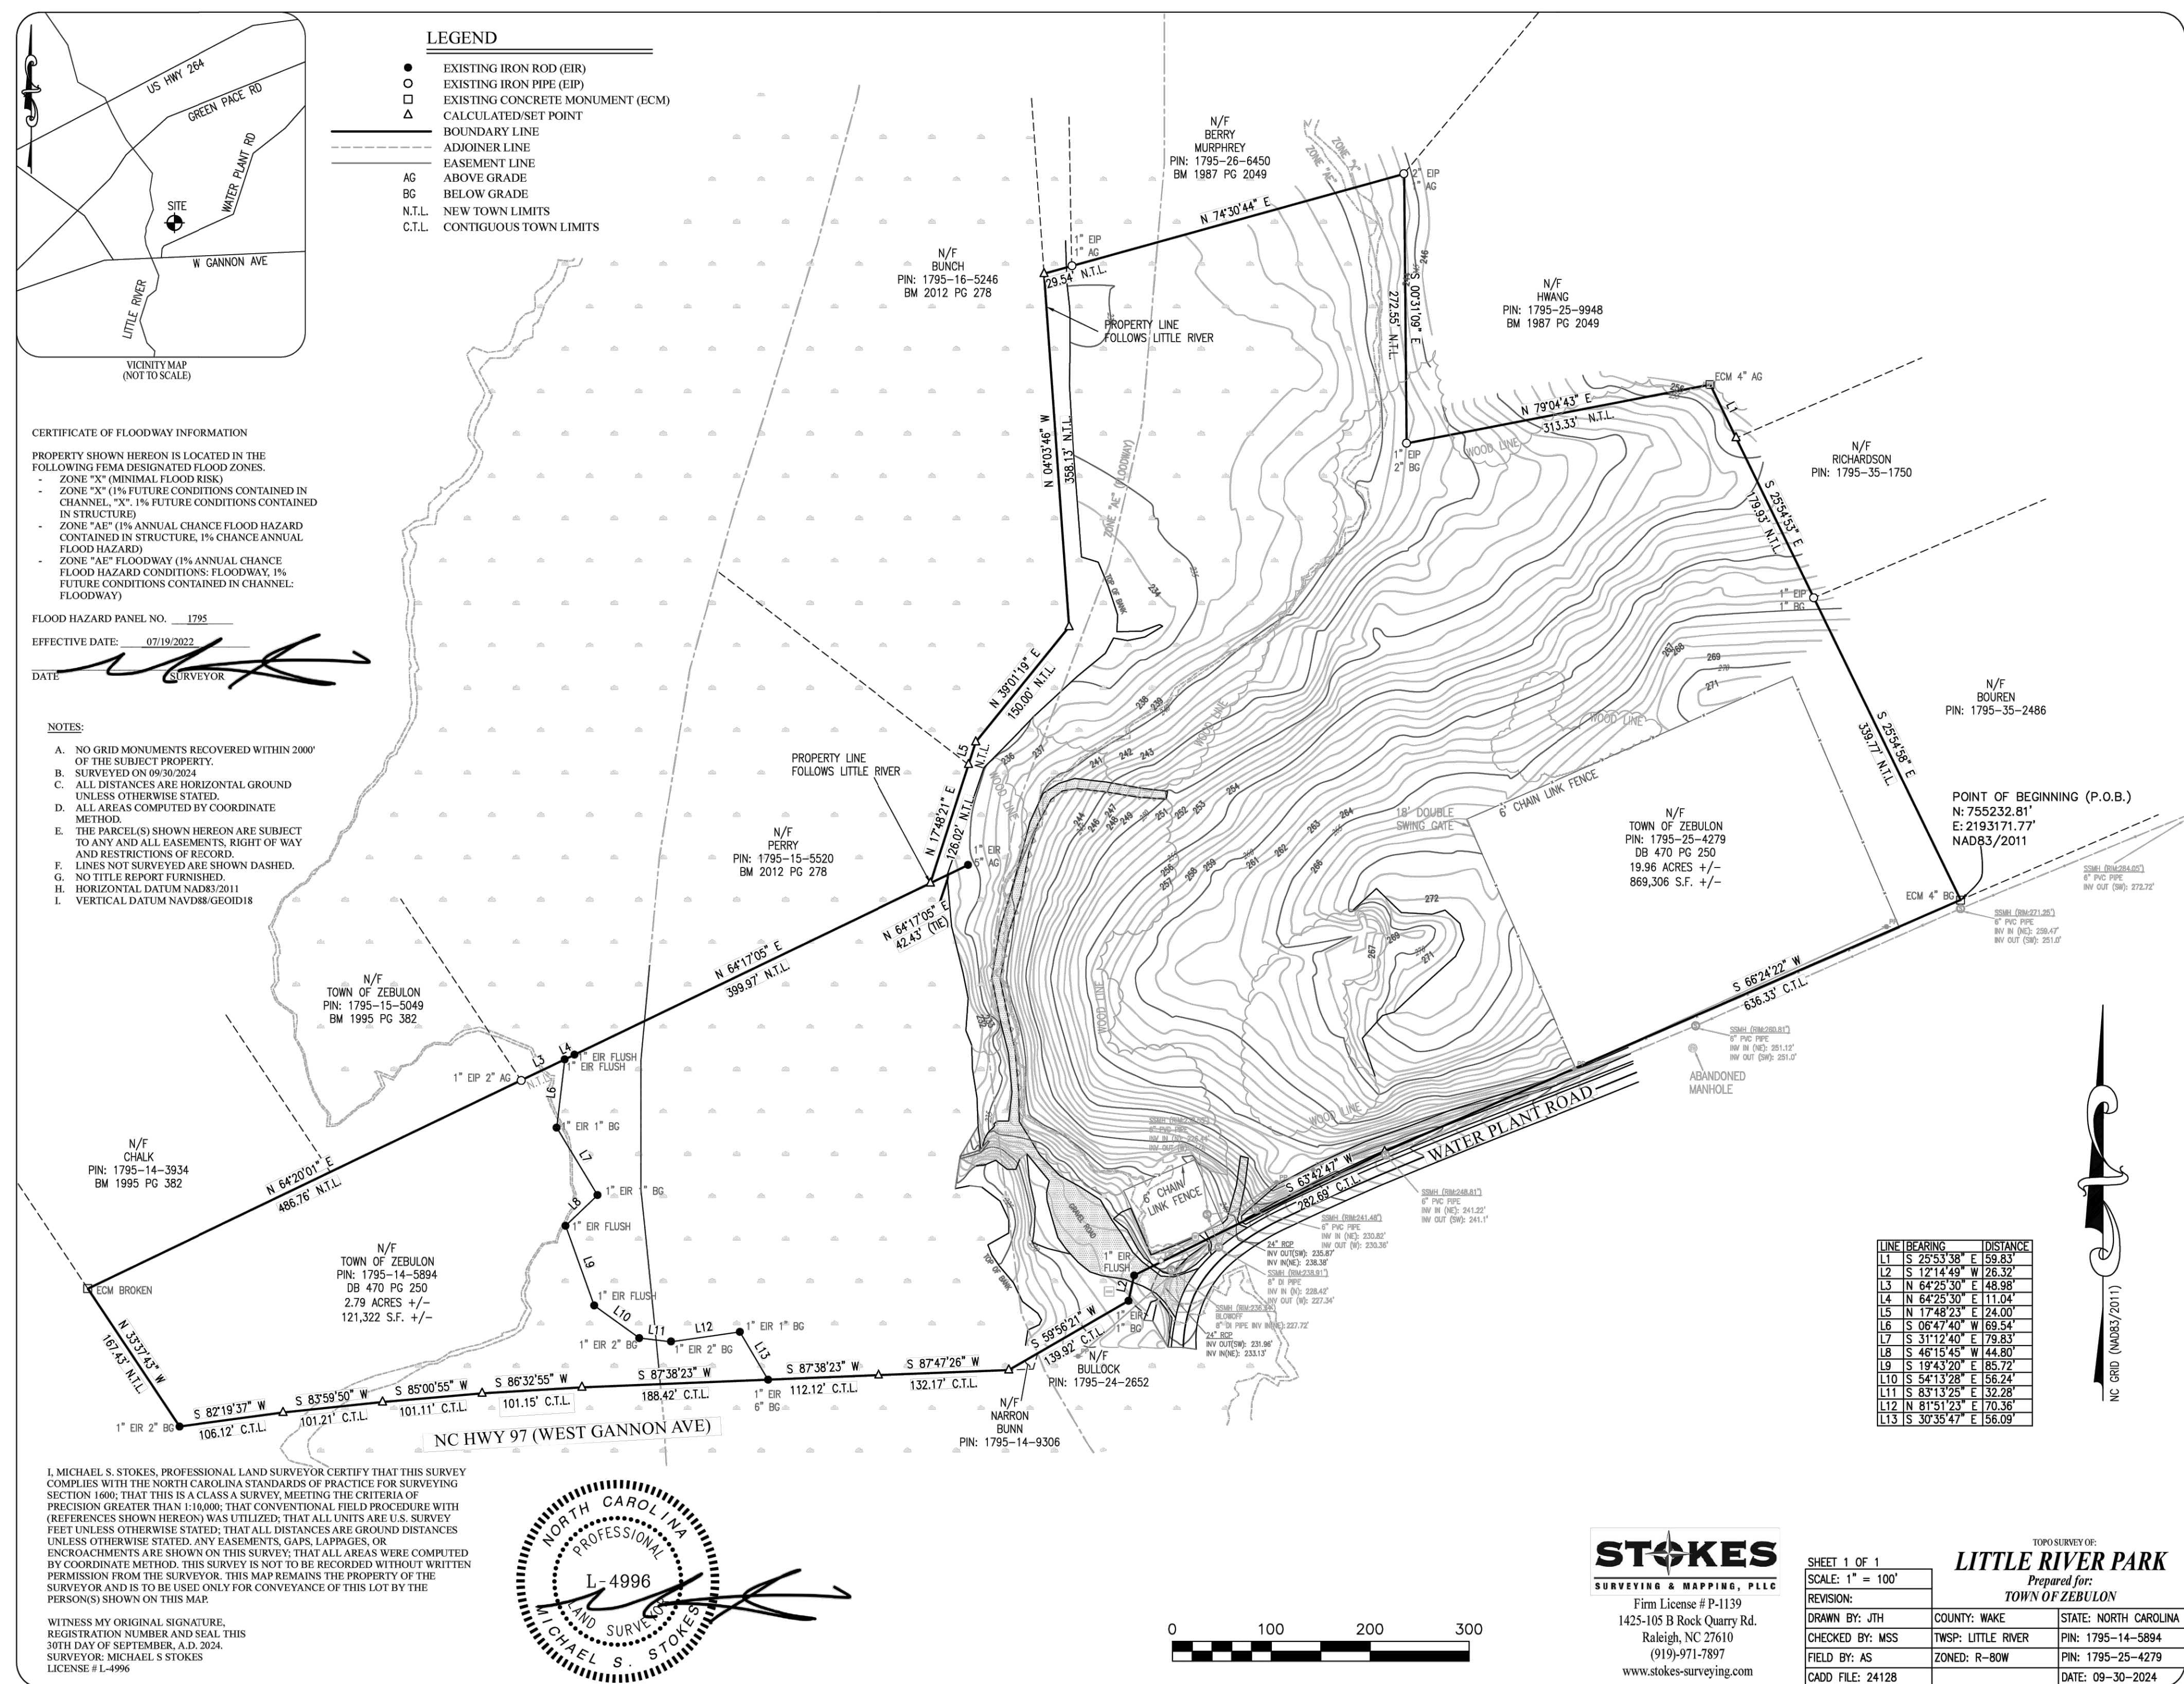


Y:\North Carolina\1725-50672\1725-50672-00_Zebulon_Little_River\1725-50672-00_Existing Conditions DEMO PLAN.dwg

LEGEND	
	EXISTING SIGN
	EXISTING IRON PIN
	EXISTING LIGHT POLE
	EXISTING UTILITY POLE
	RIGHT-OF-WAY
	HC
	R/W
	ACCESSIBLE SPACE
	EXISTING TREE TO REMAIN
	EXISTING TREE TO BE REMOVED
	EXISTING FIRE HYDRANT
	EXISTING WATER VALVE
	EXISTING WATER METER
	EXISTING SEWER MANHOLE
	EXISTING STORM MANHOLE
	EXISTING DRAINAGE STRUCTURE
	EXISTING CLEANOUT
	EXISTING SPOT ELEVATION
	EXISTING GAS VALVE
	EXISTING GAS METER
	EXISTING ITEMS TO BE REMOVED
	SAWCUT LINE
	EXISTING CURB AND GUTTER
	PROPERTY LINE
	EXISTING FENCE
	EXISTING UNDERGROUND ELECTRIC LINE
	EXISTING OVERHEAD ELECTRIC LINE
	EXISTING UNDERGROUND TELEPHONE LINE
	EXISTING FIBER OPTIC LINE
	EXISTING SANITARY SEWER LINE
	EXISTING WATER LINE
	EXISTING GAS LINE
	EXISTING CONTOUR LINE
	TEMPORARY SILT FENCE
	TEMPORARY SILT FENCE AND TREE PROTECTION
	TEMPORARY TREE PROTECTION
	SUPER SILT FENCE
	EXISTING TREELINE
	EXISTING EASEMENT
	FLOOD ZONE "Ae"
	FLOOD ZONE "Ae"
	STREAM CENTER LINE
	EXISTING TO BE REMOVED
	WETLANDS EXTENT

DEMOLITION/CLEARING NOTES

- BOUNDARY AND TOPOGRAPHIC INFORMATION TAKEN FROM A SURVEY PREPARED BY STOKES SURVEYING & MAPPING, PLLC DATED 9/30/2024.
- CONTRACTOR SHALL REMOVE EXISTING TREES, CONCRETE, ASPHALT AND OTHER EXISTING STRUCTURES INDICATED ON PLAN. CONTRACTOR TO DISPOSE OF ALL DEBRIS TO AN APPROVED (LEGAL) OFF-SITE LOCATION.
- PROTECT ADJACENT CURBS, TREES, BUILDINGS, UTILITIES AND OTHER ITEMS TO REMAIN FROM DAMAGE. CONTRACTOR SHALL BE RESPONSIBLE FOR REPAIR AND/OR PAYMENT OF ANY DAMAGED ITEMS TO REMAIN.
- CONTRACTOR SHALL VERIFY LOCATION OF ALL UNDERGROUND UTILITIES PRIOR TO BEGINNING WORK. BOTH PUBLIC AND PRIVATE. CONTRACTOR IS FULLY RESPONSIBLE FOR ALL UNDERGROUND UTILITIES AND SHALL REPAIR ANY DAMAGE AS A RESULT OF THIS CONTRACT.
- CONTRACTOR SHALL REPORT ANY ENCROACHMENTS OR DISCREPANCIES IMMEDIATELY TO ALFRED BENESCH & COMPANY FOR DECISION.
- HATCHED AREA ON THIS PLAN INDICATES EXISTING WOODED AREA TO BE REMOVED. DUE TO A LACK OF AN INDIVIDUAL TREE SURVEY, TREE SAVE AREAS ARE SHOWN IN MASSES. CONTRACTOR SHALL MAKE EVERY EFFORT TO SAVE ANY SPECIMEN TREES NEAR CLEARING LIMITS.
- CONTRACTOR SHALL MAKE EVERY EFFORT TO SAVE ADDITIONAL TREES WHEREVER FEASIBLE.
- NO SOIL DISTURBANCE OR COMPACTION, CONSTRUCTION MATERIALS, TRAFFIC, BURIAL PITS, TRENCHING OR OTHER LAND DISTURBING ACTIVITY ALLOWED IN THE TREE SAVE AREA.
- CLEARING LIMITS ON THE PLAN INDICATE THE EXTENT OF ALL MAJOR CLEARING REQUIRED. CONTRACTOR IS ALSO RESPONSIBLE FOR ANY INCIDENTAL CLEARING REQUIRED FOR MINOR DISCREPANCIES IN GRADE, UTILITY OR STORM PIPE INSTALLATIONS, EROSION CONTROL MEASURES, ETC.

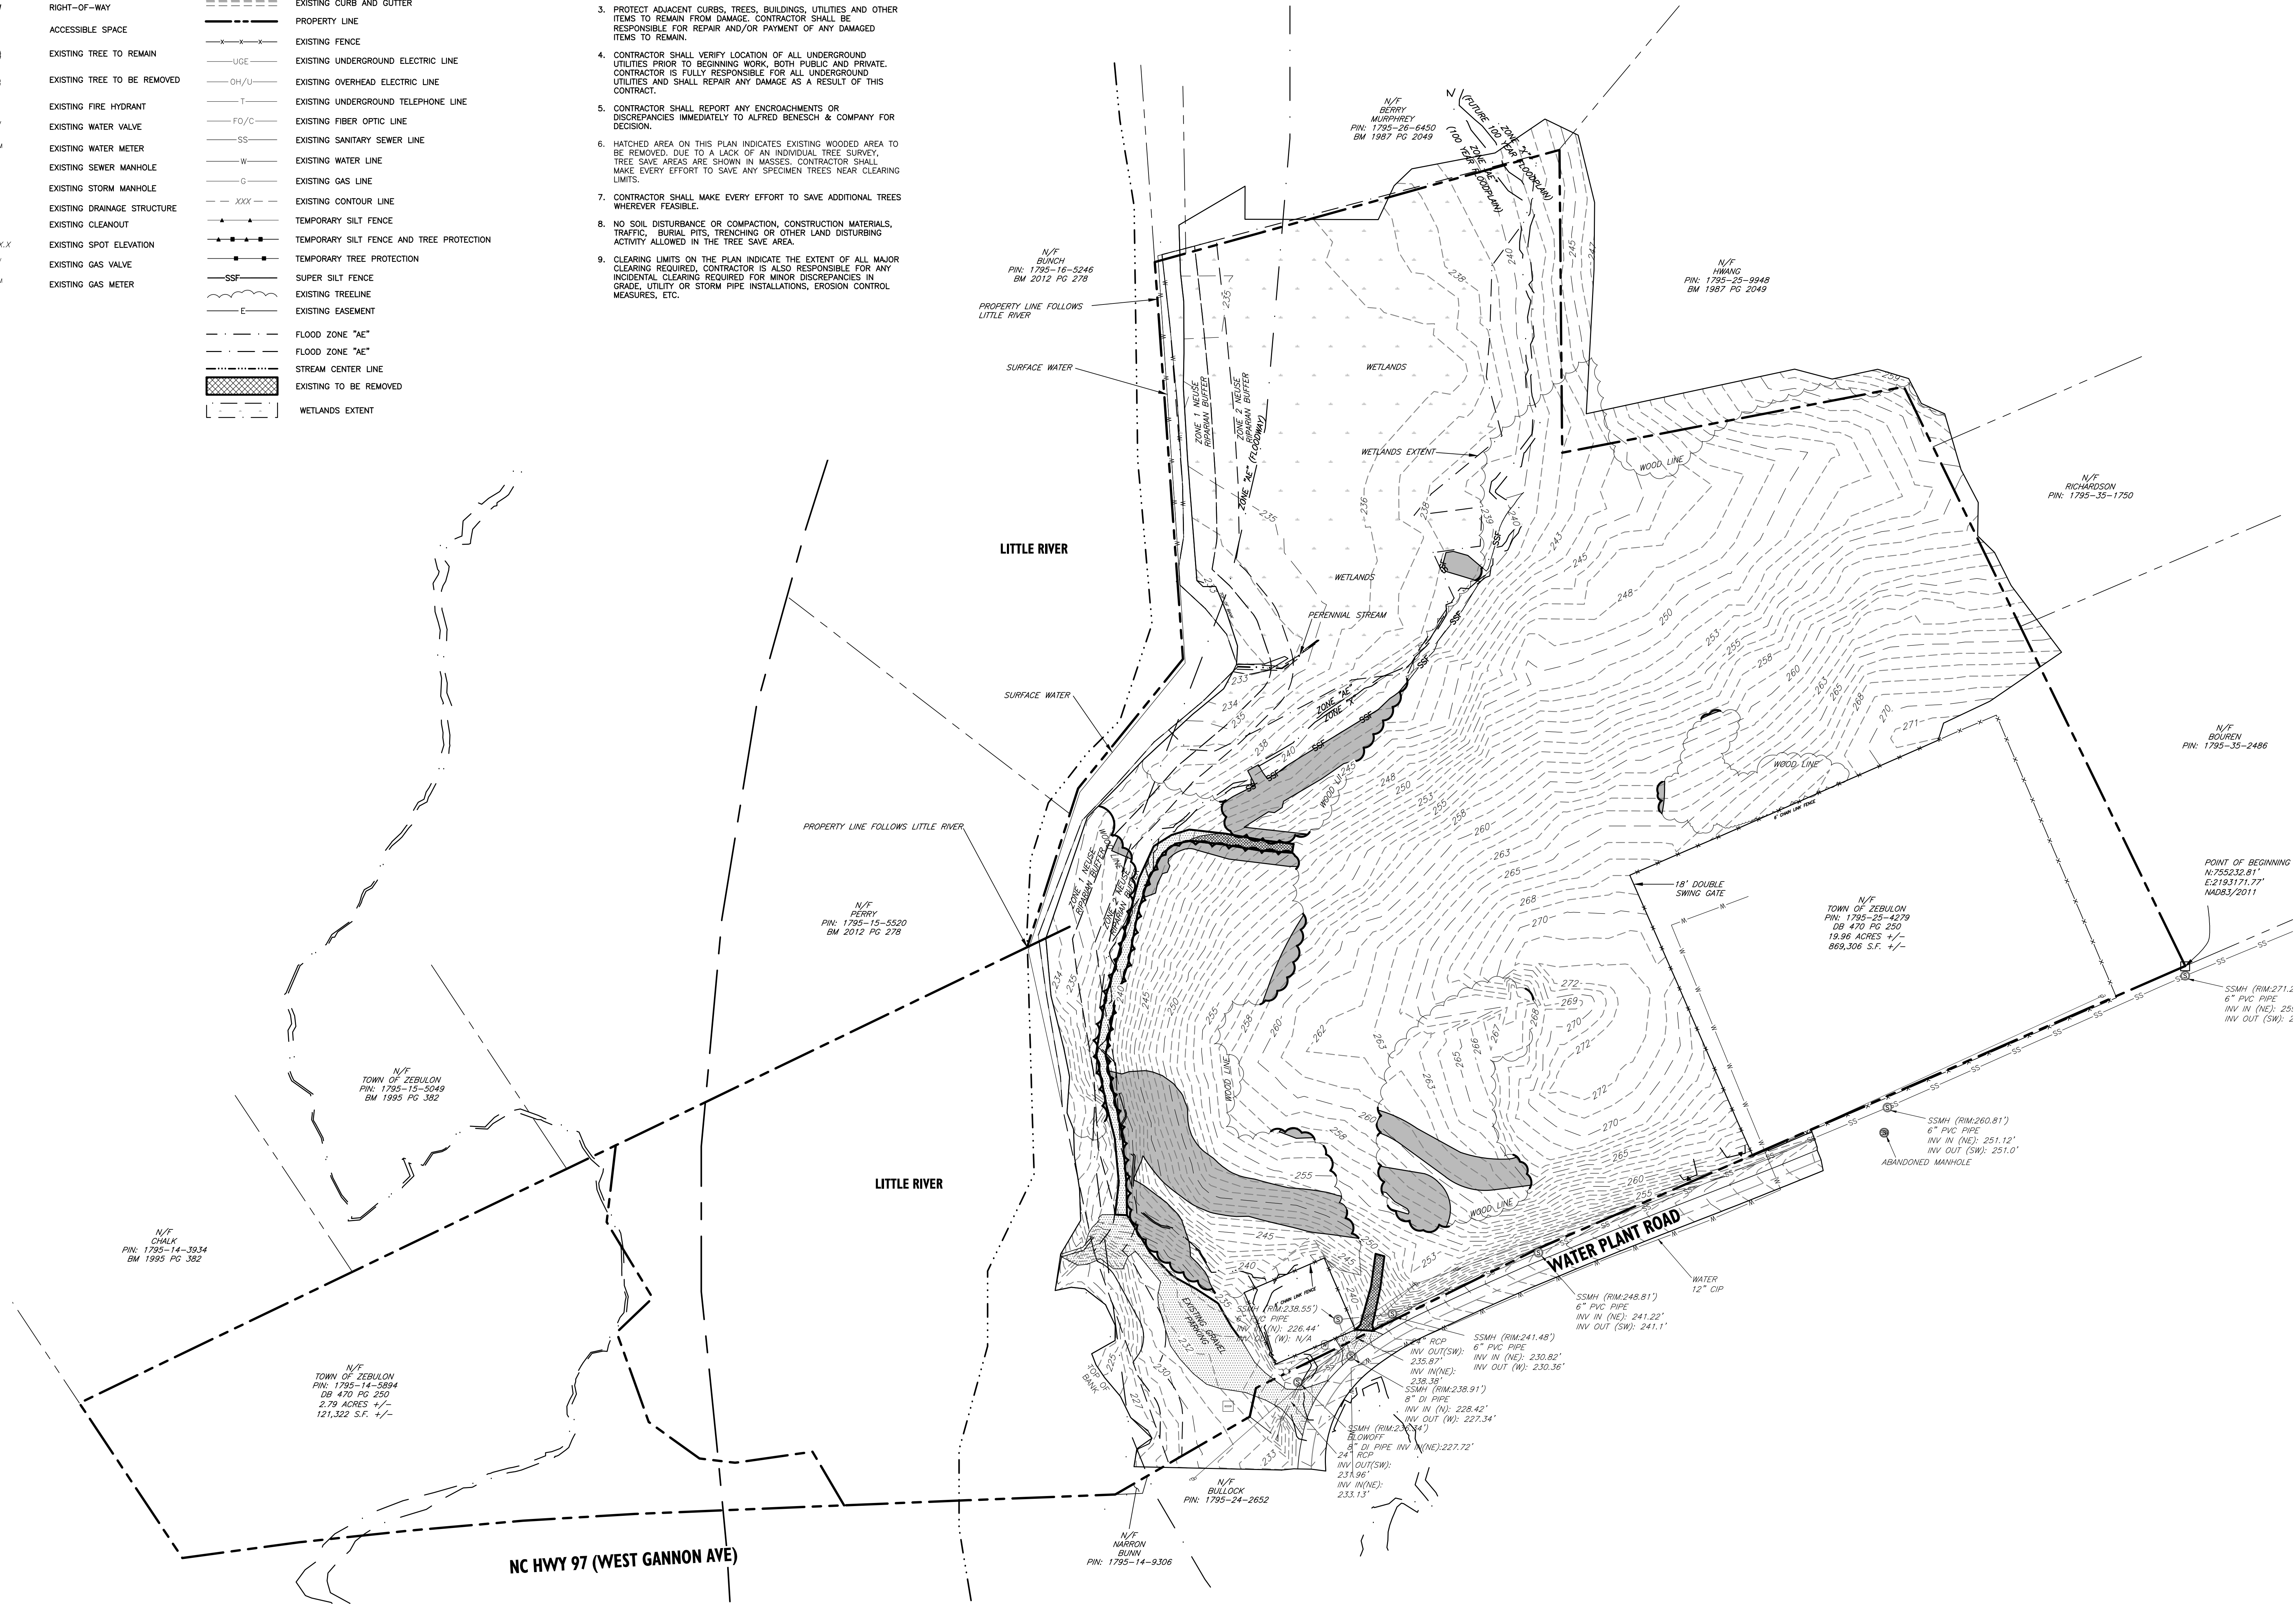

Seals:



Corp. NC License: F-1320


LITTLE RIVER PARK

1800 WEST GANNON AVENUE
ZEBULON, NORTH CAROLINA

Project No: 1725-500672.00
Date: 4.18.25
Revisions:

Sheet Title:
OVERALL
EXISTING
CONDITIONS
DEMOLITION
PLAN
Sheet No:

CI.00

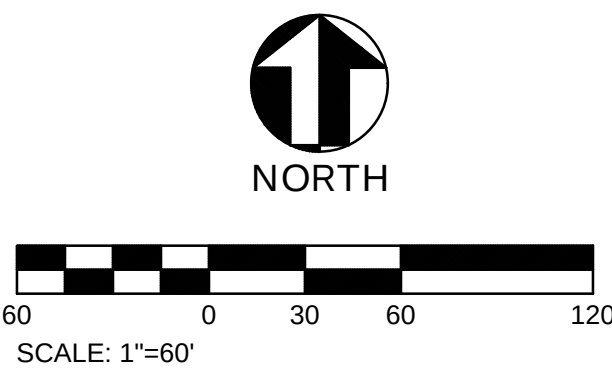

Y:\North Carolina\TXS\05\1725-500672-00_Zebulon_Land_Improvement_Demo\Drawings\1725-500672-00-EXISTING CONDITIONS DEMO PLAN.dwg



LEGEND			
	EXISTING SIGN		EXISTING TREE TO BE REMOVED
	EXISTING IRON PIN		EXISTING TREE CLEARING
	EXISTING LIGHT POLE		SAWCUT LINE
	EXISTING UTILITY POLE		EXISTING CURB AND GUTTER
	RIGHT-OF-WAY		PROPERTY LINE
	ACCESSIBLE SPACE		EXISTING FENCE
	EXISTING TREE TO REMAIN		EXISTING UNDERGROUND ELECTRIC LINE
	EXISTING TREE TO BE REMOVED		EXISTING OVERHEAD ELECTRIC LINE
	EXISTING FIRE HYDRANT		EXISTING UNDERGROUND TELEPHONE LINE
	EXISTING WATER VALVE		EXISTING FIBER OPTIC LINE
	EXISTING WATER METER		EXISTING SANITARY SEWER LINE
	EXISTING SEWER MANHOLE		EXISTING WATER LINE
	EXISTING STORM MANHOLE		EXISTING GAS LINE
	EXISTING DRAINAGE STRUCTURE		EXISTING CONTOUR LINE
	EXISTING CLEANOUT		TEMPORARY SILT FENCE
	EXISTING SPOT ELEVATION		TEMPORARY SILT FENCE AND TREE PROTECTION
	EXISTING GAS VALVE		TEMPORARY TREE PROTECTION
	EXISTING GAS METER		SUPER SILT FENCE
			EXISTING TREELINE
			EXISTING EASEMENT
			FLOOD ZONE "AE"
			FLOOD ZONE "AE"
			STREAM CENTER LINE
			EXISTING TO BE REMOVED
			WETLANDS EXTENT

Seals:




Corp. NC License: F-1320

LITTLE RIVER PARK

1800 WEST GANNON AVENUE
ZEBULON, NORTH CAROLINA


Project No: 1725-500672.00
Date: 4.18.25
Revisions:

Sheet Title:
ENLARGED
EXISTING
CONDITIONS
DEMOLITION
PLAN
Sheet No:
CI.01

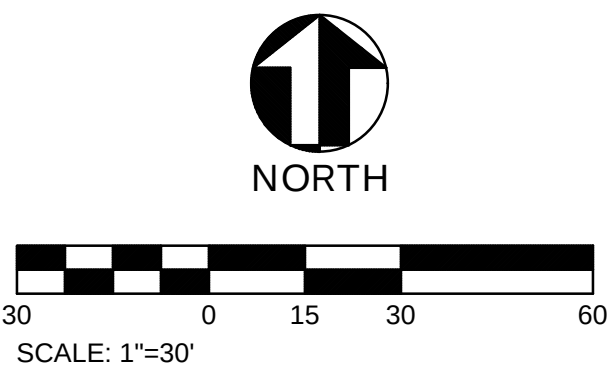

PAVEMENT COVERAGE: 58,736 Sq. Ft. / Acres

1. DIMENSIONS AND COORDINATE POINTS ARE TO FACE OF CURB, EDGE OF PAVEMENT, OR CORNER OF BUILDING UNLESS OTHERWISE NOTED.
2. ALL IMPROVEMENTS AND CONSTRUCTION SHALL BE IN ACCORDANCE WITH THE LOCAL, STATE AND FEDERAL REQUIREMENTS.
3. ANY DISCREPANCIES FOUND IN THE FIELD SHALL BE CALLED TO THE ATTENTION OF THE OWNER OR ENGINEER PRIOR TO PROCEEDING WITH WORK.
4. PRIOR TO BEGINNING CONSTRUCTION, UNLESS OTHERWISE PROVIDED IN CONTRACT DOCUMENTS, THE CONTRACTOR SHALL SECURE AND PAY FOR ALL PERMITS (BOTH SITE AND BUILDING RELATED) AND OBTAIN ALL NECESSARY INSURANCES, BONDS, LICENSES, AND INSPECTIONS NECESSARY FOR PROPER EXECUTION AND COMPLETION OF THE WORK.
5. THE GENERAL CONTRACTOR SHALL CALL ALL OWNERS OF EXISTING UTILITY, UTILITIES, AND RIGHT-OF-WAYS, PUBLIC AND PRIVATE, PRIOR TO WORKING IN THESE AREAS.
6. GENERAL CONTRACTOR SHALL MAINTAIN THE SITE IN A MANNER SO THAT THE GRAMEN AND THE PUBLIC SHALL BE PROTECTED FROM INJURY.
7. SIGHT TRIANGLES SHOWN ARE THE MINIMUM REQUIRED.
8. USE CAUTION WHEN REPRODUCING COPIES OF THE CONSTRUCTION DRAWINGS, COPIES MAY SUBJECT TO DISTORTION AND INACCURACY DUE TO SCALE OF DRAWINGS. VERIFY ANY DISCREPANCIES WITH BENESCH.
9. ALL SIGNS, PAVEMENT MARKINGS, AND OTHER TRAFFIC CONTROL DEVICES SHALL BE IN ACCORDANCE WITH THE UNIFORM TRAFFIC CONTROL DEVICES (MUTCD), LATEST EDITION AS AMENDED.
10. ALL PAVEMENT MARKINGS SHALL BE FOUR (4) INCHES WIDE UNLESS INDICATED OTHERWISE ON THE DRAWINGS.
11. CONTRACTOR SHALL FURNISH AND INSTALL ALL PAVEMENT MARKINGS SHOWN ON THE PLANS.
12. CONTRACTOR SHALL SAW-CUT EXISTING ASPHALT PAVEMENT AREAS TO BE IN SMOOTHLY TO PROPOSED PAVEMENT AT DRIVEWAY ENTRANCES.
13. REMOVE ARCHITECTURAL PLANS FOR ACTUAL BUILDING DIMENSIONS.
14. THE ENGINEER WILL PROVIDE THE CONTRACTOR WITH AN ELECTRONIC FILE OF THESE DRAWINGS UPON REQUEST.
15. CONTACT THE UTILITY COMPANY TO RELOCATE ANY EXISTING UTILITY LINES, EXISTING FACILITIES, OR STRUCTURES IN CONFLICT WITH IMPROVEMENTS UNDER THE SCOPE OF THIS PROJECT MUST BE RELOCATED AT THE EXPENSE OF THE OWNER.
16. STOP BEFORE YOU DIG. CALL 811. IT'S THE LAW.
17. HEAVY DUTY PAVEMENT SHOWN ON THIS PLAN IS CAPABLE OF SUPPORTING AN \$8,000+ GVW TRUCK.

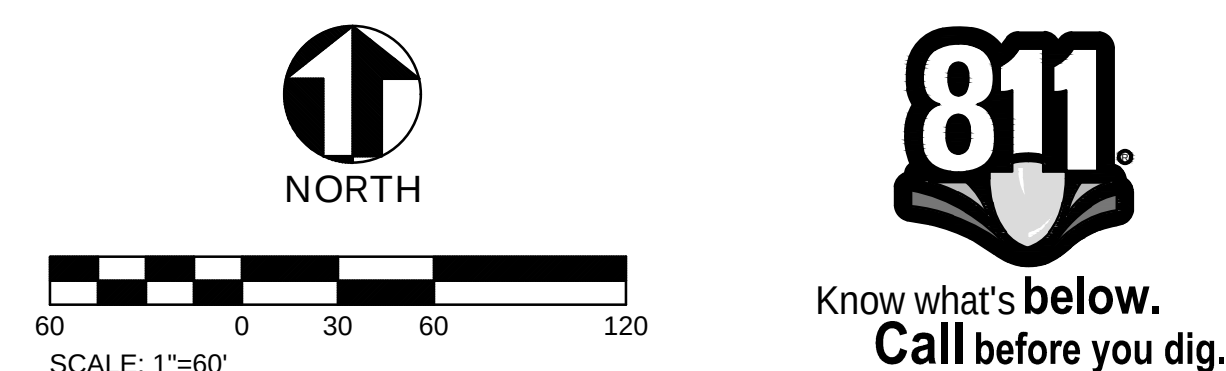


Y:\North Carolina\TXS-05\1725-500672-00_Zebulon_Plan_800x720.dwg (1725-500672-00_Zebulon_Plan_800x720.dwg) 1725-500672-00_Zebulon_Plan_800x720.dwg

LEGEND			
	EXISTING SIGN		EXISTING CURB AND GUTTER
	EXISTING IRON PIN		PROPOSED CURB AND GUTTER
	EXISTING LIGHT POLE		PROPERTY LINE
	EXISTING UTILITY POLE		EXISTING FENCE
	RIGHT-OF-WAY		EXISTING UNDERGROUND ELECTRIC LINE
	ACCESSIBLE SPACE		EXISTING OVERHEAD UTILITY LINE
	EXISTING TREE TO REMAIN		EXISTING UNDERGROUND TELEPHONE LINE
	EXISTING FIRE HYDRANT		EXISTING FIBER OPTIC LINE
	EXISTING WATER VALVE		EXISTING SANITARY SEWER LINE
	EXISTING WATER METER		EXISTING WATER LINE
	EXISTING SEWER MANHOLE		EXISTING GAS LINE
	EXISTING STORM MANHOLE		EXISTING CONTOUR LINE
	PROPOSED STORM MANHOLE		PROPOSED CONTOUR LINE
	PROPOSED FLARED END SECTION		PROPOSED DRAINAGE DITCH
	EXISTING DRAINAGE STRUCTURE		EXISTING STORM DRAINAGE PIPE
	PROPOSED DRAINAGE STRUCTURE		PROPOSED STORM DRAINAGE PIPE
	EXISTING SPOT ELEVATION		PROPOSED ROOF DRAIN PIPE
	PROPOSED SPOT ELEVATION		EXISTING TREE LINE
	EXISTING CLEANOUT		PROPOSED TREE LINE
	EXISTING DOWNSPOUT		EXISTING GAS VALVE
	WETLANDS EXTENT		EXISTING GAS METER
	TEMPORARY SILT SACK		ZONE "Ae" (100 YEAR FLOODPLAIN)
	TEMPORARY INLET PROTECTION		ZONE "X" (FUTURE 100 YEAR FLOODPLAIN)
	TEMPORARY ROCK CHECK DAM		STREAM CENTER LINE
	TEMPORARY FILTER BERM BASIN		TEMPORARY SILT FENCE
			TEMPORARY SILT FENCE AND TREE PROTECTION
			TEMPORARY TREE PROTECTION
			STONE OPENING IN TEMPORARY SILT FENCE
			SUPER SILT FENCE
			PROPOSED LIMIT OF DISTURBANCE
			PROPOSED SLOPE AND CHANNEL LINING
			PROPOSED RIPRAP APRON

CONSTRUCTION SEQUENCE

1. SCHEDULE A PRECONSTRUCTION CONFERENCE WITH THE WAKE COUNTY ENVIRONMENTAL CONSULTANT. OBTAIN A LAND DISTURBING PERMIT.
2. INSTALL GRAVEL CONSTRUCTION ENTRANCE, TEMPORARY DIVERSIONS, AND SILT FENCE AS SHOWN ON THE APPROVED PLAN. CLEAR ONLY AS NECESSARY TO INSTALL THESE DEVICES. SEED TEMPORARY DIVERSIONS AND BERMS IMMEDIATELY AFTER CONSTRUCTION.
3. CALL WAKE COUNTY ENVIRONMENTAL CONSULTANT FOR AN ONSITE INSPECTION BY THE ENVIRONMENTAL CONSULTANT TO OBTAIN A CERTIFICATE OF COMPLIANCE.
4. BEGIN CLEARING AND GRUBBING. MAINTAIN DEVICES AS NEEDED. ROUGH GRADE SITE.
5. INSTALL STORM SEWER AND PROTECT INLETS WITH BLOCK AND GRAVEL INLET CONTROLS AS SHOWN ON THE PLAN. BEGIN CONSTRUCTION, BUILDING, ETC.
6. STABILIZE SITE AS AREAS ARE BROUGHT UP TO FINISH GRADE WITH VEGETATION, PAVING, DITCH LININGS, ETC. SEED AND MULCH DENUDEED AREAS PER GROUND STABILIZATION TIME FRAMES.
7. WHEN CONSTRUCTION IS COMPLETE AND ALL AREAS ARE STABILIZED COMPLETELY, CALL ENVIRONMENTAL CONSULTANT FOR AN INSPECTION.
8. IF SITE IS APPROVED, REMOVE TEMPORARY DIVERSIONS, SILT FENCE, SEDIMENT BASINS, ETC., AND SEED OUT OR STABILIZE ANY RESULTING BARE AREAS. ALL REMAINING PERMANENT EROSION CONTROL DEVICES, SUCH AS VELOCITY DISSIPATORS, SHOULD NOW BE INSTALLED.
9. WHEN VEGETATION HAS BECOME ESTABLISHED, CALL FOR A FINAL SITE INSPECTION BY THE ENVIRONMENTAL CONSULTANT. OBTAIN A CERTIFICATE OF COMPLETION.

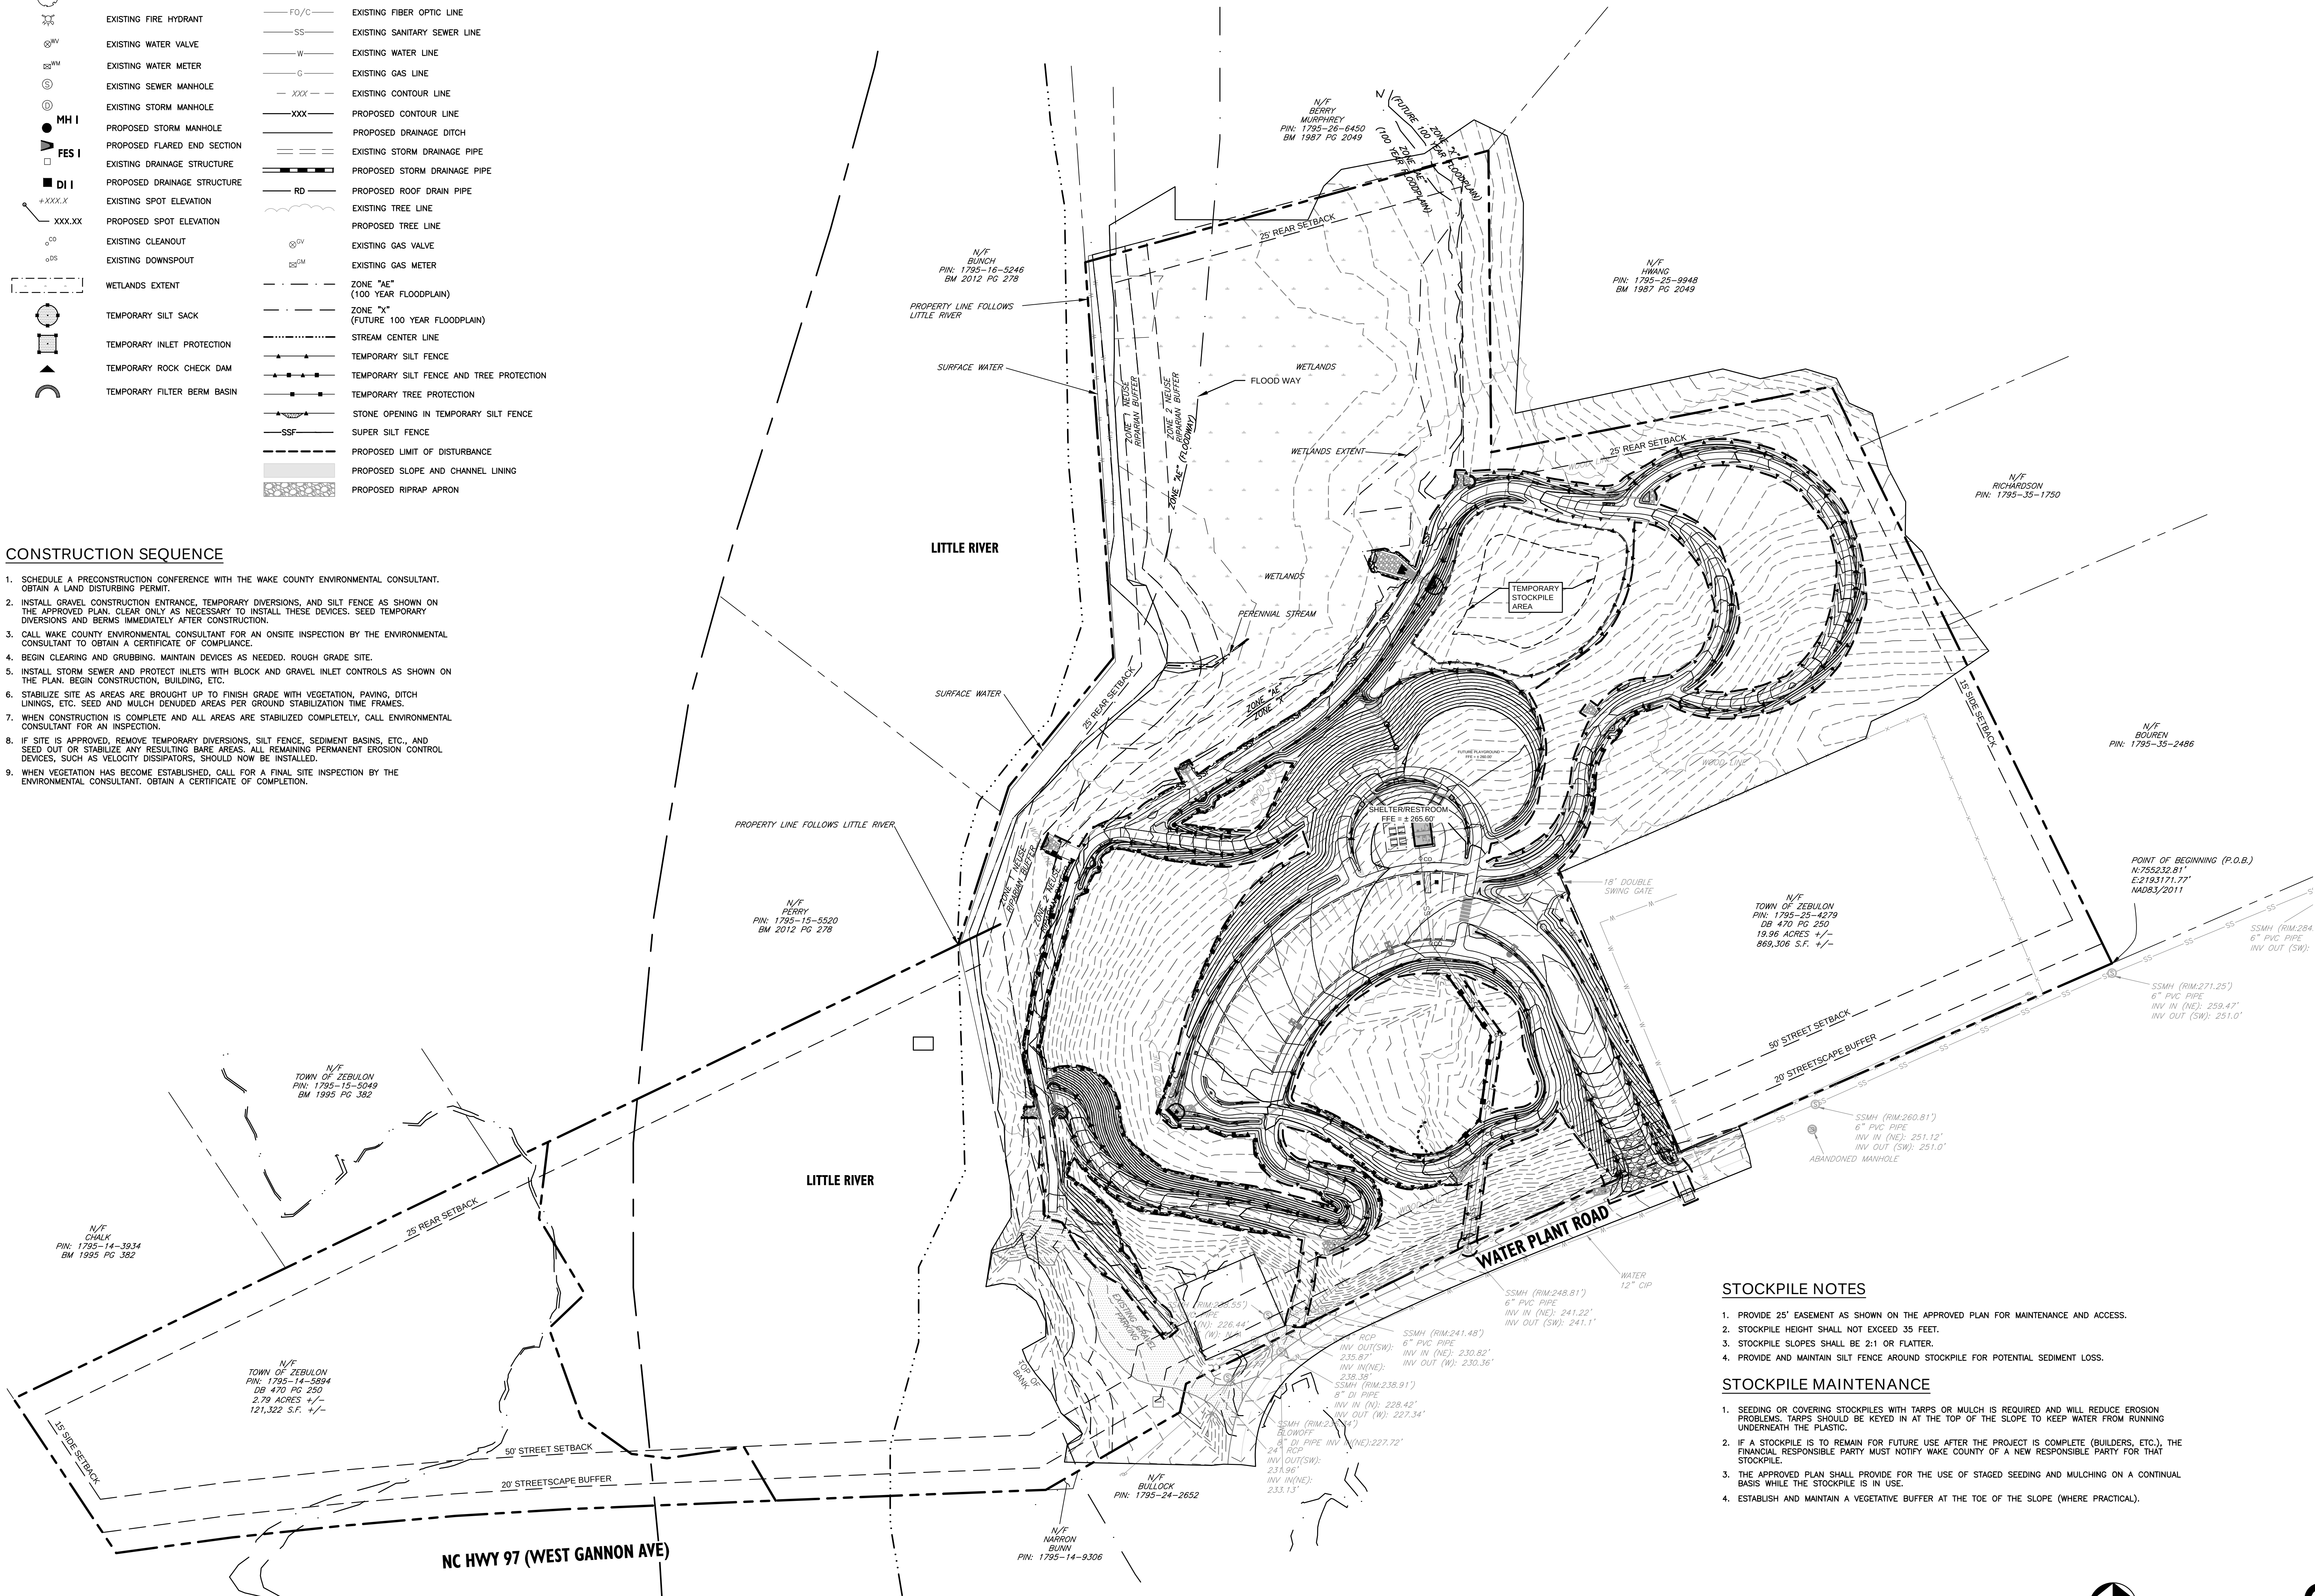


STOCKPILE NOTES

1. PROVIDE 25' EASEMENT AS SHOWN ON THE APPROVED PLAN FOR MAINTENANCE AND ACCESS.
2. STOCKPILE HEIGHT SHALL NOT EXCEED 35 FEET.
3. STOCKPILE SLOPES SHALL BE 2:1 OR FLATTER.
4. PROVIDE AND MAINTAIN SILT FENCE AROUND STOCKPILE FOR POTENTIAL SEDIMENT LOSS.

STOCKPILE MAINTENANCE

1. SEEDING OR COVERING STOCKPILES WITH TARPS OR MULCH IS REQUIRED AND WILL REDUCE EROSION. PROBLEMATIC TARPS SHOULD BE KEYED IN AT THE TOP OF THE SLOPE TO KEEP WATER FROM RUNNING UNDERNEATH THE PLASTIC.
2. IF A STOCKPILE IS TO REMAIN FOR FUTURE USE AFTER THE PROJECT IS COMPLETE (BUILDERS, ETC.), THE FINANCIAL RESPONSIBLE PARTY MUST NOTIFY WAKE COUNTY OF A NEW RESPONSIBLE PARTY FOR THAT STOCKPILE.
3. THE APPROVED PLAN SHALL PROVIDE FOR THE USE OF STAGED SEEDING AND MULCHING ON A CONTINUAL BASIS WHILE THE STOCKPILE IS IN USE.
4. ESTABLISH AND MAINTAIN A VEGETATIVE BUFFER AT THE TOE OF THE SLOPE (WHERE PRACTICAL).

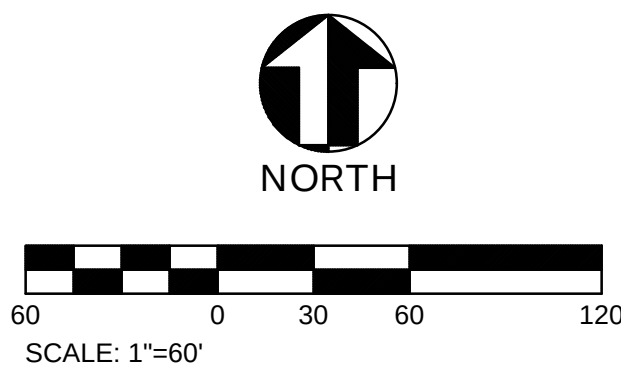

Seals:



Corp. NC License: F-1320

LITTLE RIVER PARK


1800 WEST GANNON AVENUE
ZEBULON, NORTH CAROLINA

Project No: 1725-500672.00
Date: 4.18.25
Revisions:

Sheet Title:
**OVERALL
EROSION
CONTROL PLAN**

Sheet No:
C300

Y:\North Carolina\TXS\05\1715-500672-00_Zebulon_Land_Survey\Drawings\1715-500672-00_EROSION CONTROL PLAN.dwg
V:\North Carolina\TXS\05\1715-500672-00_Zebulon_Land_Survey\Drawings\1715-500672-00_EROSION CONTROL PLAN.dwg

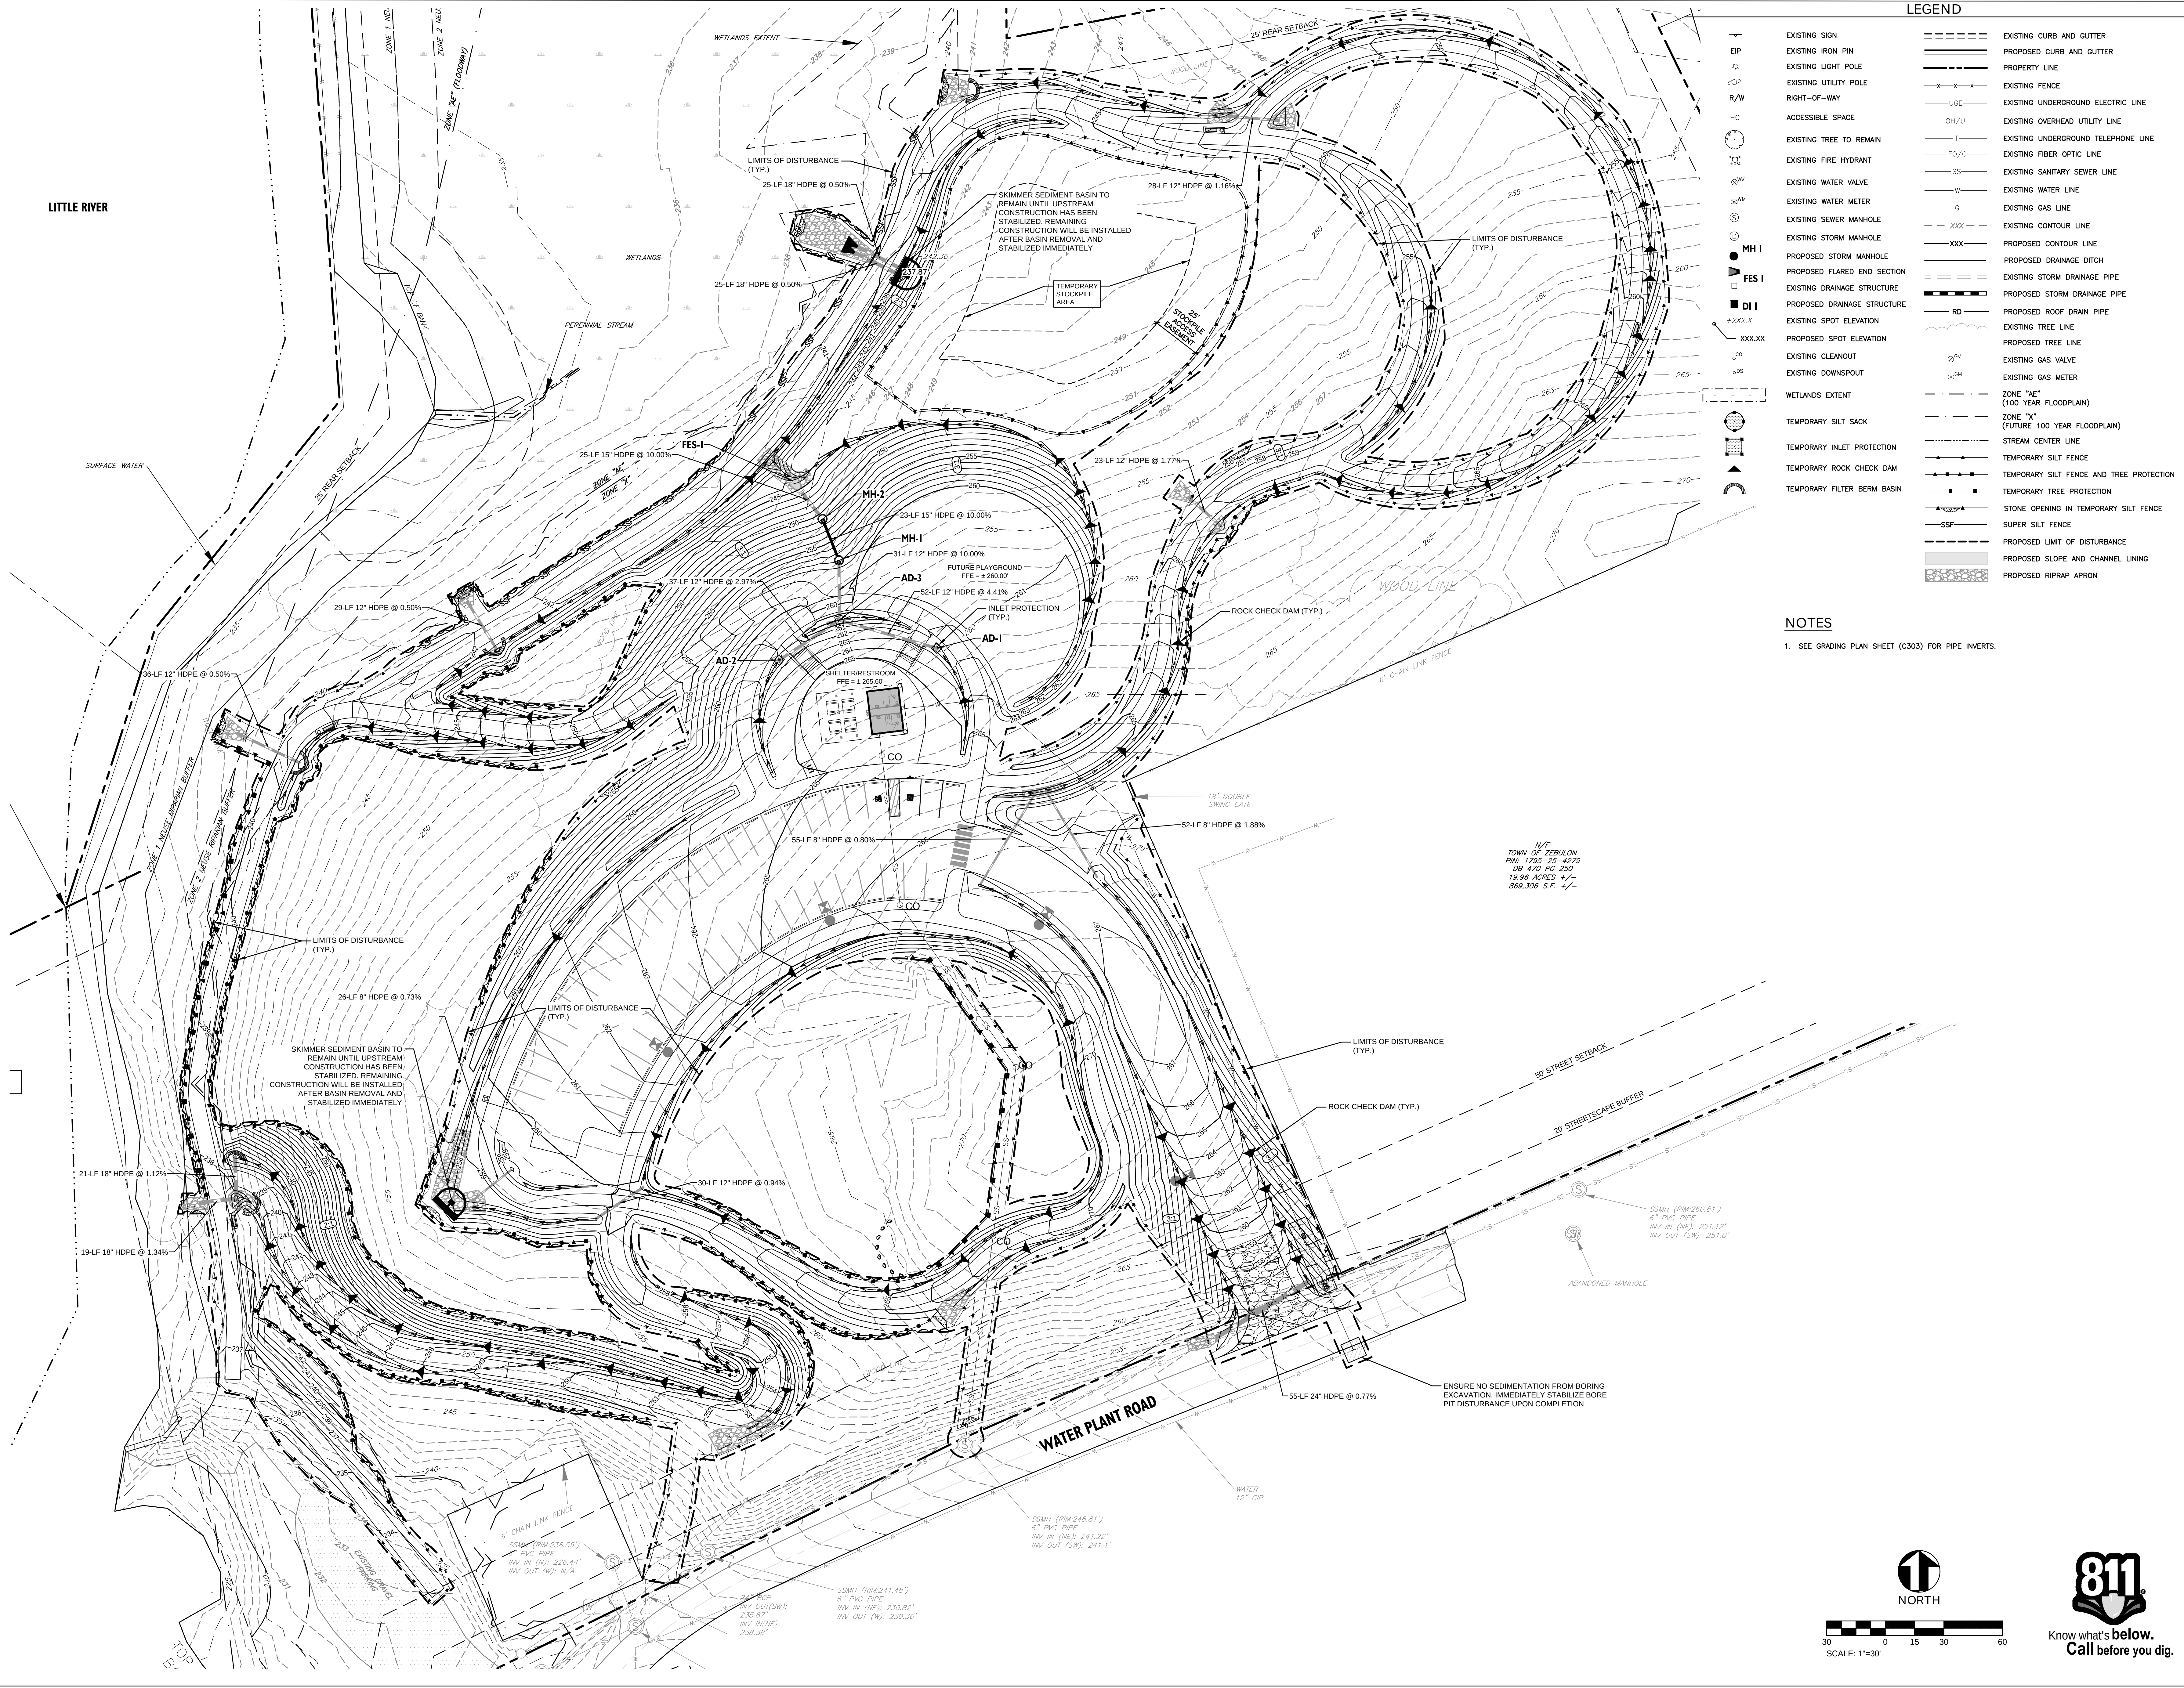

LEGEND

- | | |
|-----------------------------|--|
| EXISTING SIGN | EXISTING CURB AND GUTTER |
| EXISTING IRON PIN | PROPOSED CURB AND GUTTER |
| EXISTING LIGHT POLE | PROPERTY LINE |
| EXISTING UTILITY POLE | EXISTING FENCE |
| RIGHT-OF-WAY | EXISTING UNDERGROUND ELECTRIC LINE |
| ACCESSIBLE SPACE | EXISTING OVERHEAD UTILITY LINE |
| EXISTING TREE TO REMAIN | EXISTING UNDERGROUND TELEPHONE LINE |
| EXISTING FIRE HYDRANT | EXISTING FIBER OPTIC LINE |
| EXISTING WATER VALVE | EXISTING SANITARY SEWER LINE |
| EXISTING WATER METER | EXISTING WATER LINE |
| EXISTING SEWER MANHOLE | EXISTING GAS LINE |
| EXISTING STORM MANHOLE | EXISTING CONTOUR LINE |
| PROPOSED STORM MANHOLE | PROPOSED CONTOUR LINE |
| PROPOSED FLARED END SECTION | PROPOSED DRAINAGE DITCH |
| EXISTING DRAINAGE STRUCTURE | EXISTING STORM DRAINAGE PIPE |
| PROPOSED DRAINAGE STRUCTURE | PROPOSED STORM DRAINAGE PIPE |
| EXISTING SPOT ELEVATION | PROPOSED ROOF DRAIN PIPE |
| PROPOSED SPOT ELEVATION | EXISTING TREE LINE |
| EXISTING CLEANOUT | PROPOSED TREE LINE |
| EXISTING DOWNSPOUT | EXISTING GAS VALVE |
| WETLANDS EXTENT | EXISTING GAS METER |
| TEMPORARY SILT SACK | ZONE "AE" (100 YEAR FLOODPLAIN) |
| TEMPORARY INLET PROTECTION | ZONE "X" (FUTURE 100 YEAR FLOODPLAIN) |
| TEMPORARY ROCK CHECK DAM | STREAM CENTER LINE |
| TEMPORARY FILTER BERM BASIN | TEMPORARY SILT FENCE |
| | TEMPORARY SILT FENCE AND TREE PROTECTION |
| | TEMPORARY TREE PROTECTION |
| | STONE OPENING IN TEMPORARY SILT FENCE |
| | SUPER SILT FENCE |
| | PROPOSED LIMIT OF DISTURBANCE |
| | PROPOSED SLOPE AND CHANNEL LINING |
| | PROPOSED RIPRAP APRON |

NOTES

- SEE GRADING PLAN SHEET (C303) FOR PIPE INVERTS.



Seals:




Corp. NC License: F-1320

LITTLE RIVER PARK
1800 WEST GANNON AVENUE
ZEBULON, NORTH CAROLINA

Project No: 1725-500672.00
Date: 4.18.25
Revisions:



Sheet Title:
EROSION
CONTROL PLAN
PHASE 2

Sheet No:
C302

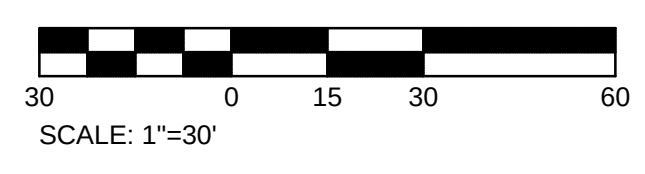


Know what's below.
Call before you dig.

Y:\North Carolina\TXS\051715-500672-00_Zebulon_Little_River_Park_DWG\Drawings\1715-500672-00 GRADING PLAN.dwg

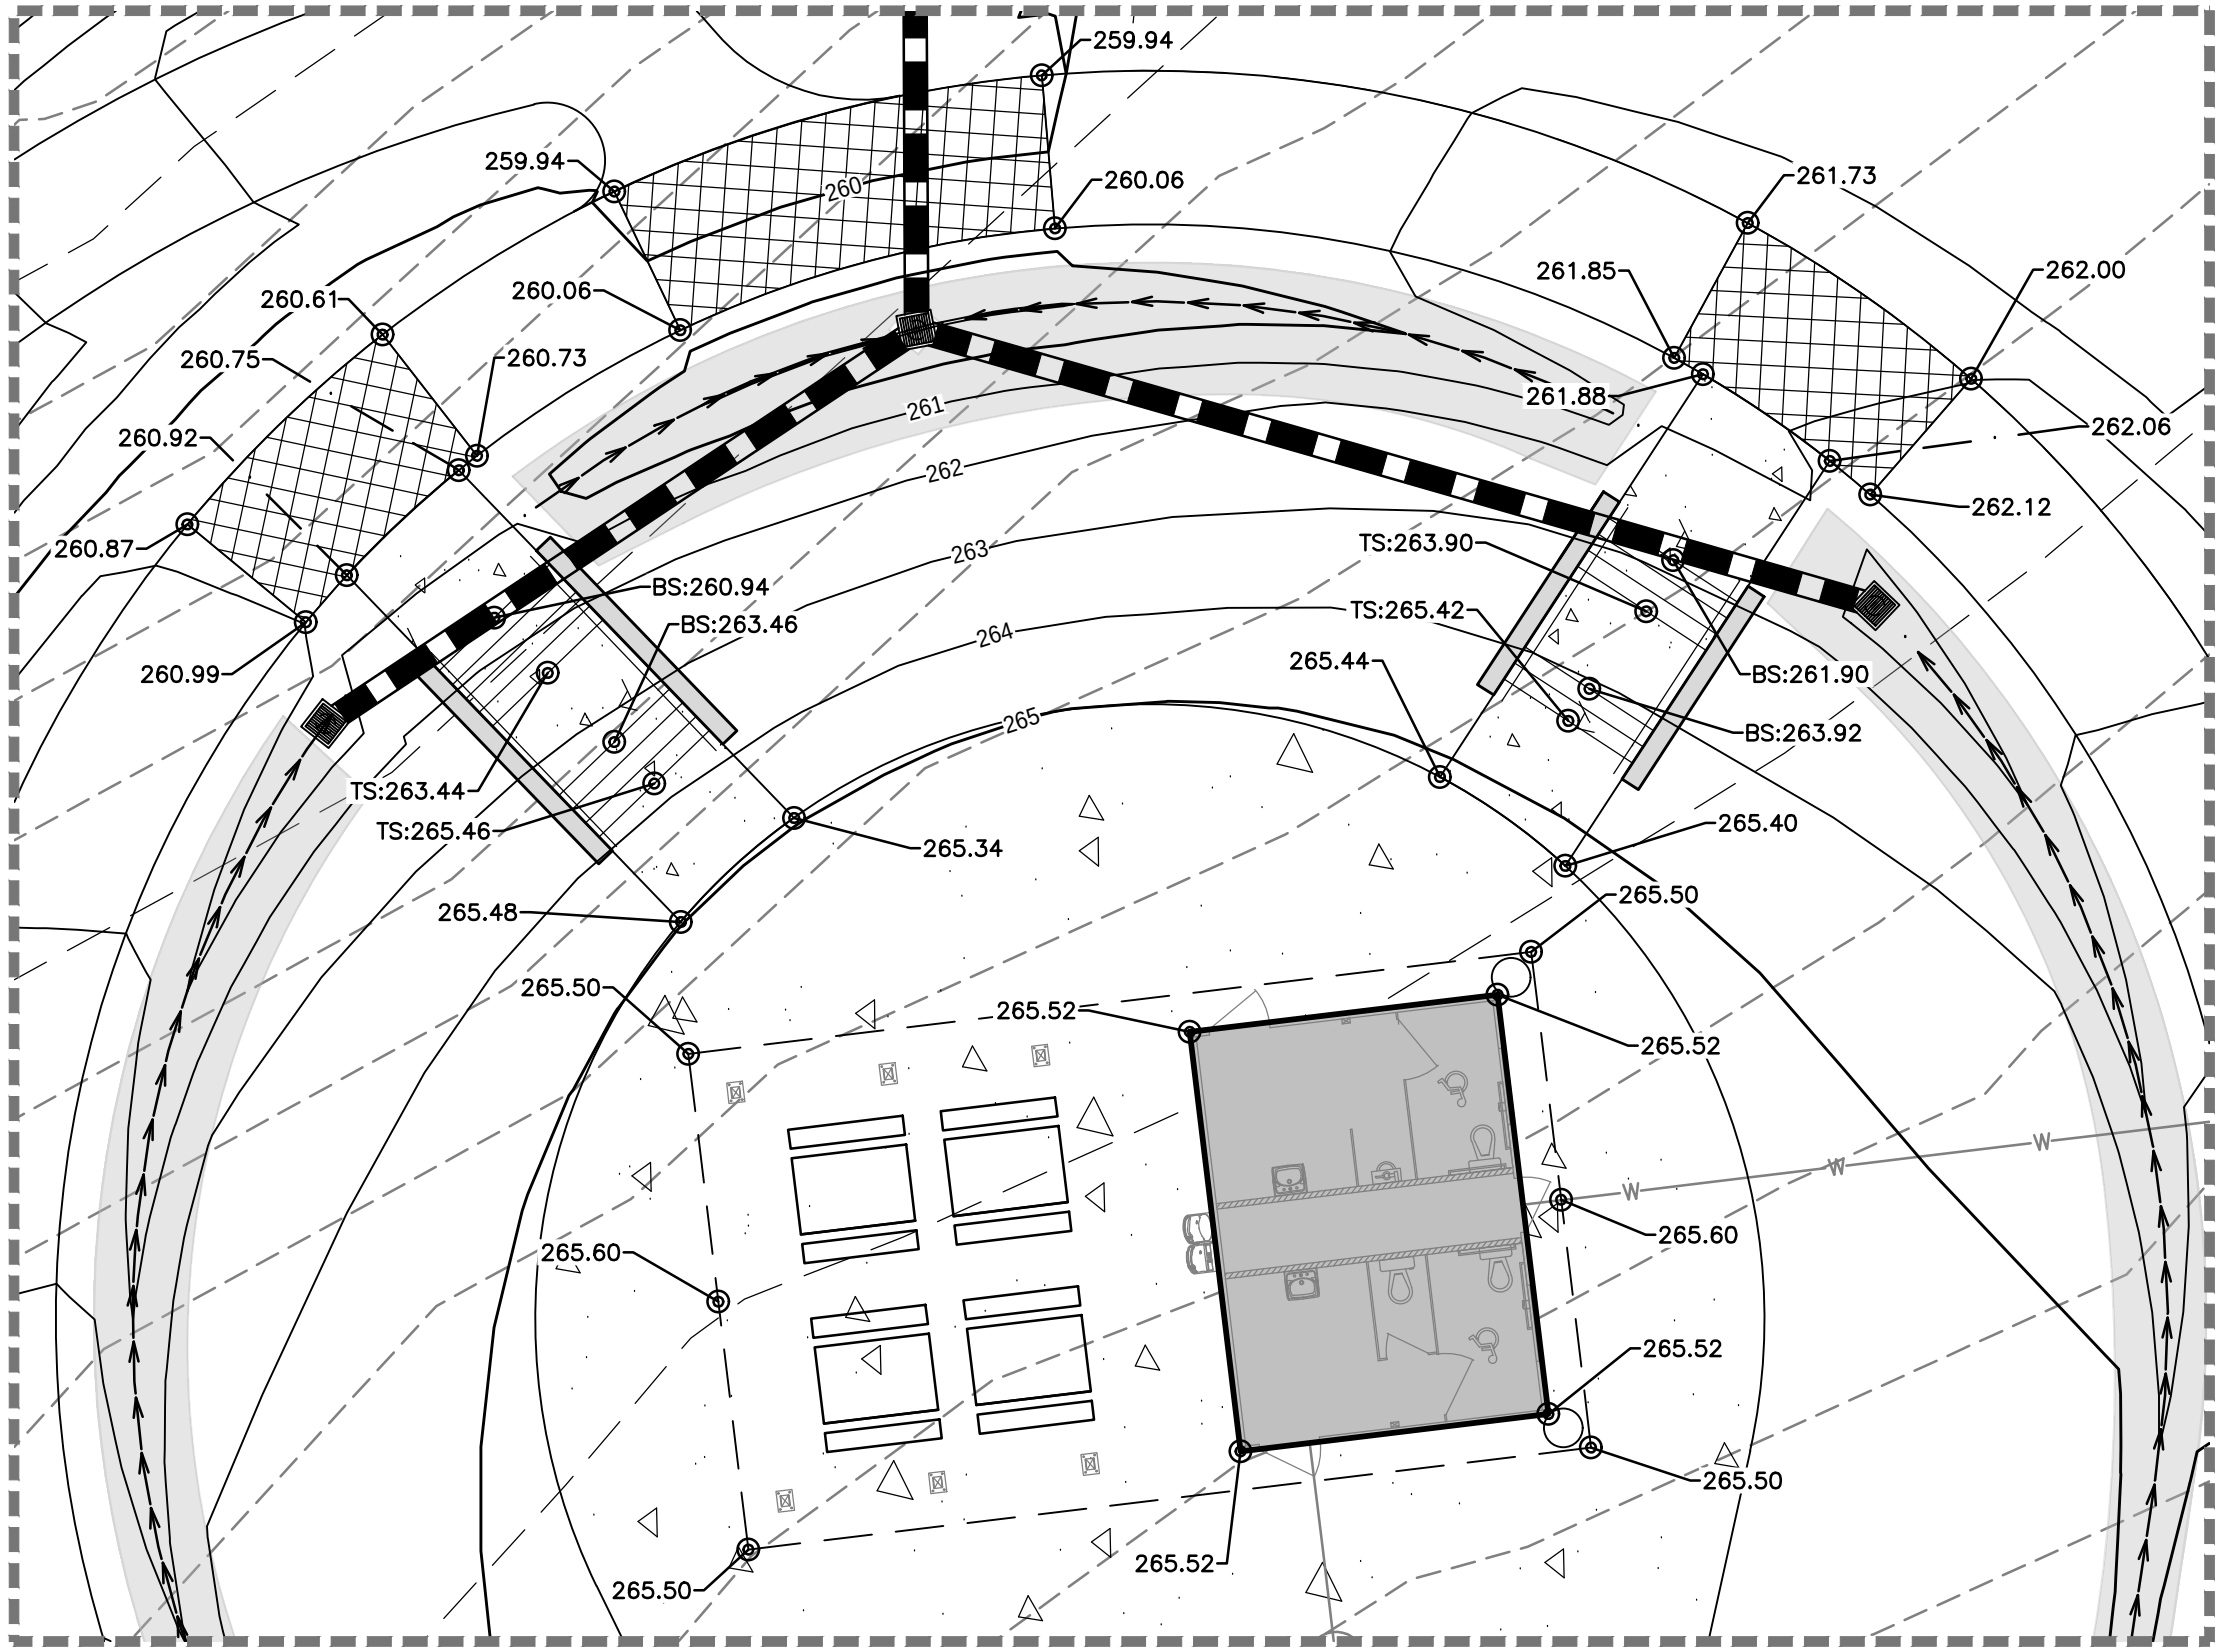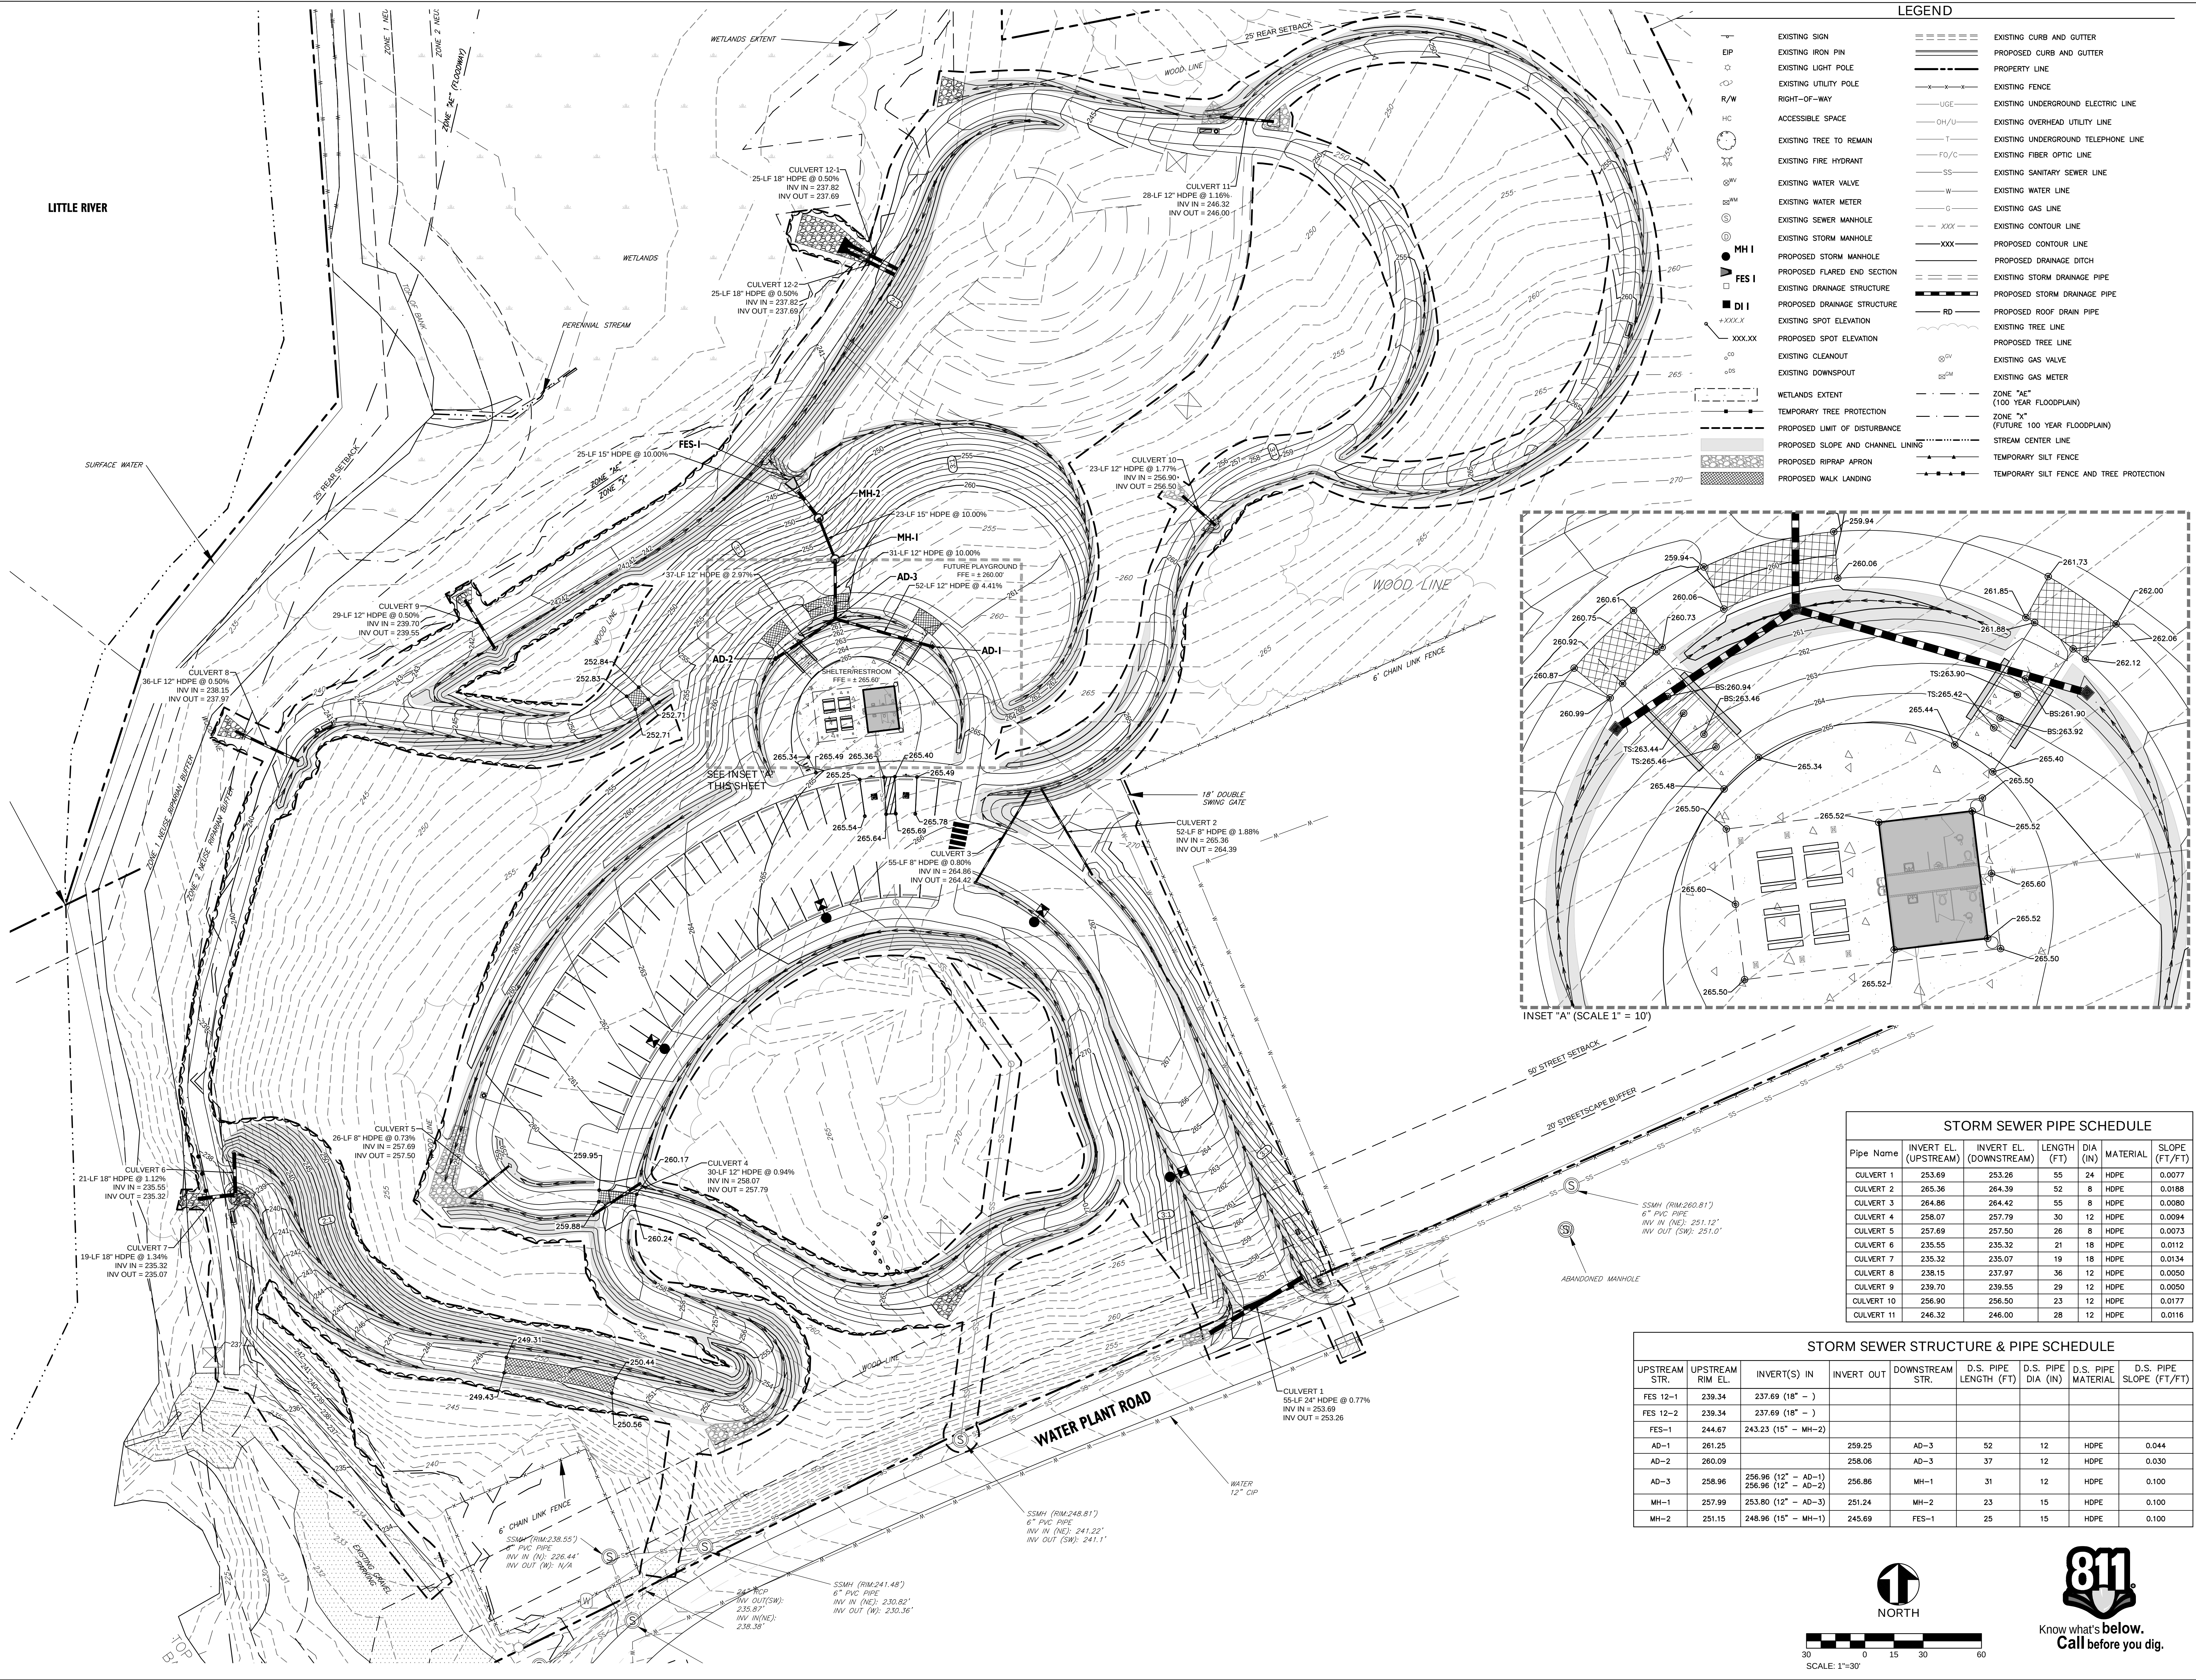

STORM SEWER PIPE SCHEDULE						
Pipe Name	INVERT EL. (UPSTREAM)	INVERT EL. (DOWNSTREAM)	LENGTH (FT)	DIA (IN)	MATERIAL	SLOPE (FT/FT)
CULVERT 1	253.69	253.26	55	24	HDPE	0.0077
CULVERT 2	265.36	264.39	52	8	HDPE	0.0188
CULVERT 3	264.86	264.42	55	8	HDPE	0.0080
CULVERT 4	258.07	257.79	30	12	HDPE	0.0094
CULVERT 5	257.69	257.50	26	8	HDPE	0.0073
CULVERT 6	235.55	235.32	21	18	HDPE	0.0112
CULVERT 7	235.32	235.07	19	18	HDPE	0.0134
CULVERT 8	238.15	237.97	36	12	HDPE	0.0050
CULVERT 9	239.70	239.55	29	12	HDPE	0.0050
CULVERT 10	256.90	256.50	23	12	HDPE	0.0177
CULVERT 11	246.32	246.00	28	12	HDPE	0.0116

STORM SEWER STRUCTURE & PIPE SCHEDULE								
UPSTREAM STR.	UPSTREAM RIM EL.	INVERT(S) IN	INVERT OUT	DOWNSTREAM STR.	D.S. PIPE LENGTH (FT)	D.S. PIPE DIA (IN)	D.S. PIPE MATERIAL	D.S. PIPE SLOPE (FT/FT)
FES 12-1	239.34	237.69 (18" -)						
FES 12-2	239.34	237.69 (18" -)						
FES-1	244.67	243.23 (15" - MH-2)						
AD-1	261.25		259.25	AD-3	52	12	HDPE	0.044
AD-2	260.09		258.06	AD-3	37	12	HDPE	0.030
AD-3	258.96	256.96 (12" - AD-1) 256.96 (12" - AD-2)	256.86	MH-1	31	12	HDPE	0.100
MH-1	257.99	253.80 (12" - AD-3)	251.24	MH-2	23	15	HDPE	0.100
MH-2	251.15	248.96 (15" - MH-1)	245.69	FES-1	25	15	HDPE	0.100

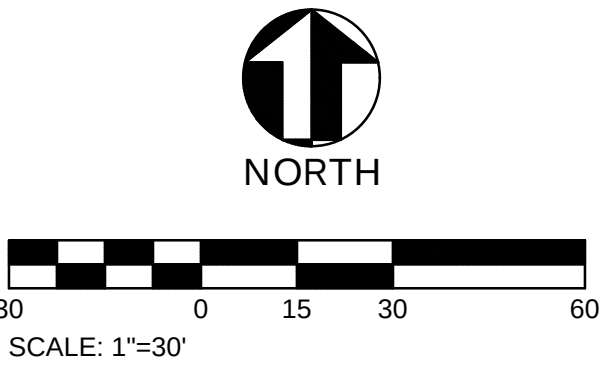

- LEGEND**
- | | |
|-----------------------------------|--|
| EXISTING SIGN | EXISTING CURB AND GUTTER |
| EXISTING IRON PIN | PROPOSED CURB AND GUTTER |
| EXISTING LIGHT POLE | PROPERTY LINE |
| EXISTING UTILITY POLE | EXISTING FENCE |
| RIGHT-OF-WAY | EXISTING UNDERGROUND ELECTRIC LINE |
| ACCESSIBLE SPACE | EXISTING OVERHEAD UTILITY LINE |
| EXISTING TREE TO REMAIN | EXISTING UNDERGROUND TELEPHONE LINE |
| EXISTING FIRE HYDRANT | EXISTING FIBER OPTIC LINE |
| EXISTING WATER VALVE | EXISTING SANITARY SEWER LINE |
| EXISTING WATER METER | EXISTING WATER LINE |
| EXISTING SEWER MANHOLE | EXISTING GAS LINE |
| EXISTING STORM MANHOLE | EXISTING CONTOUR LINE |
| PROPOSED STORM MANHOLE | PROPOSED CONTOUR LINE |
| PROPOSED FLARED END SECTION | PROPOSED DRAINAGE DITCH |
| EXISTING DRAINAGE STRUCTURE | EXISTING STORM DRAINAGE PIPE |
| PROPOSED DRAINAGE STRUCTURE | PROPOSED STORM DRAINAGE PIPE |
| EXISTING SPOT ELEVATION | PROPOSED ROOF DRAIN PIPE |
| PROPOSED SPOT ELEVATION | EXISTING TREE LINE |
| EXISTING CLEANOUT | PROPOSED TREE LINE |
| EXISTING DOWNSPOUT | EXISTING GAS VALVE |
| WETLANDS EXTENT | EXISTING GAS METER |
| TEMPORARY TREE PROTECTION | ZONE "AE" (100 YEAR FLOODPLAIN) |
| PROPOSED LIMIT OF DISTURBANCE | ZONE "X" (FUTURE 100 YEAR FLOODPLAIN) |
| PROPOSED SLOPE AND CHANNEL LINING | STREAM CENTER LINE |
| PROPOSED RIPRAP APRON | TEMPORARY SILT FENCE |
| PROPOSED WALK LANDING | TEMPORARY SILT FENCE AND TREE PROTECTION |



Seals:



Corp. NC License: F-1320

LITTLE RIVER PARK
1800 WEST GANNON AVENUE
ZEBULON, NORTH CAROLINA

Project No: 1725-500672.00
Date: 4.18.25
Revisions:


Sheet Title:
**GRADING PLAN
ENLARGEMENT**

Sheet No:
C304

Y:\North Carolina\1705-50672\1705-50672-00_Zebulon_Utility_Plan.dwg
V:\North Carolina\1705-50672\1705-50672-00_Zebulon_Utility_Plan.dwg

LEGEND

	EXISTING SIGN		EXISTING CURB AND GUTTER
	EXISTING IRON PIN		PROPOSED CURB AND GUTTER
	EXISTING LIGHT POLE		PROPERTY LINE
	EXISTING UTILITY POLE		EXISTING FENCE
	RIGHT-OF-WAY		EXISTING UNDERGROUND ELECTRIC LINE
	ACCESSIBLE SPACE		EXISTING OVERHEAD UTILITY LINE
	EXISTING TREE TO REMAIN		EXISTING UNDERGROUND TELEPHONE LINE
	EXISTING FIRE HYDRANT		EXISTING FIBER OPTIC LINE
	EXISTING WATER VALVE		EXISTING SANITARY SEWER LINE
	EXISTING WATER METER		EXISTING WATER LINE
	EXISTING SEWER MANHOLE		EXISTING GAS LINE
	EXISTING STORM MANHOLE		EXISTING CONTOUR LINE
	PROPOSED STORM MANHOLE		PROPOSED CONTOUR LINE
	PROPOSED FLARED END SECTION		TEMPORARY TREE PROTECTION BARRICADE
	EXISTING DRAINAGE STRUCTURE		EXISTING STORM DRAINAGE PIPE
	PROPOSED DRAINAGE STRUCTURE		PROPOSED STORM DRAINAGE PIPE
	EXISTING SPOT ELEVATION		PROPOSED ROOF DRAIN PIPE
	PROPOSED SPOT ELEVATION		EXISTING TREE LINE
	EXISTING CLEANOUT		EXISTING GAS VALVE
	EXISTING DOWNSPOUT		EXISTING GAS METER
	WETLANDS EXTENT		ZONE "AE" (100 YEAR FLOODPLAIN)
			ZONE "X" (FUTURE 100 YEAR FLOODPLAIN)
			STREAM CENTER LINE

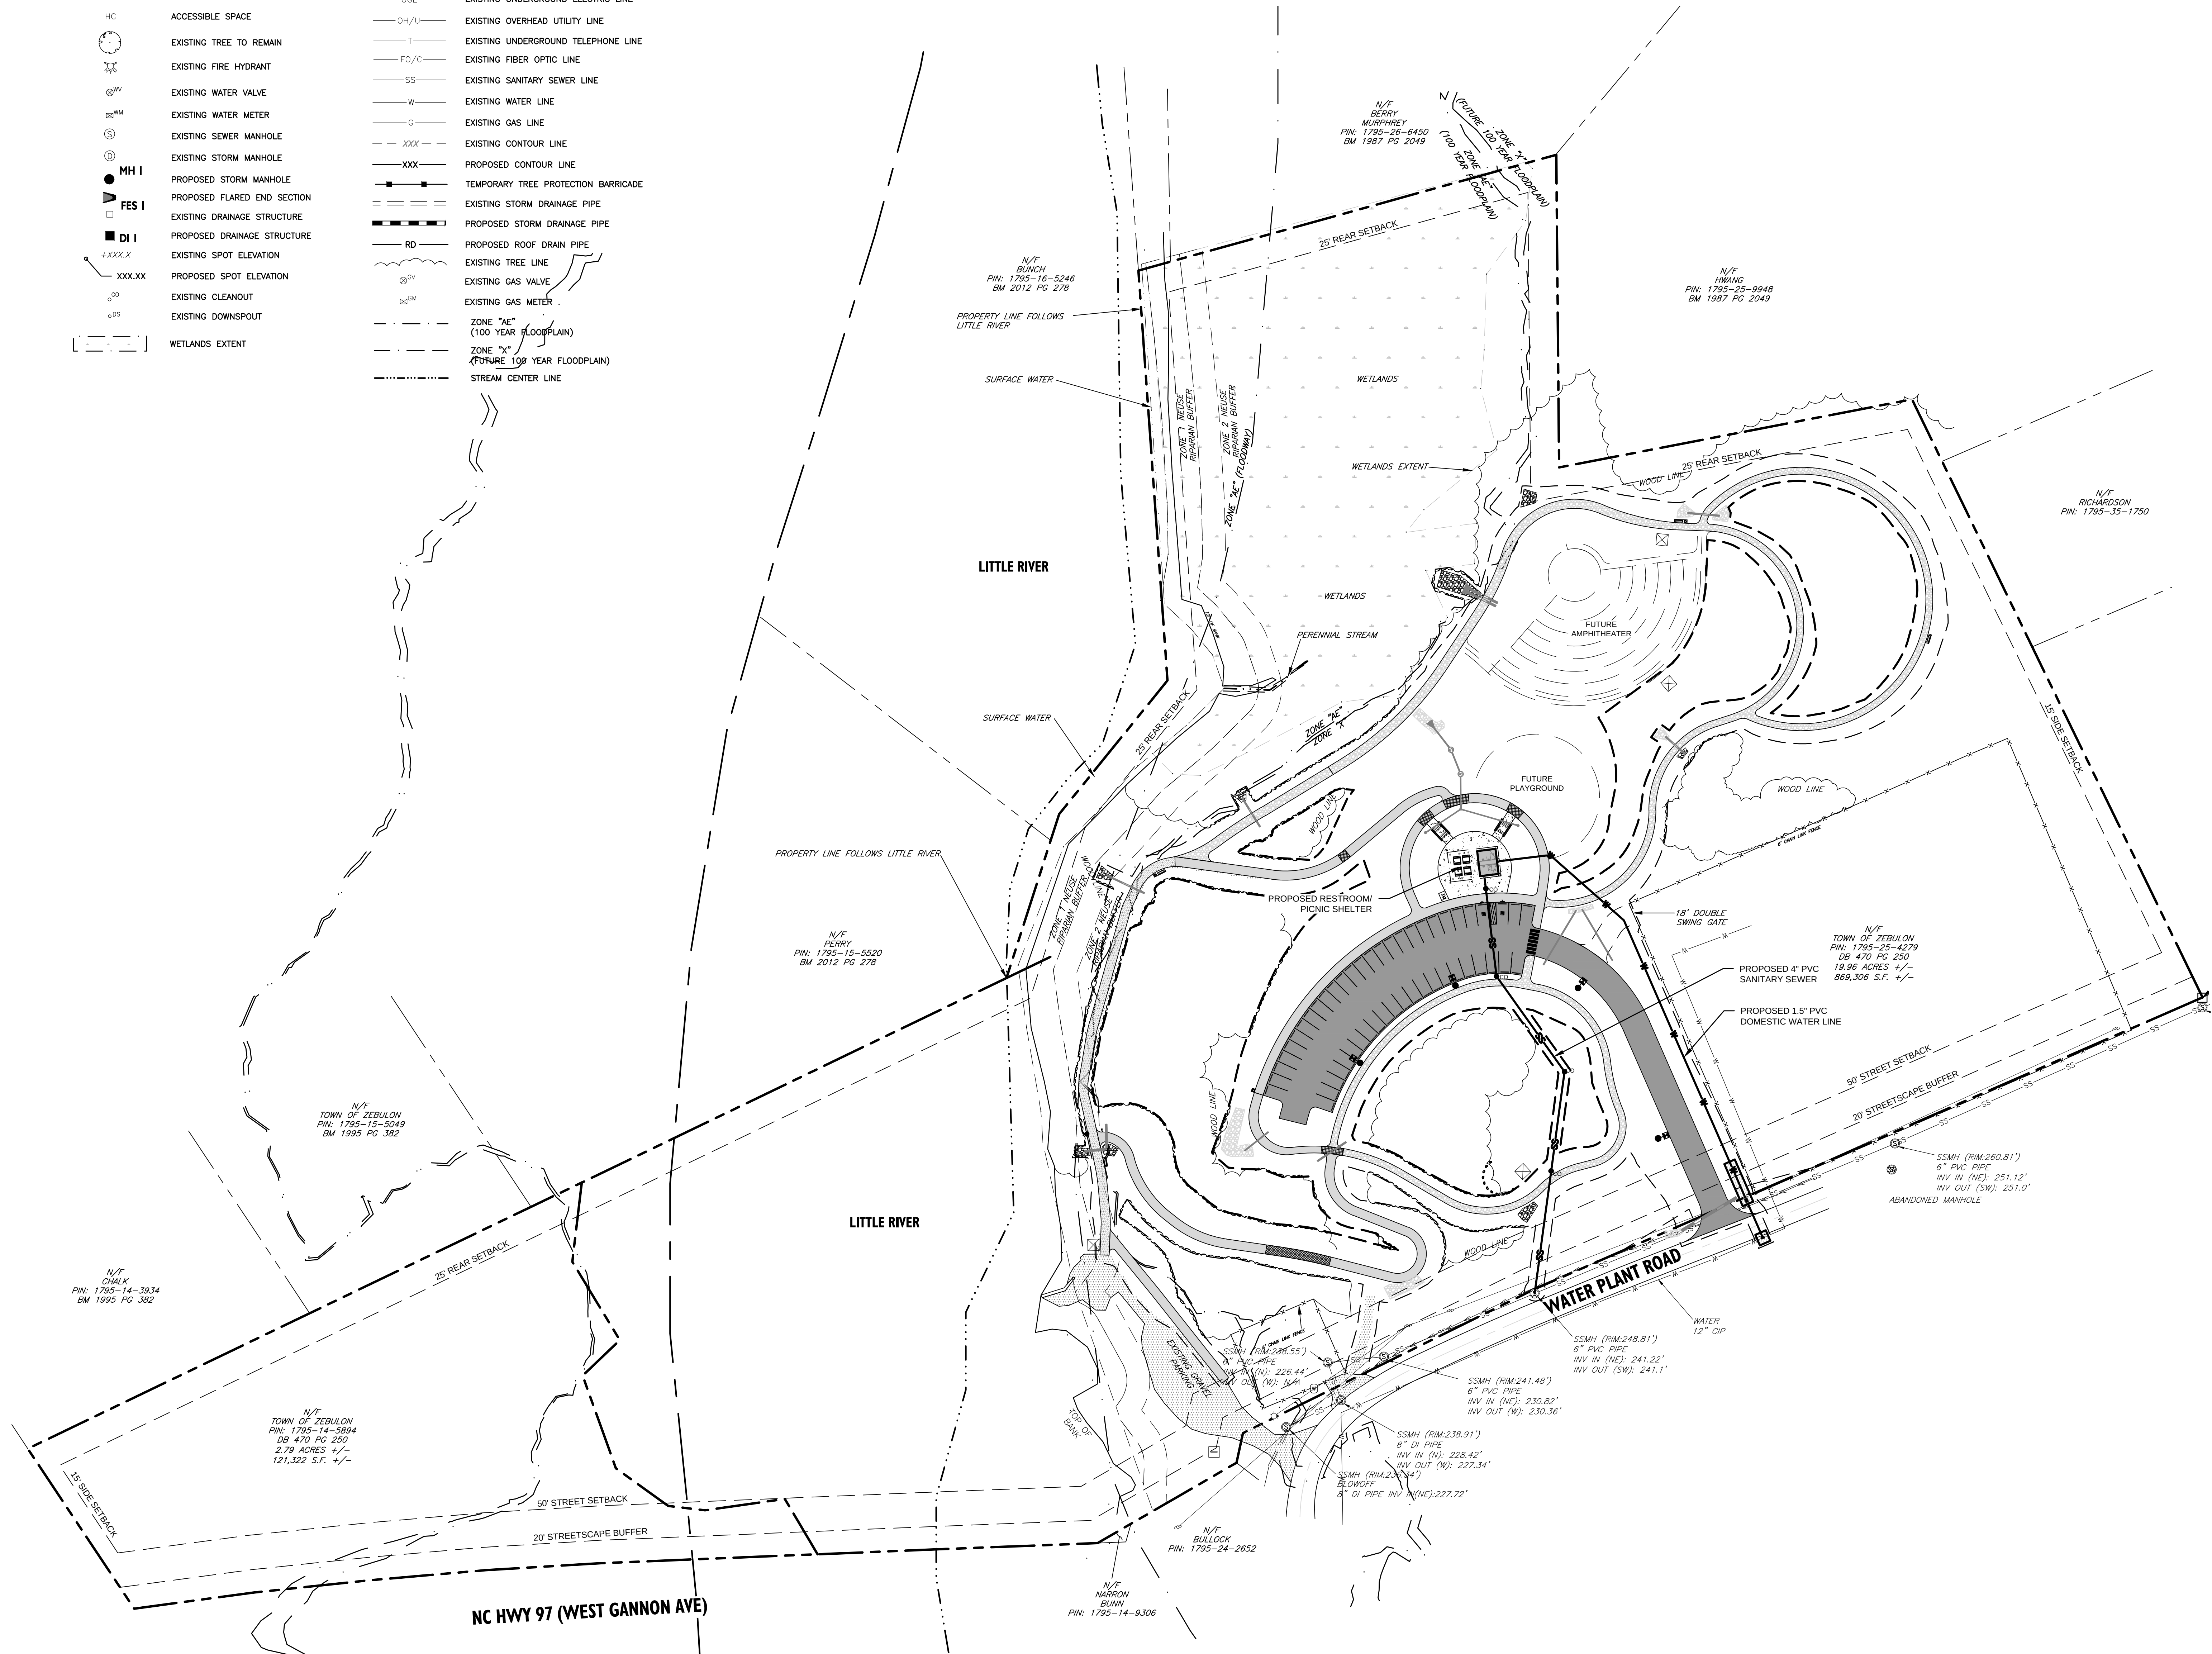

UTILITY NOTES

- UTILITY CONSTRUCTION SHALL BE IN ACCORDANCE WITH ALL APPLICABLE LOCAL AND STATE CODE REQUIREMENTS.
- THE CONTRACTOR SHALL BE RESPONSIBLE FOR VERIFYING THE LOCATION OF ALL EXISTING UNDERGROUND UTILITIES (STORM DRAINAGE, ELECTRIC, GAS, TELEPHONE, ETC.) PRIOR TO CONSTRUCTION. INFORMATION SHOWN ON THIS PLAN IS FOR REFERENCE ONLY AND SHALL BE FIELD VERIFIED BY THE CONTRACTOR.
- THE CONTRACTOR SHALL NOTIFY THE ARCHITECT/ENGINEER IMMEDIATELY IF ANY DISCREPANCIES BETWEEN THE CONSTRUCTION PLANS AND ACTUAL FIELD CONDITIONS ARE FOUND.
- MINIMUM COVER FOR ALL SANITARY SEWER MAINS SHALL BE 3'-0". DUCTILE IRON PIPE SHALL BE SUBSTITUTED WHEN MINIMUM COVER CAN NOT BE MAINTAINED.
- THE STANDARD DEPTH OF COVER FOR WATER MAINS SHALL BE 3'-0" MIN. EXCEPT AT VALVE OR HYDRANT LOCATIONS, OR OTHER SPECIAL CONDITIONS.
- THE CONNECTION TO EXISTING WATER MAINS SHALL BE PERFORMED ONLY AFTER ALL PRESSURE TESTING AND CHLORINATION ARE SUCCESSFULLY COMPLETED AND THE LOCAL REVIEW AUTHORITY HAS APPROVED THE CONNECTION. THE CONTRACTOR SHALL AVOID DISRUPTION OF EXISTING SERVICE.
- REFER TO PLUMBING DRAWING SERIES FOR THE LOCATION OF WATER AND SANITARY SEWER SERVICE CONNECTIONS AT THE BUILDING.
- UNLESS OTHERWISE NOTED, THE PHYSICAL CONNECTION BETWEEN THE SITE UTILITY LINES AND THE PIPE INSTALLED BY THE PLUMBING CONTRACTOR SHALL BE MADE BY THE SITE UTILITY CONTRACTOR.
- PIPE LENGTHS SHOWN ON PLAN ARE THE ENGINEER'S ESTIMATE USED TO COMPUTE PIPE SLOPES AND INVERTS AND SHALL NOT BE CONSTRUED BY THE CONTRACTOR TO REPRESENT THE ACTUAL QUANTITY OF PIPE REQUIRED.
- 10' HORIZONTAL SEPARATION SHALL BE MAINTAINED BETWEEN WATER AND SANITARY SEWER LINES.
- 12' VERTICAL SEPARATION SHALL BE PROVIDED BETWEEN STORM SEWER AND SANITARY SEWER LINES OR DIP SPECIFIED 10' EACH DIRECTION.
- 12' VERTICAL SEPARATION SHALL BE PROVIDED BETWEEN WATER (OVER) AND SANITARY SEWER LINES (UNDER) AT CROSSINGS OR DIP SPECIFIED 10' EACH DIRECTION.
- ALL PROPOSED WATER AND SEWER PIPES AND STRUCTURES TO BE INSTALLED PER CURRENT TOWN OF ZEBULON AND CITY OF RALEIGH PUBLIC UTILITIES CURRENT STANDARDS AND SPECIFICATIONS.



Seals:



Corp. NC License: F-1320

LITTLE RIVER PARK

1800 WEST GANNON AVENUE
ZEBULON, NORTH CAROLINA

Project No: 1725-500672.00

Date: 4.18.25


Revisions:

Sheet Title:


OVERALL
UTILITY
PLAN

Sheet No:

C400

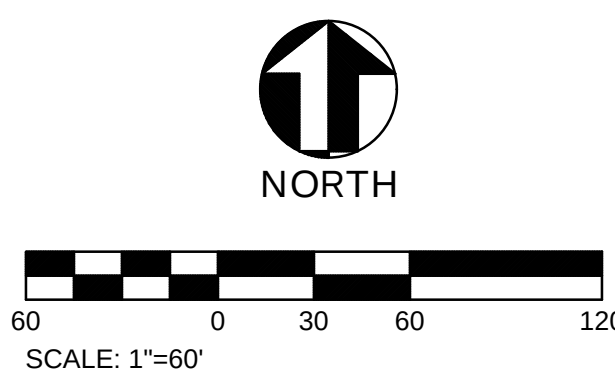

Y:\North Carolina\TXS\05\1715-500672-00_Zebulon_Utility_Plans\Drawings\1715-500672-00-CD\1715-500672-00-UTILITY PLANS.dwg

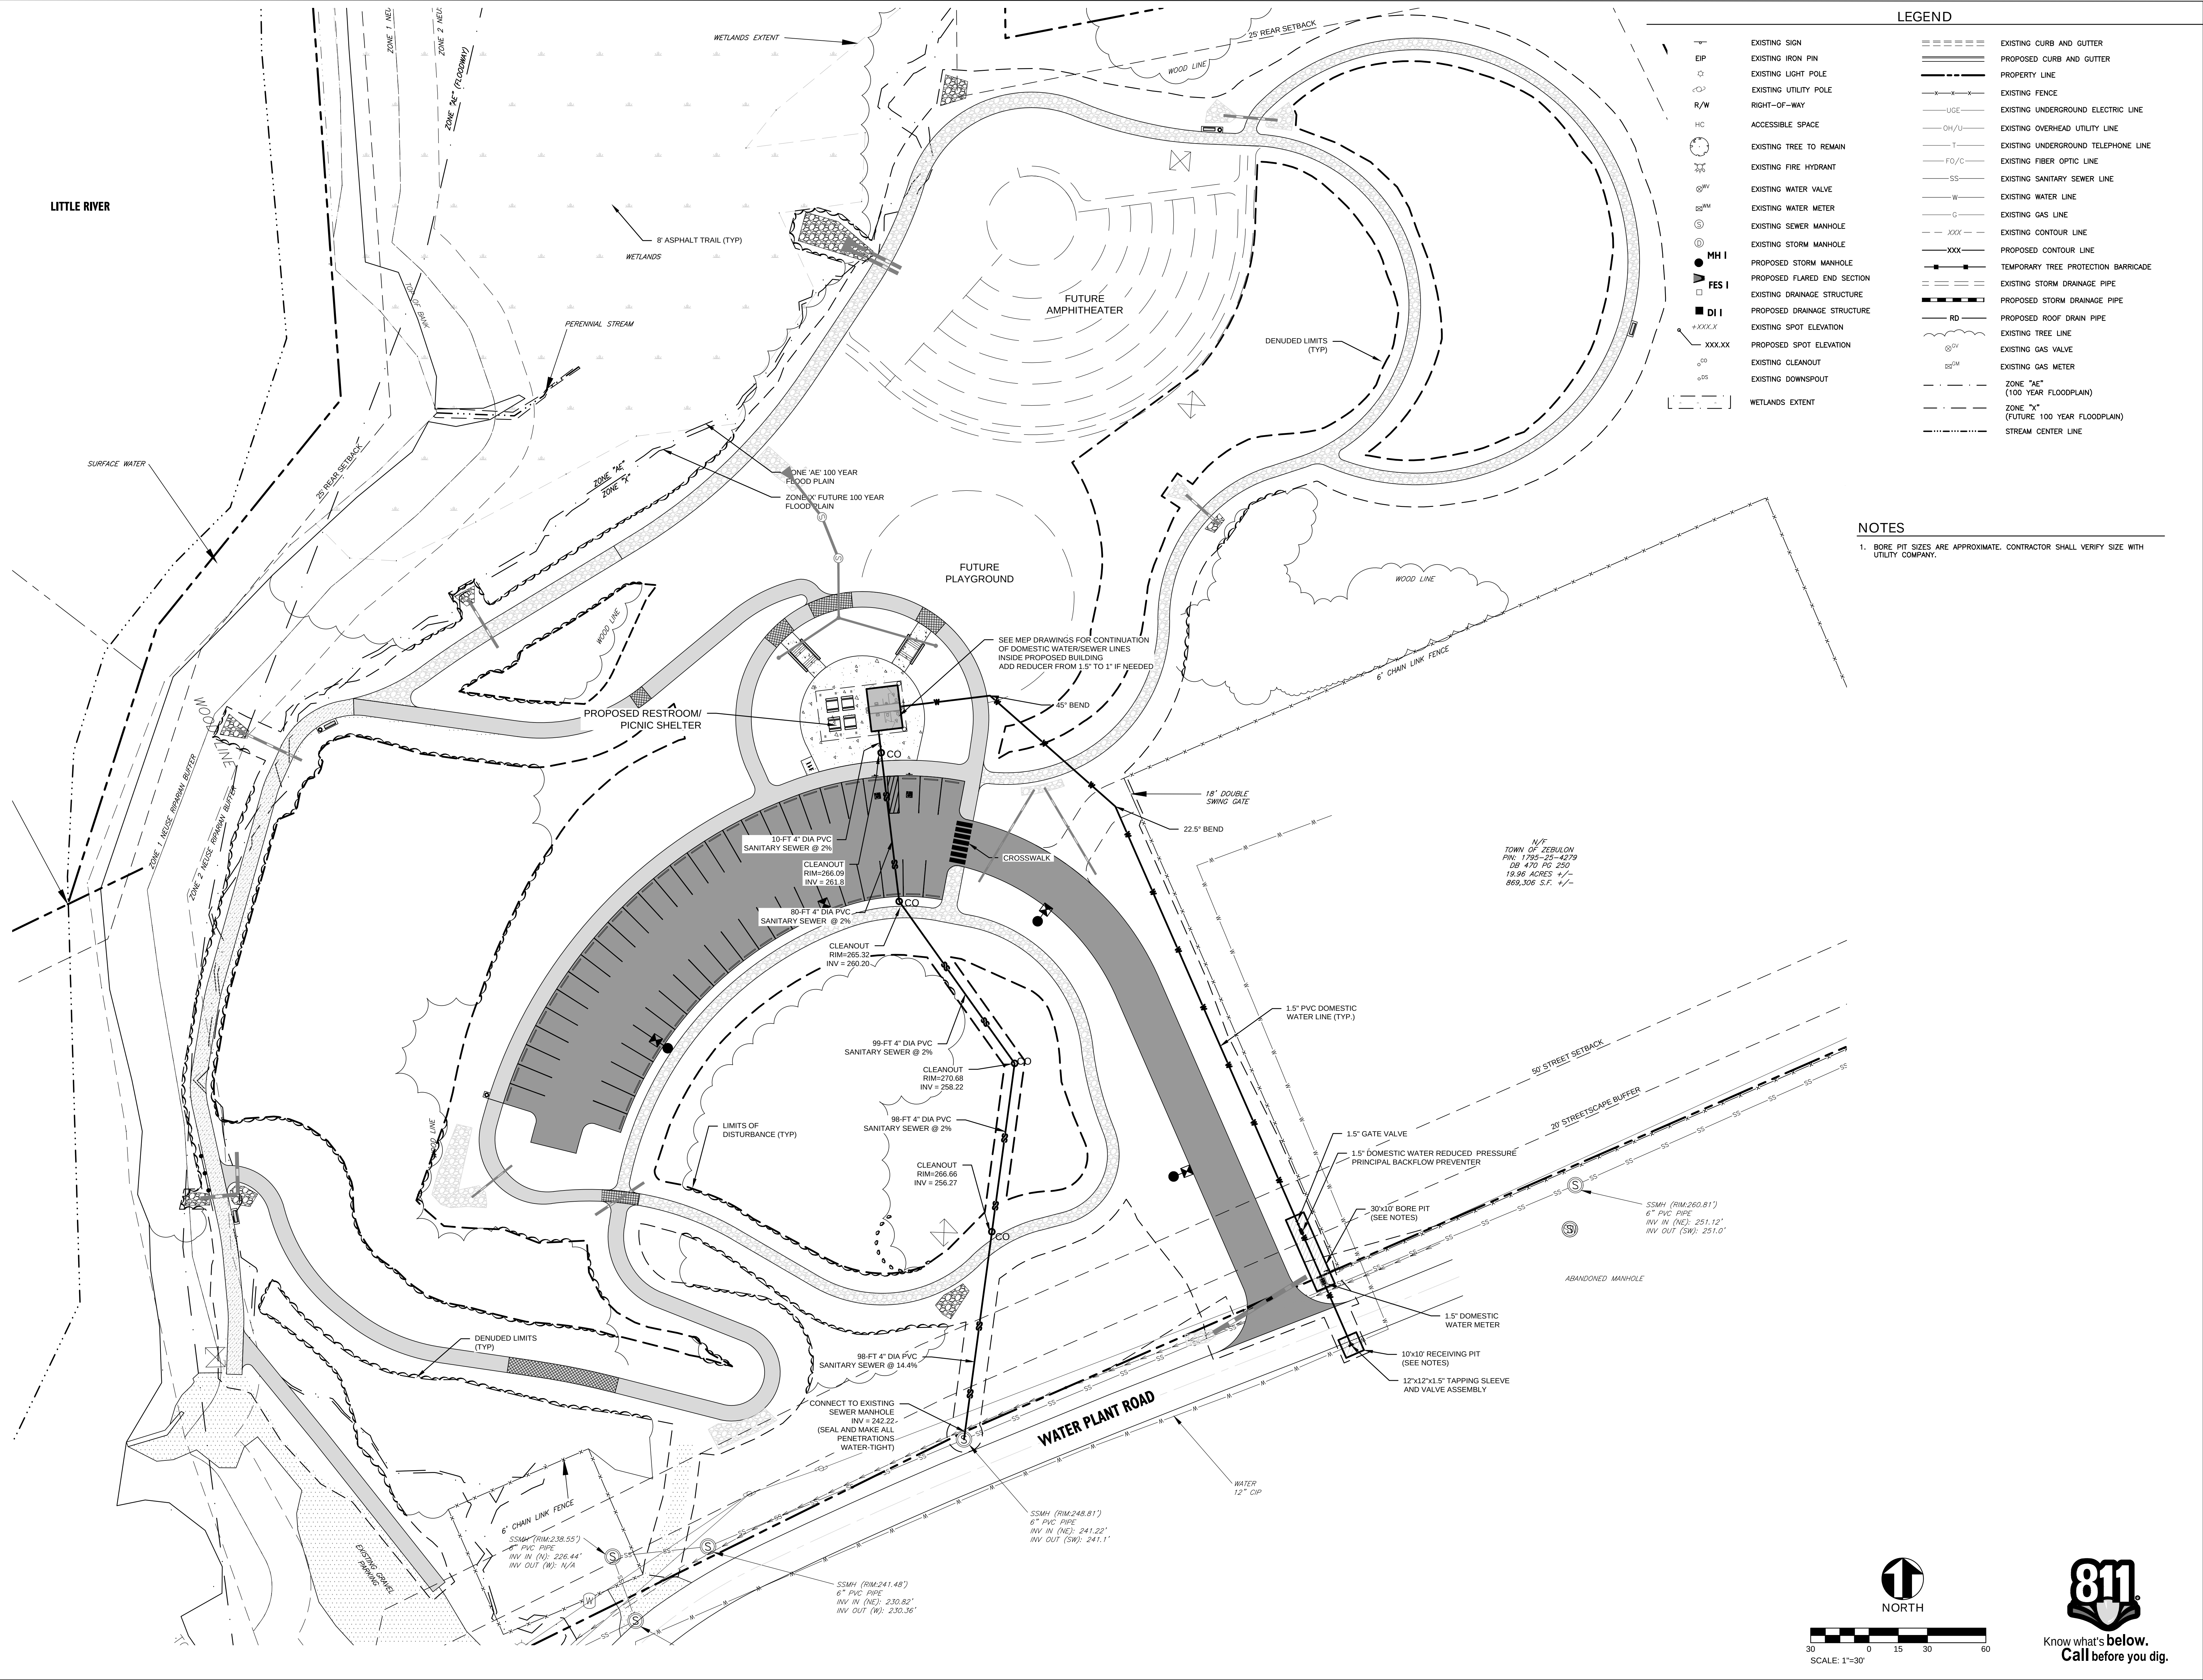


LITTLE RIVER PARK

1800 WEST GANNON AVENUE
ZEBULON, NORTH CAROLINA


Project No: 1725-500672.00
Date: 4.18.25
Revisions:

Sheet Title:
**ENLARGED
UTILITY
PLAN**


Sheet No:
C401

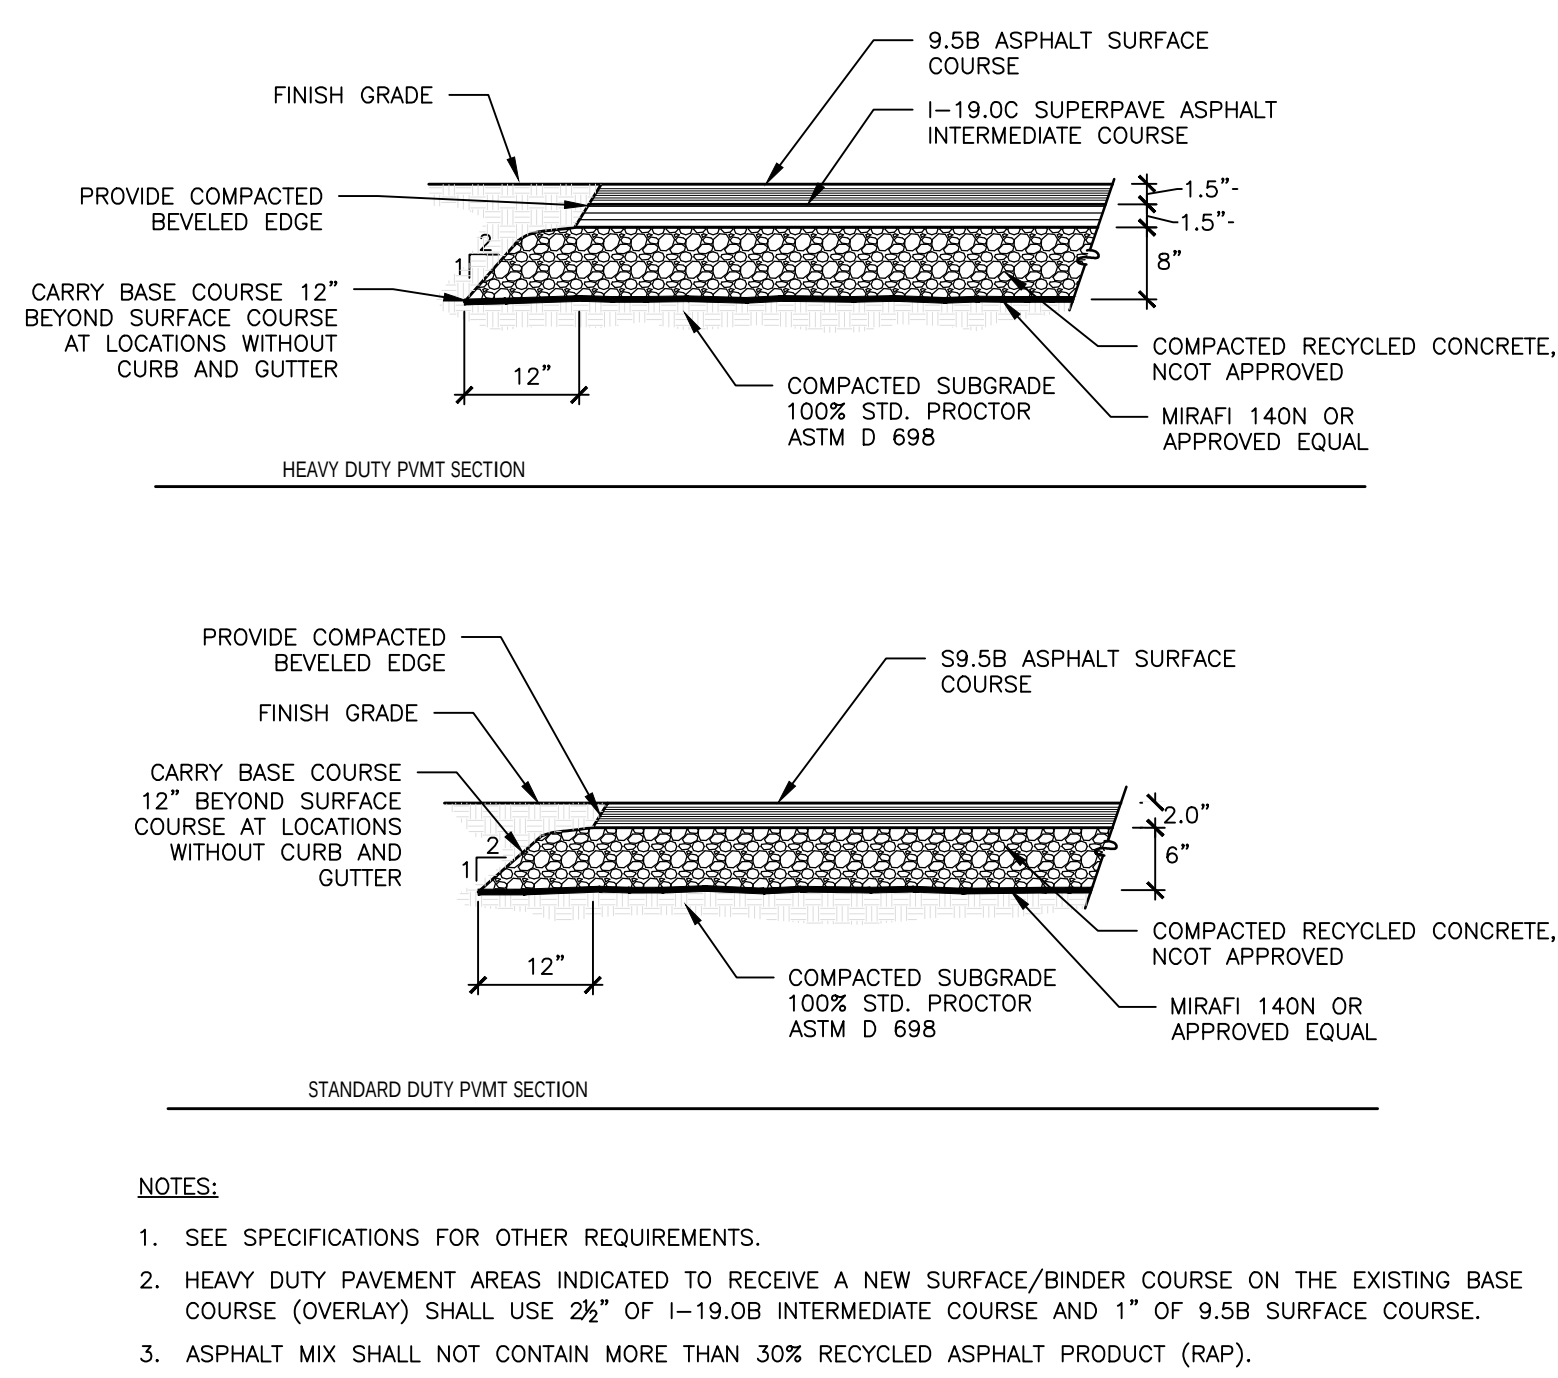


1 ASPHALT PAVING SECTION
N.T.S.

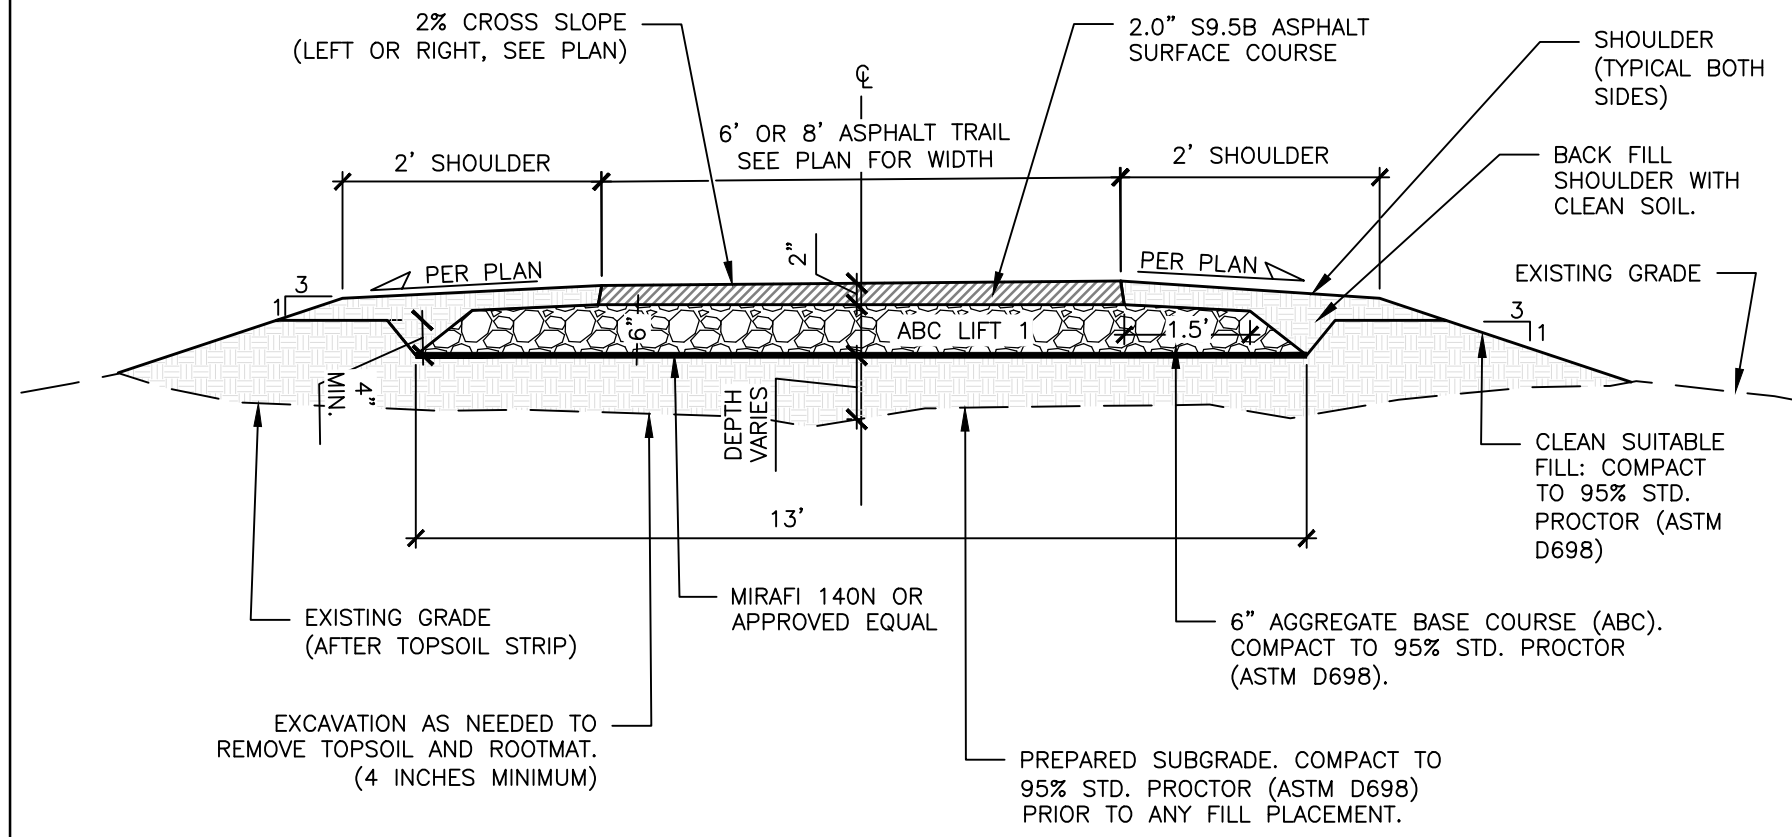


2 8'-WIDE ASPHALT TRAIL WITH 6" BASE COURSE
N.T.S.

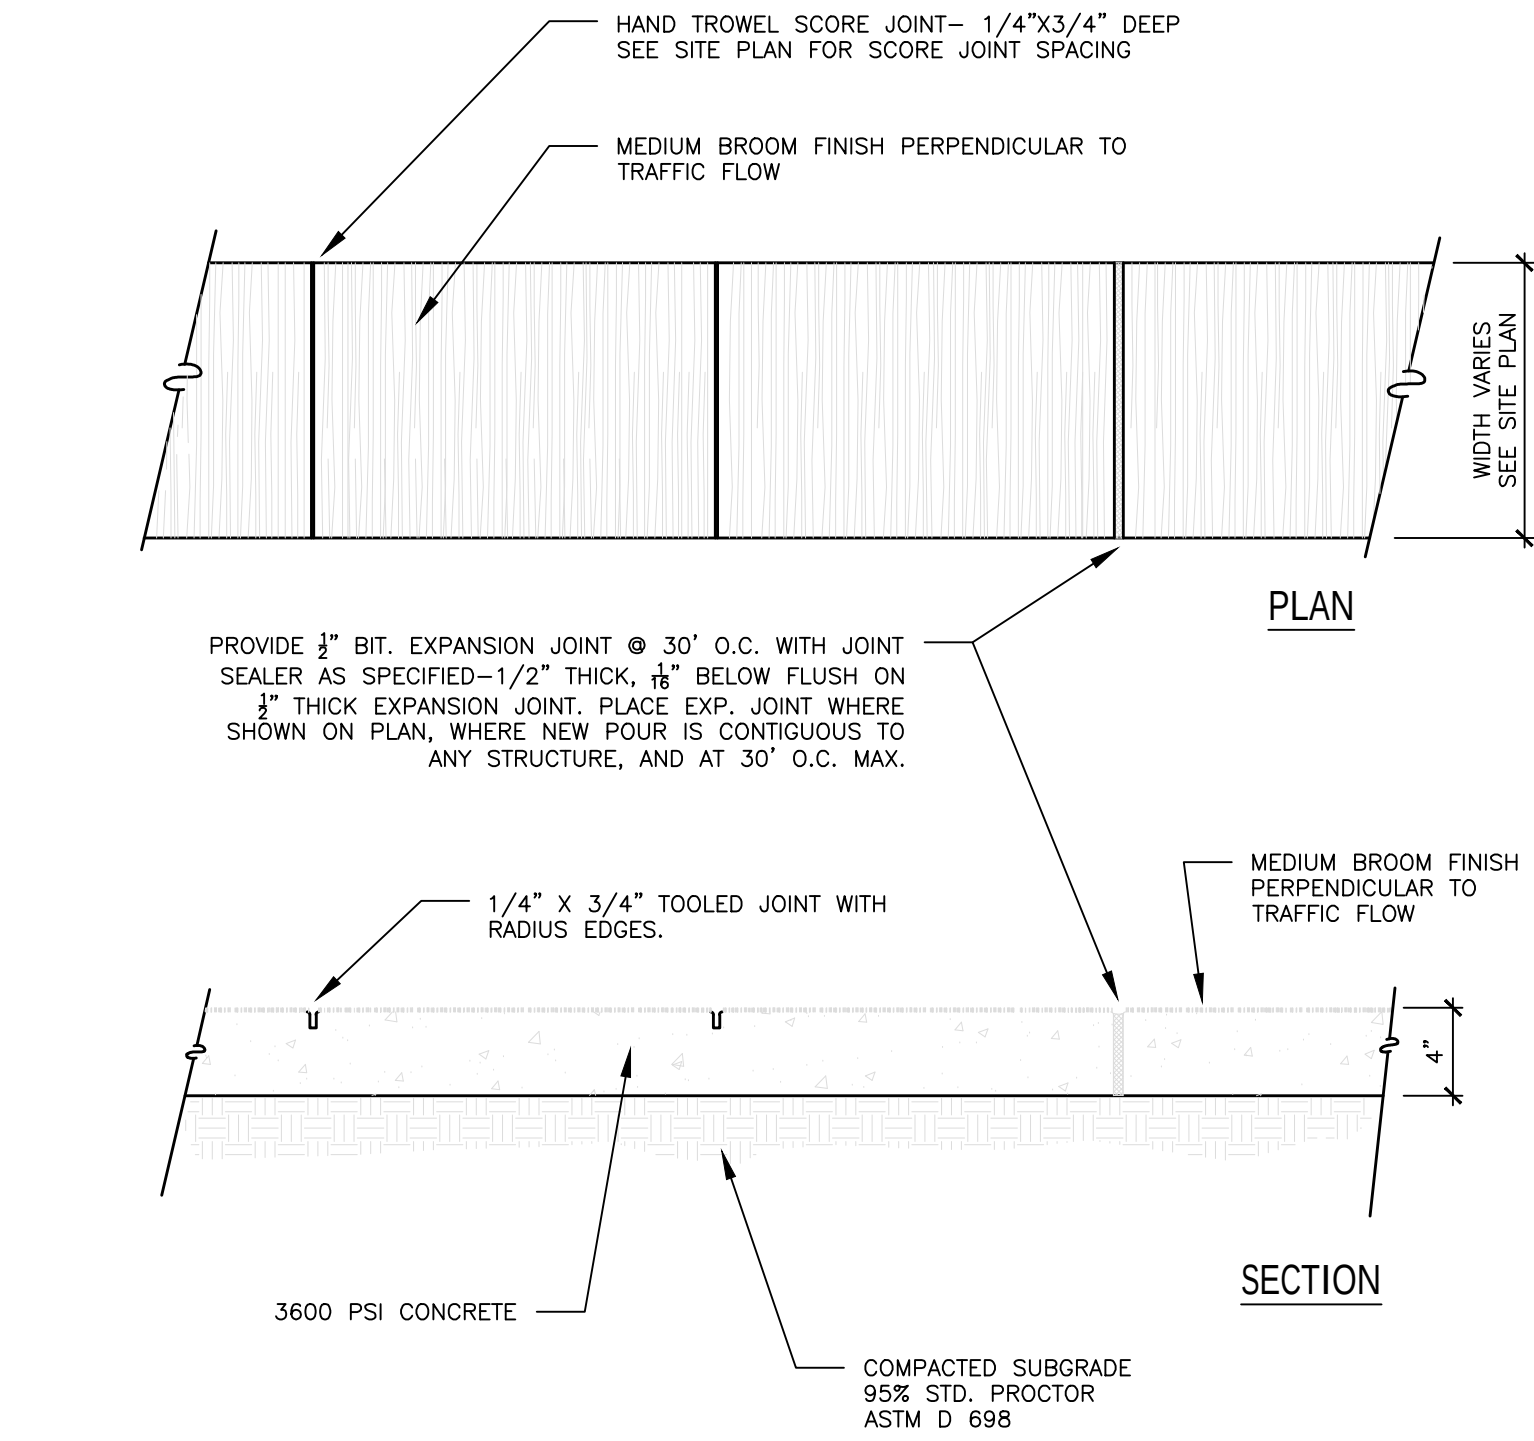



3 CONCRETE SIDEWALK
N.T.S.

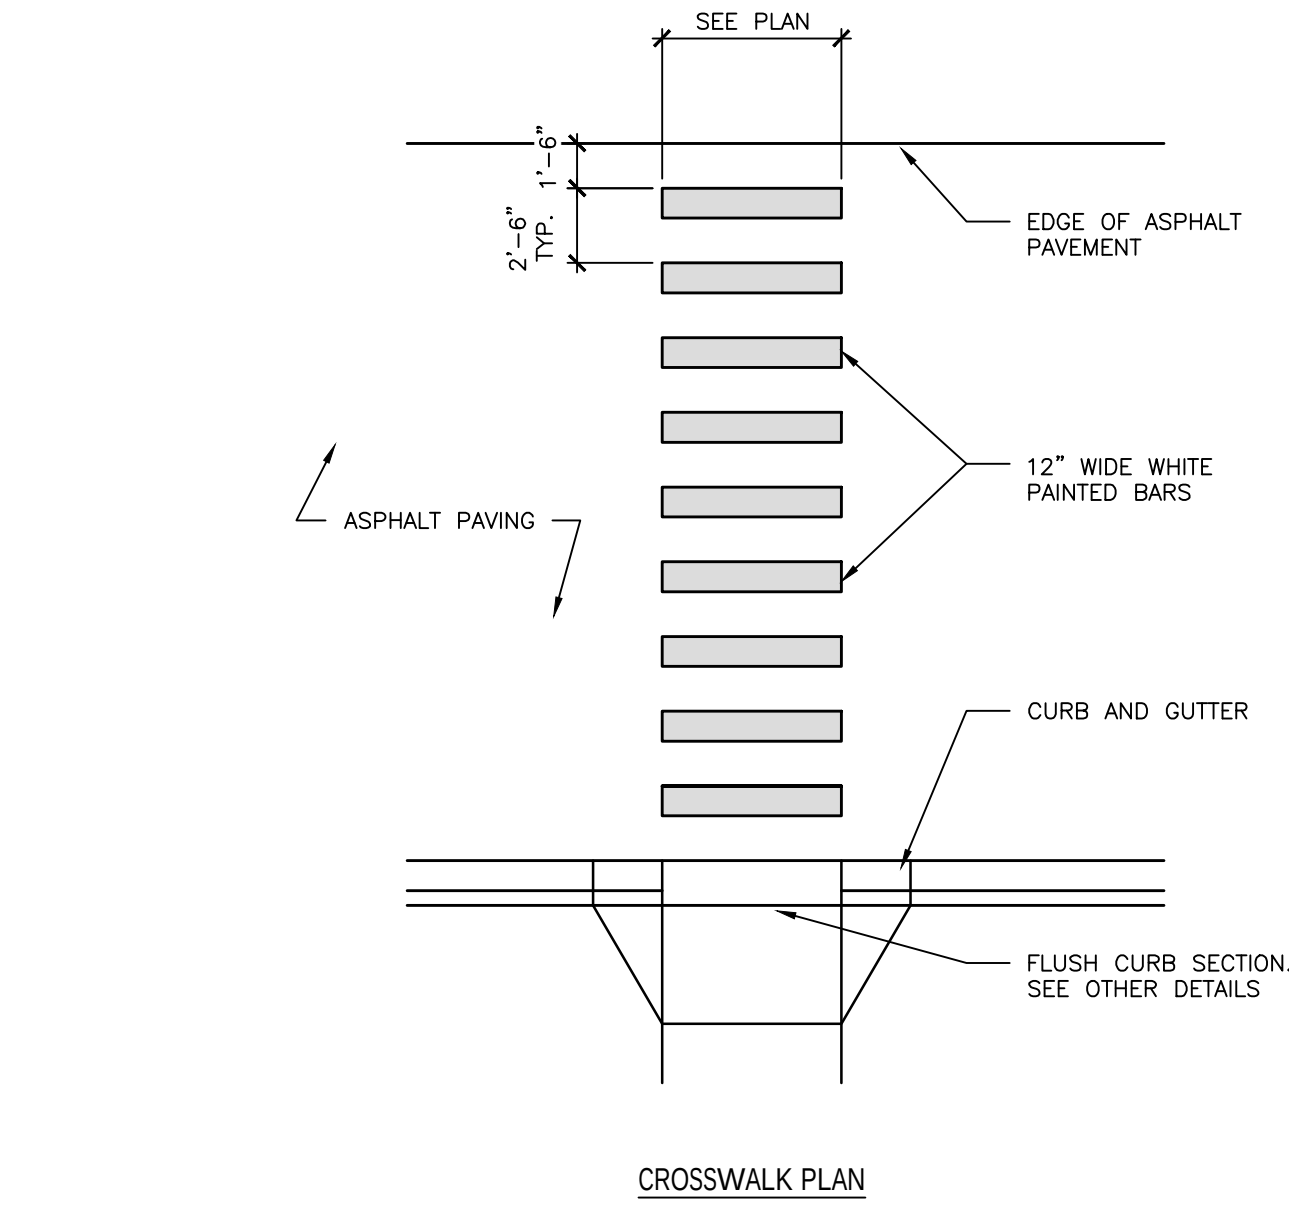


4 PAINTED CROSSWALK
N.T.S.

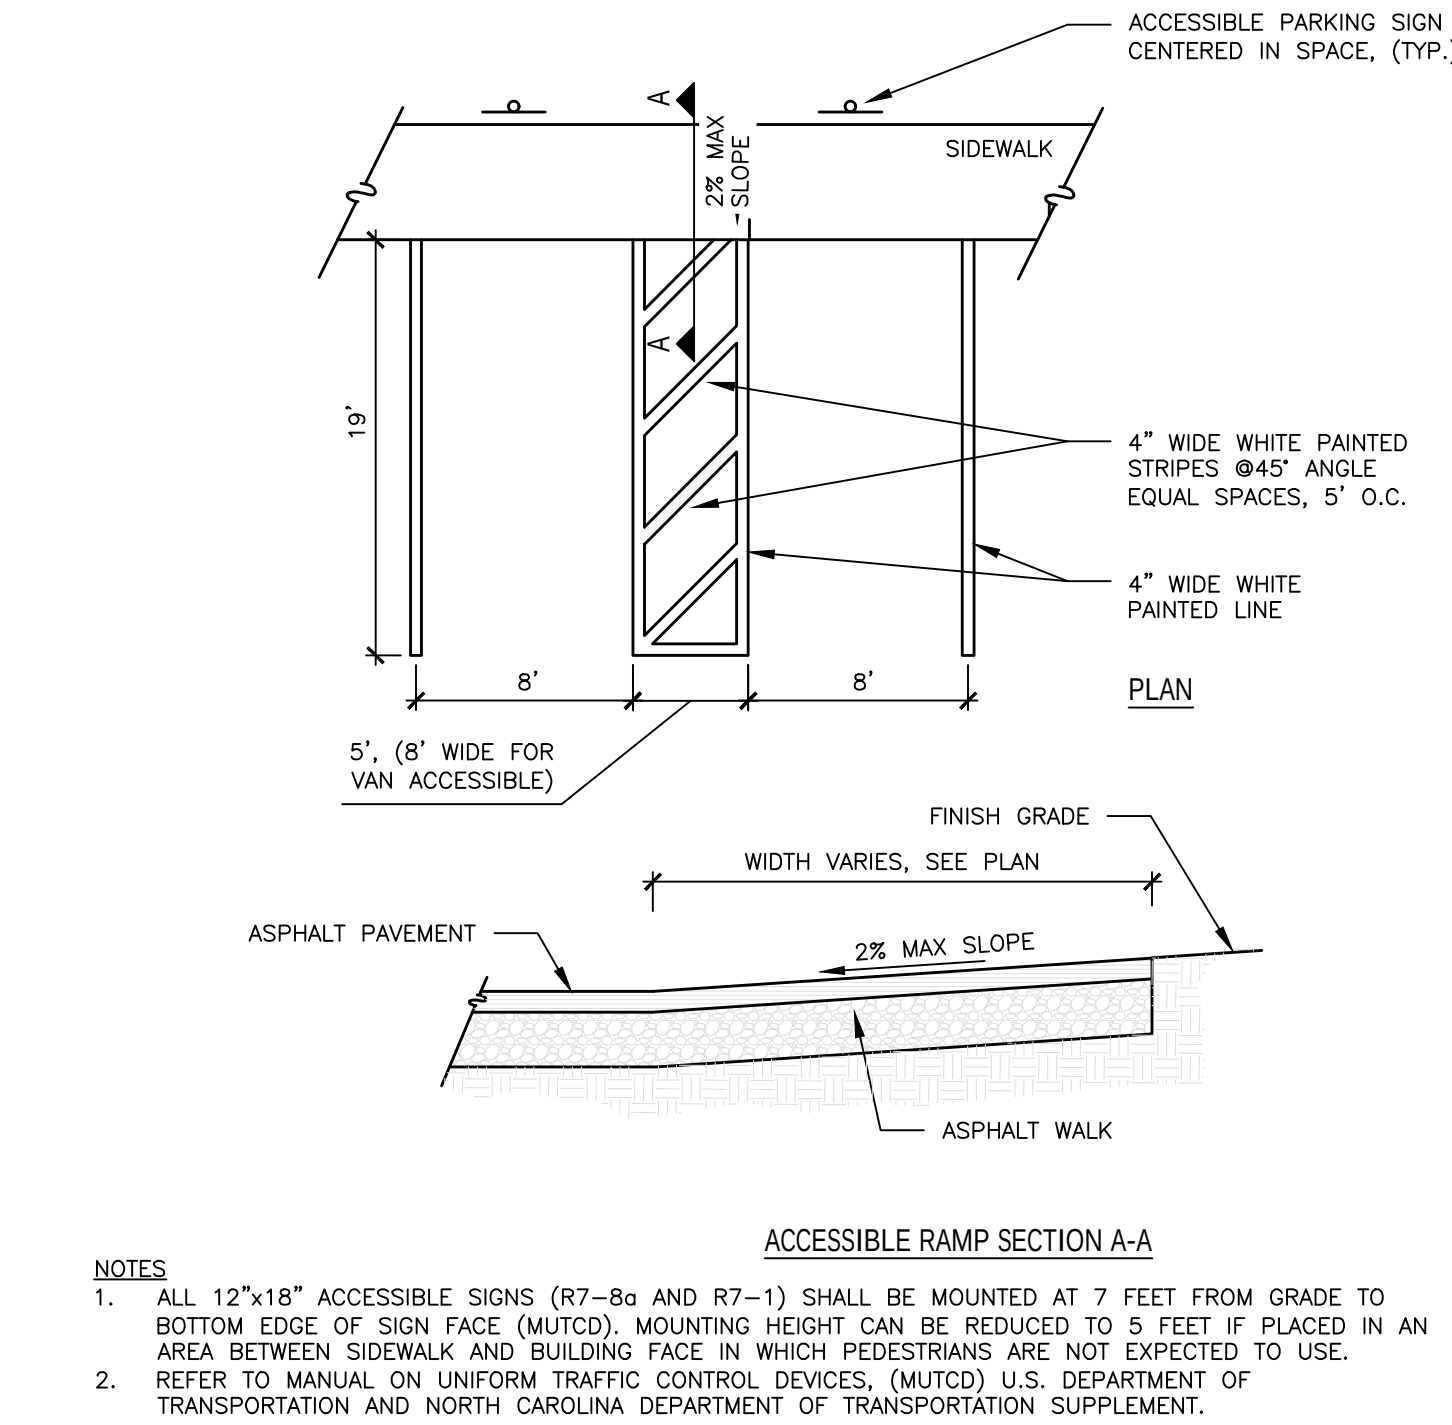


5 ACCESSIBLE PARKING / SIGNAGE / STRIPING
N.T.S.

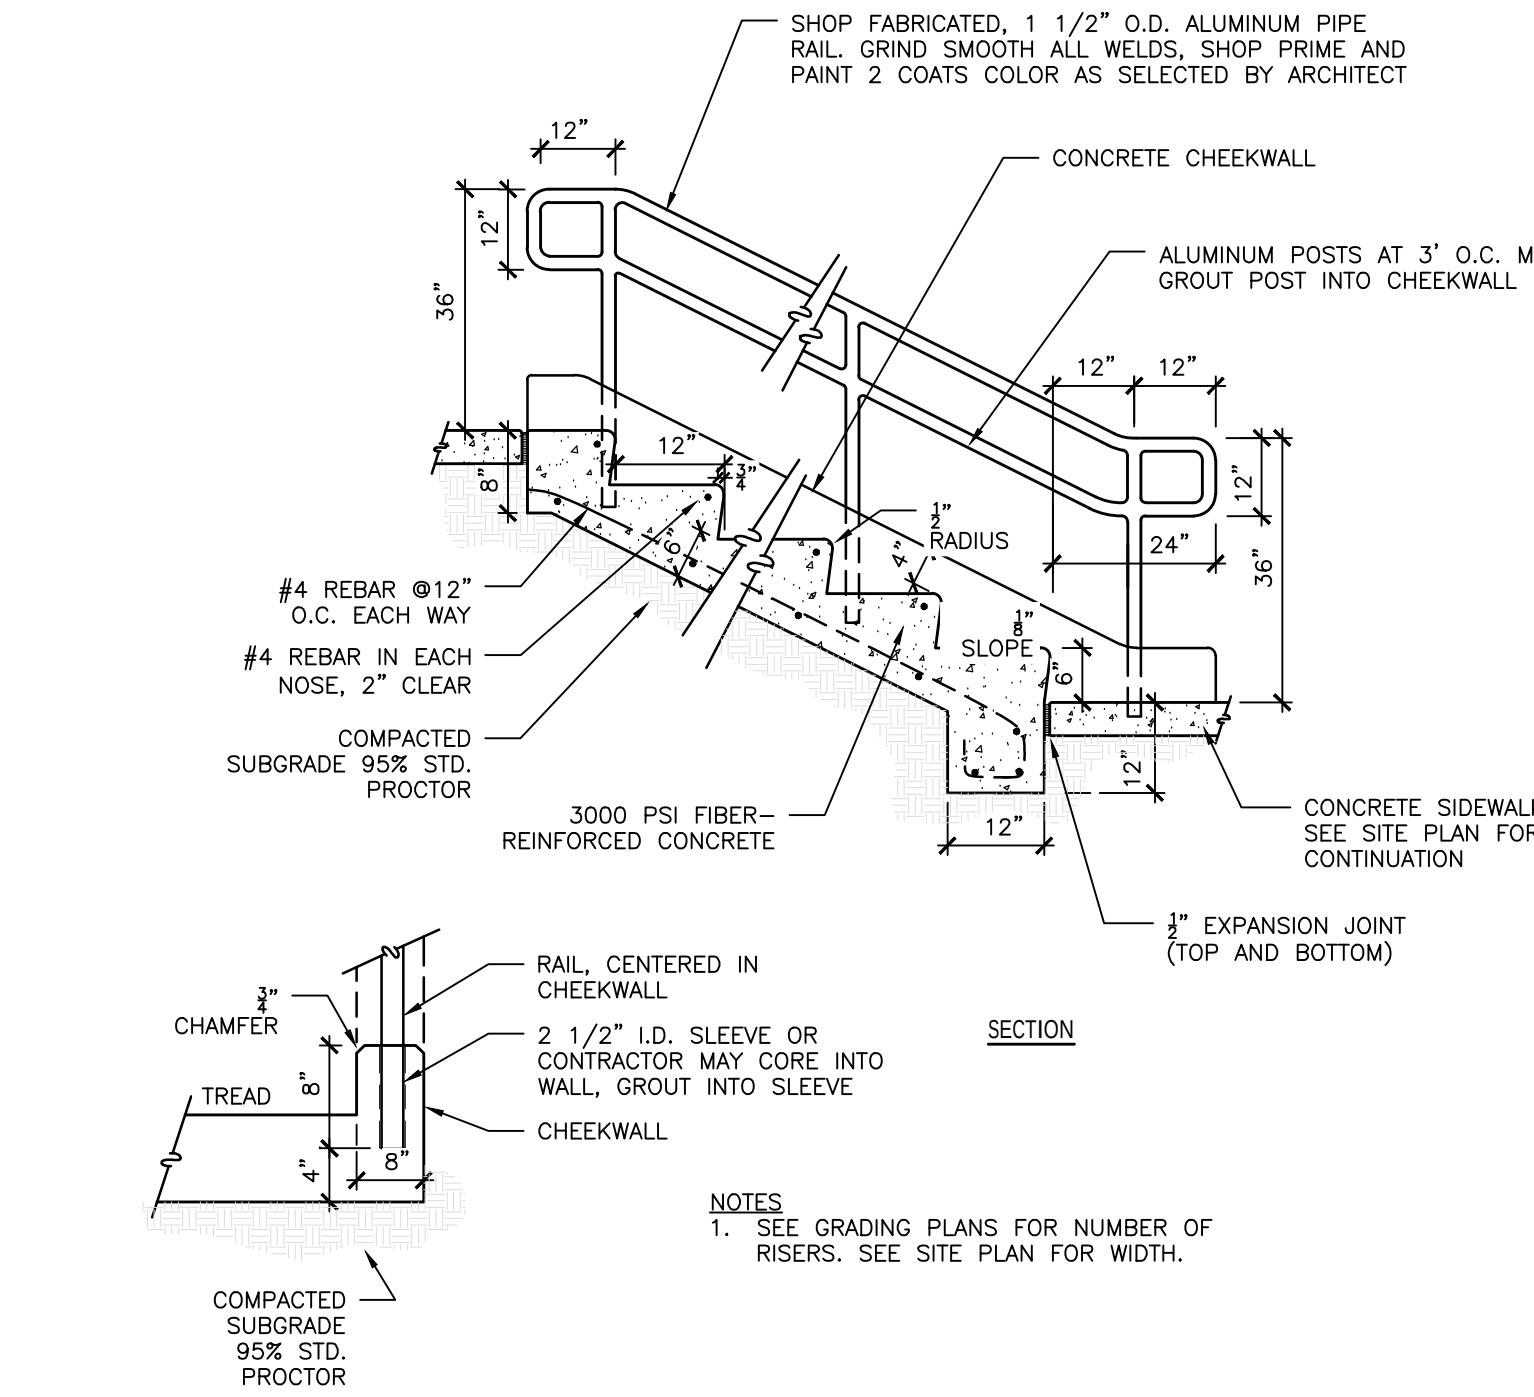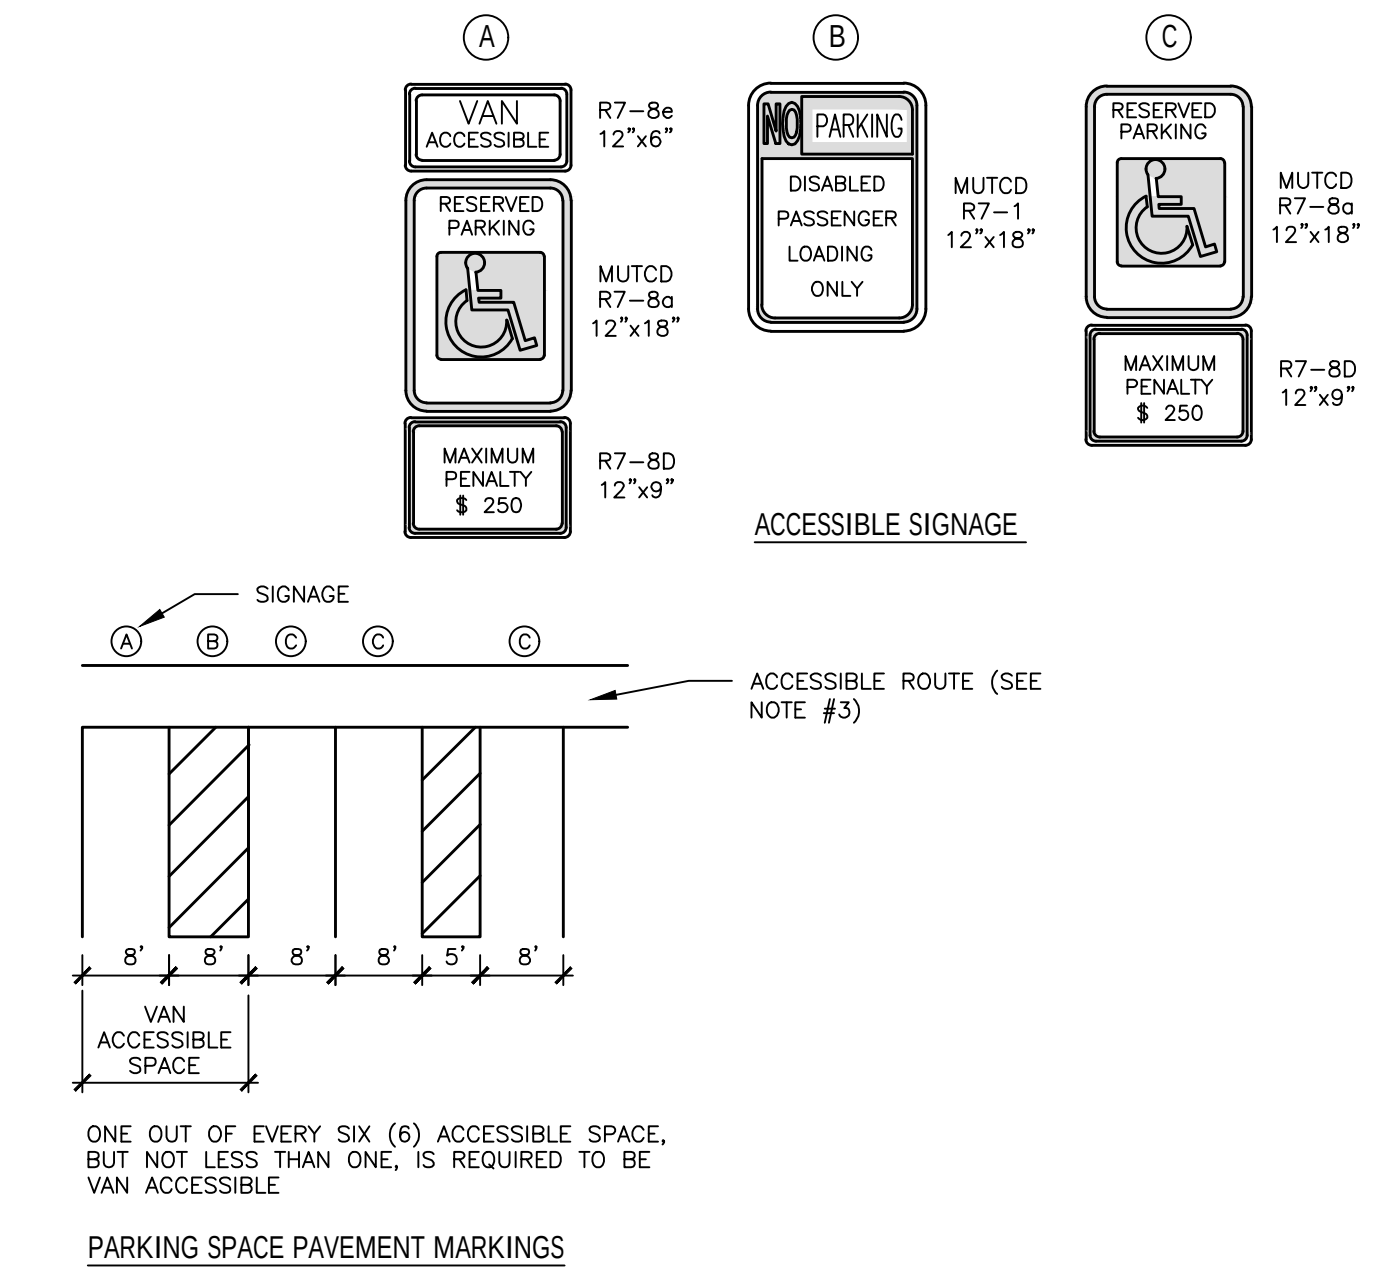


6 CONCRETE STEPS WITH HANDRAIL
N.T.S.

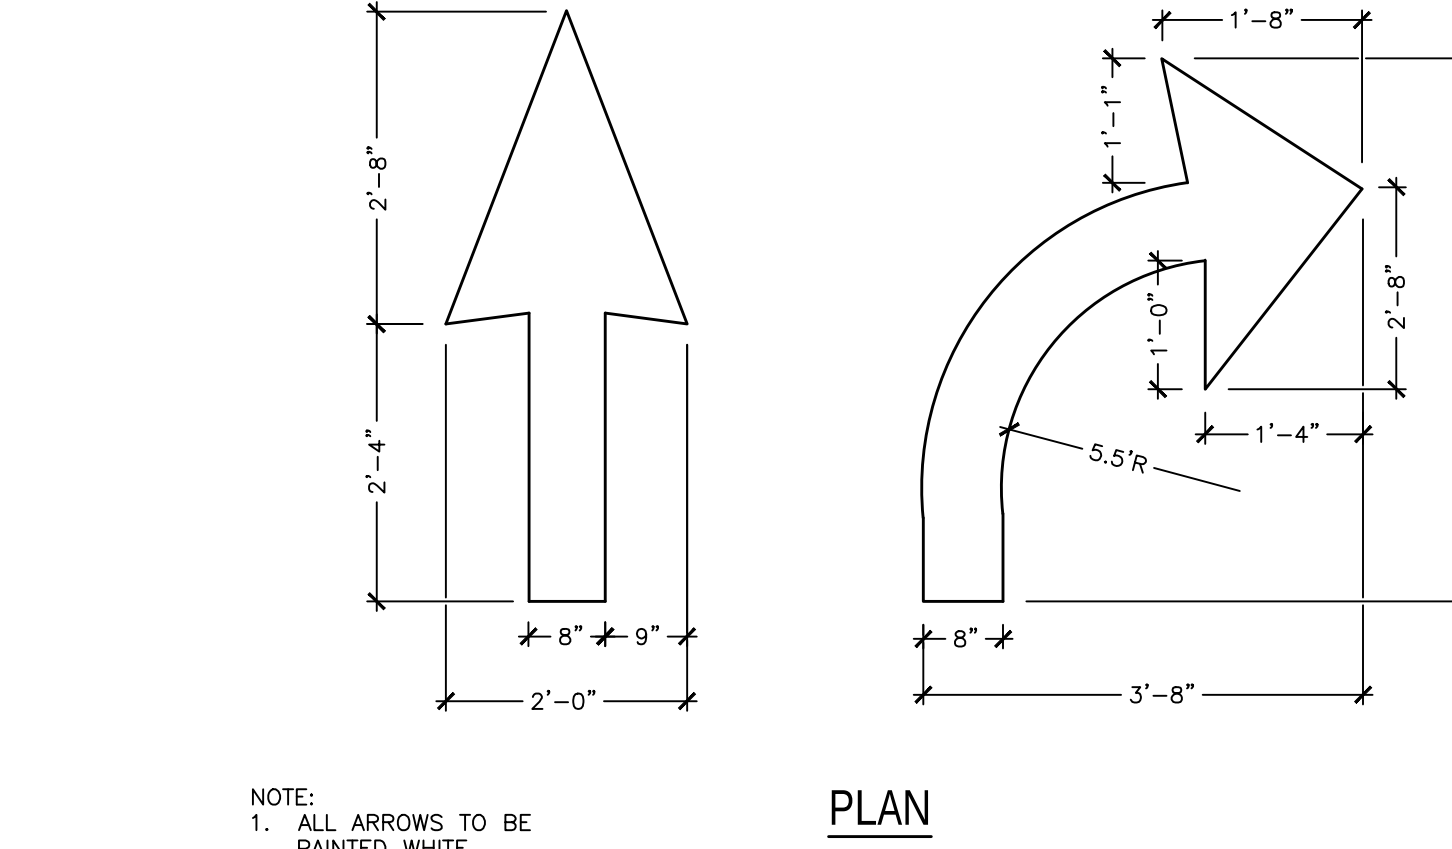


7 PAINTED DIRECTIONAL ARROWS
N.T.S.

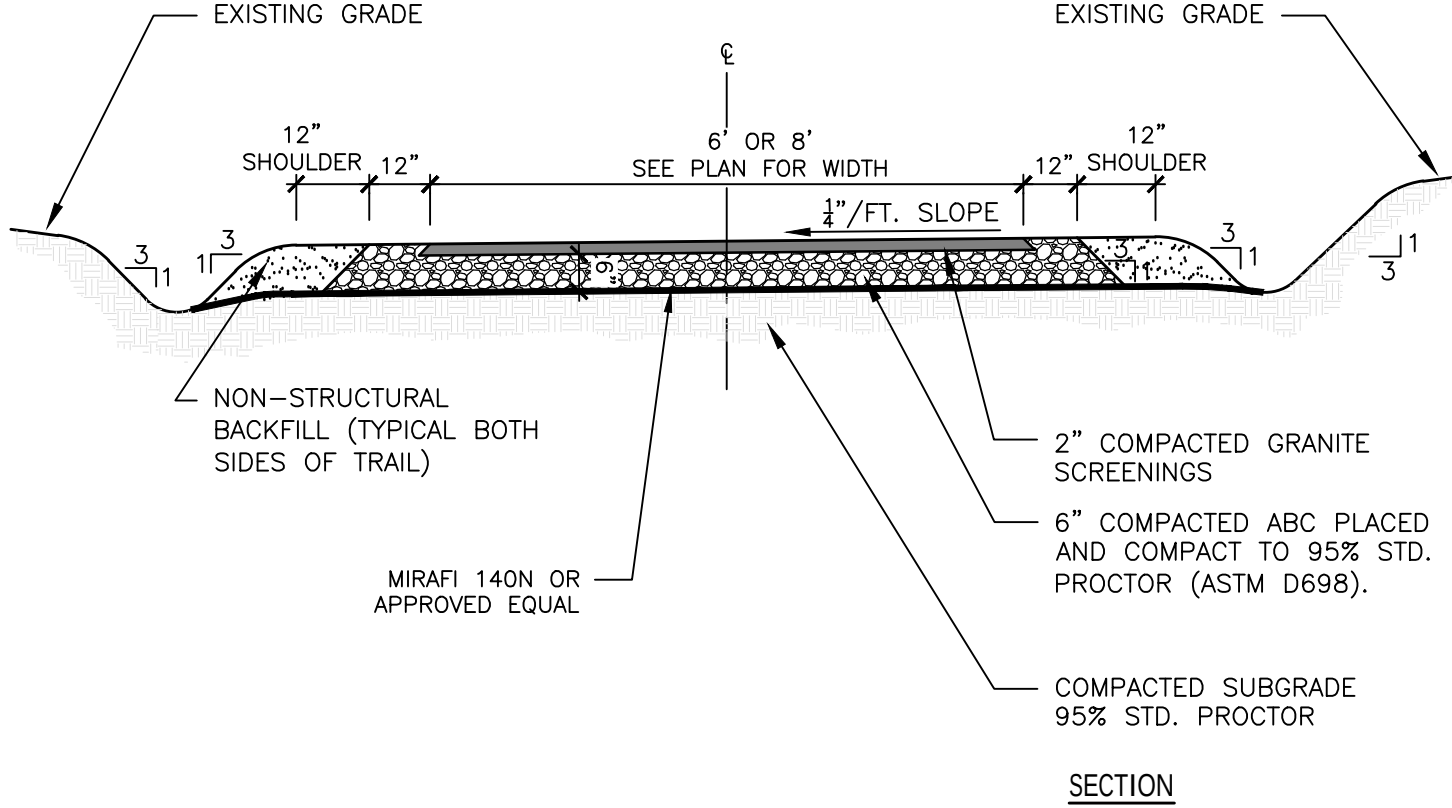


8 GRAVEL TRAIL
N.T.S.

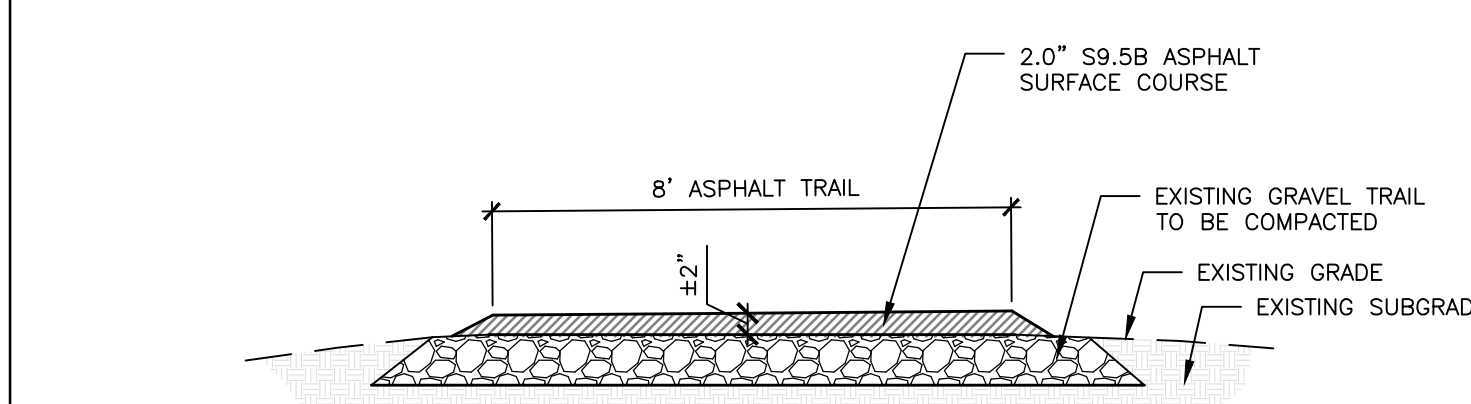


9 ASPHALT TRAIL OVER EXISTING GRAVEL TRAIL
N.T.S.

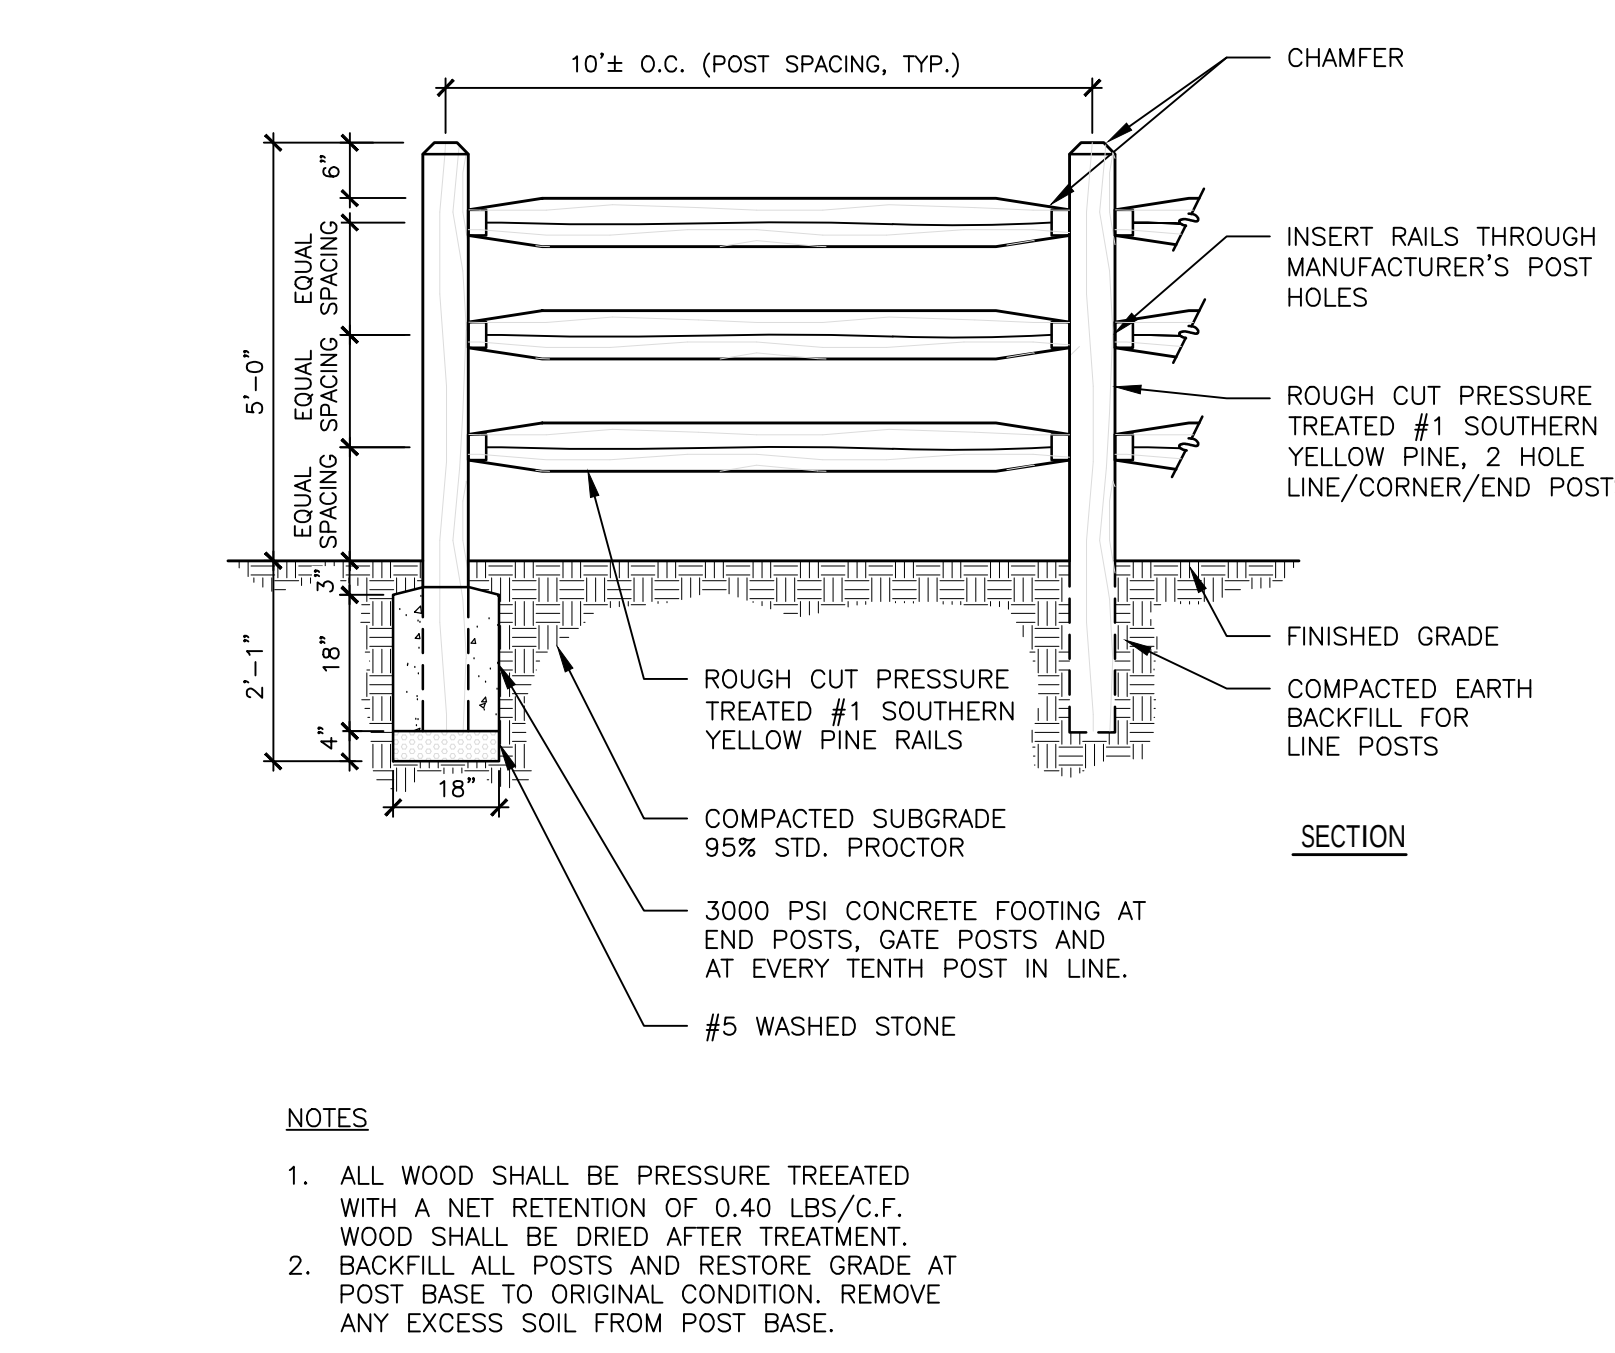


10 SPLIT RAIL FENCE
N.T.S.

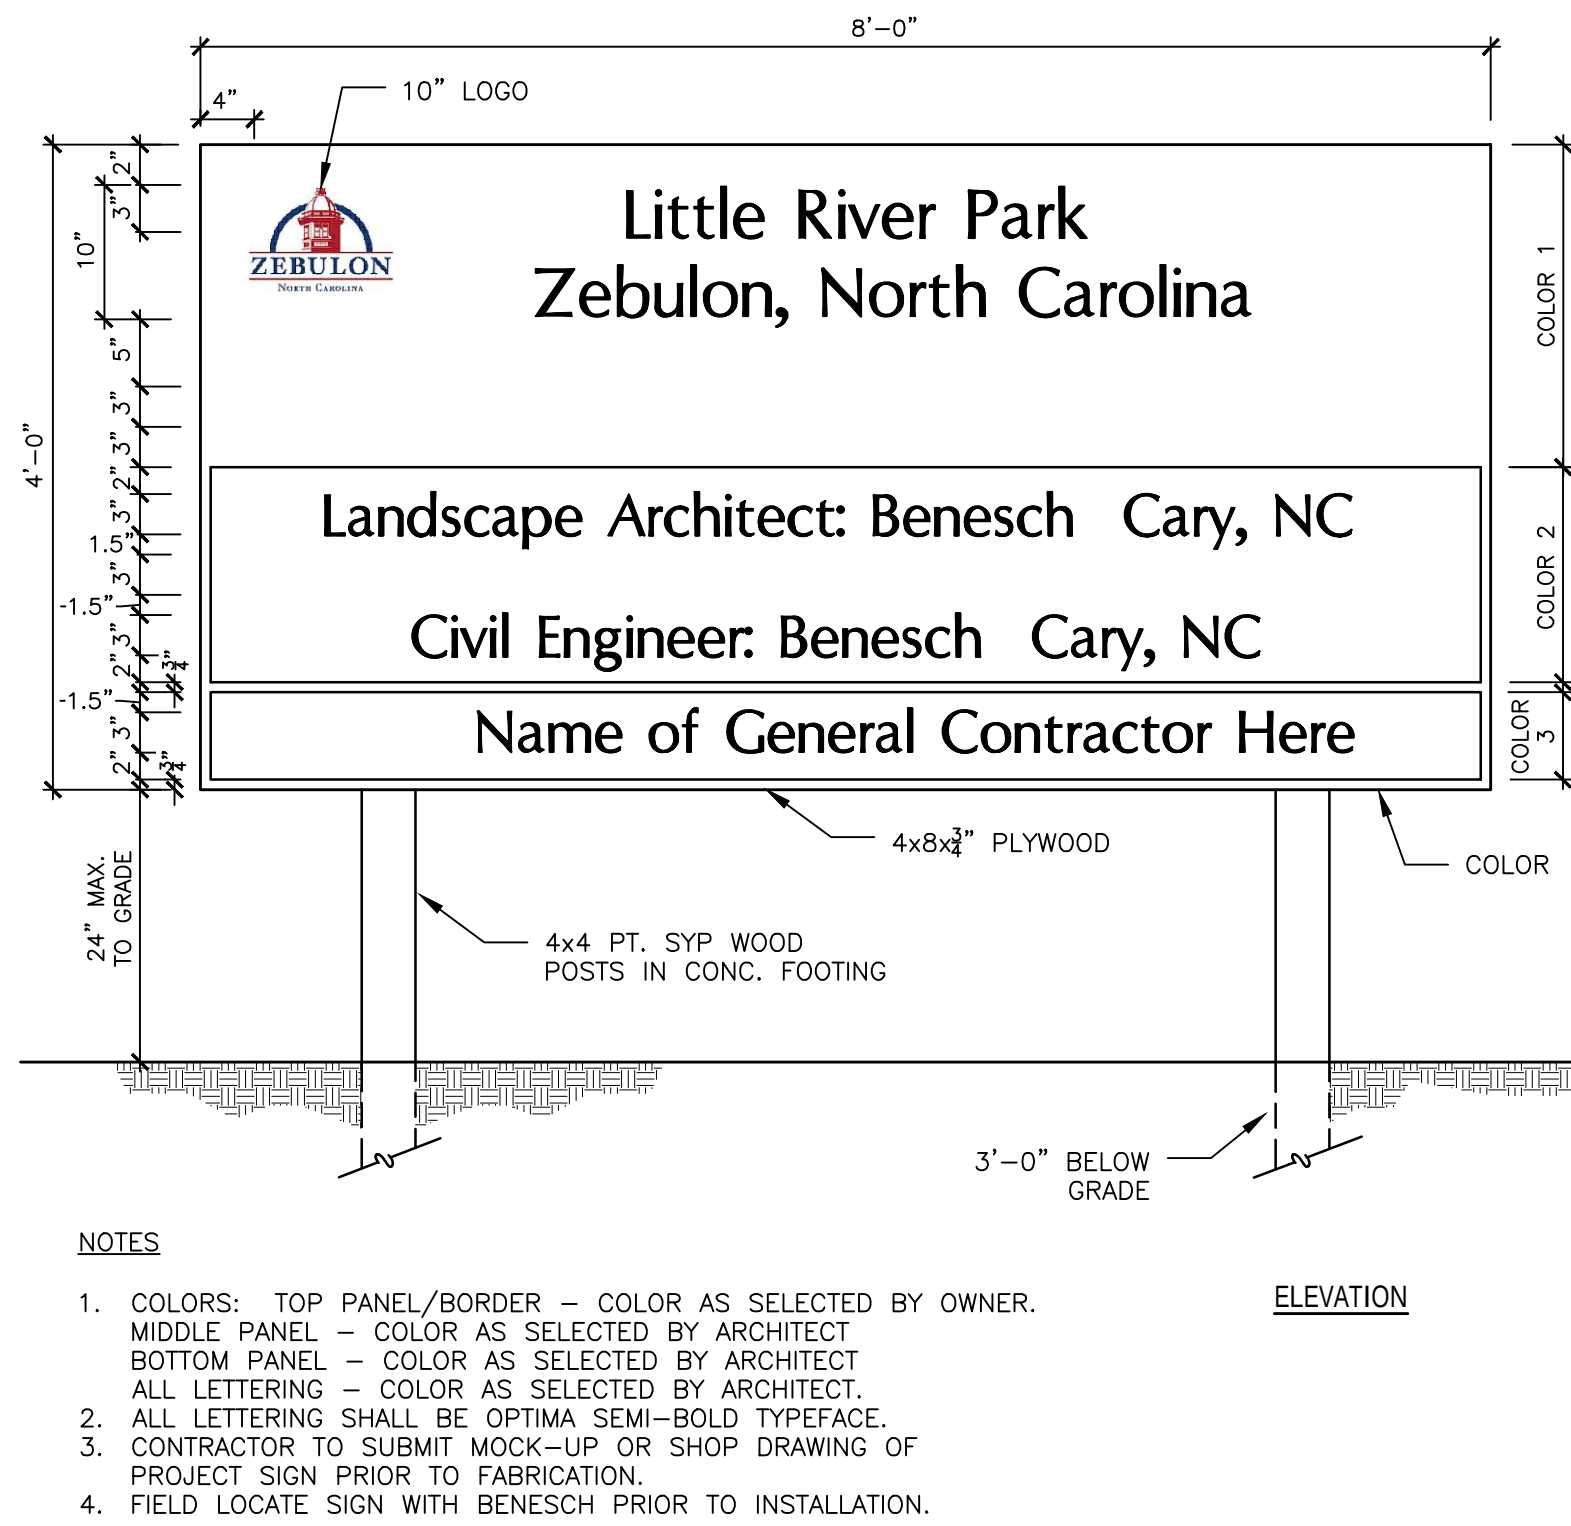


11 TEMPORARY PROJECT SIGN
N.T.S.

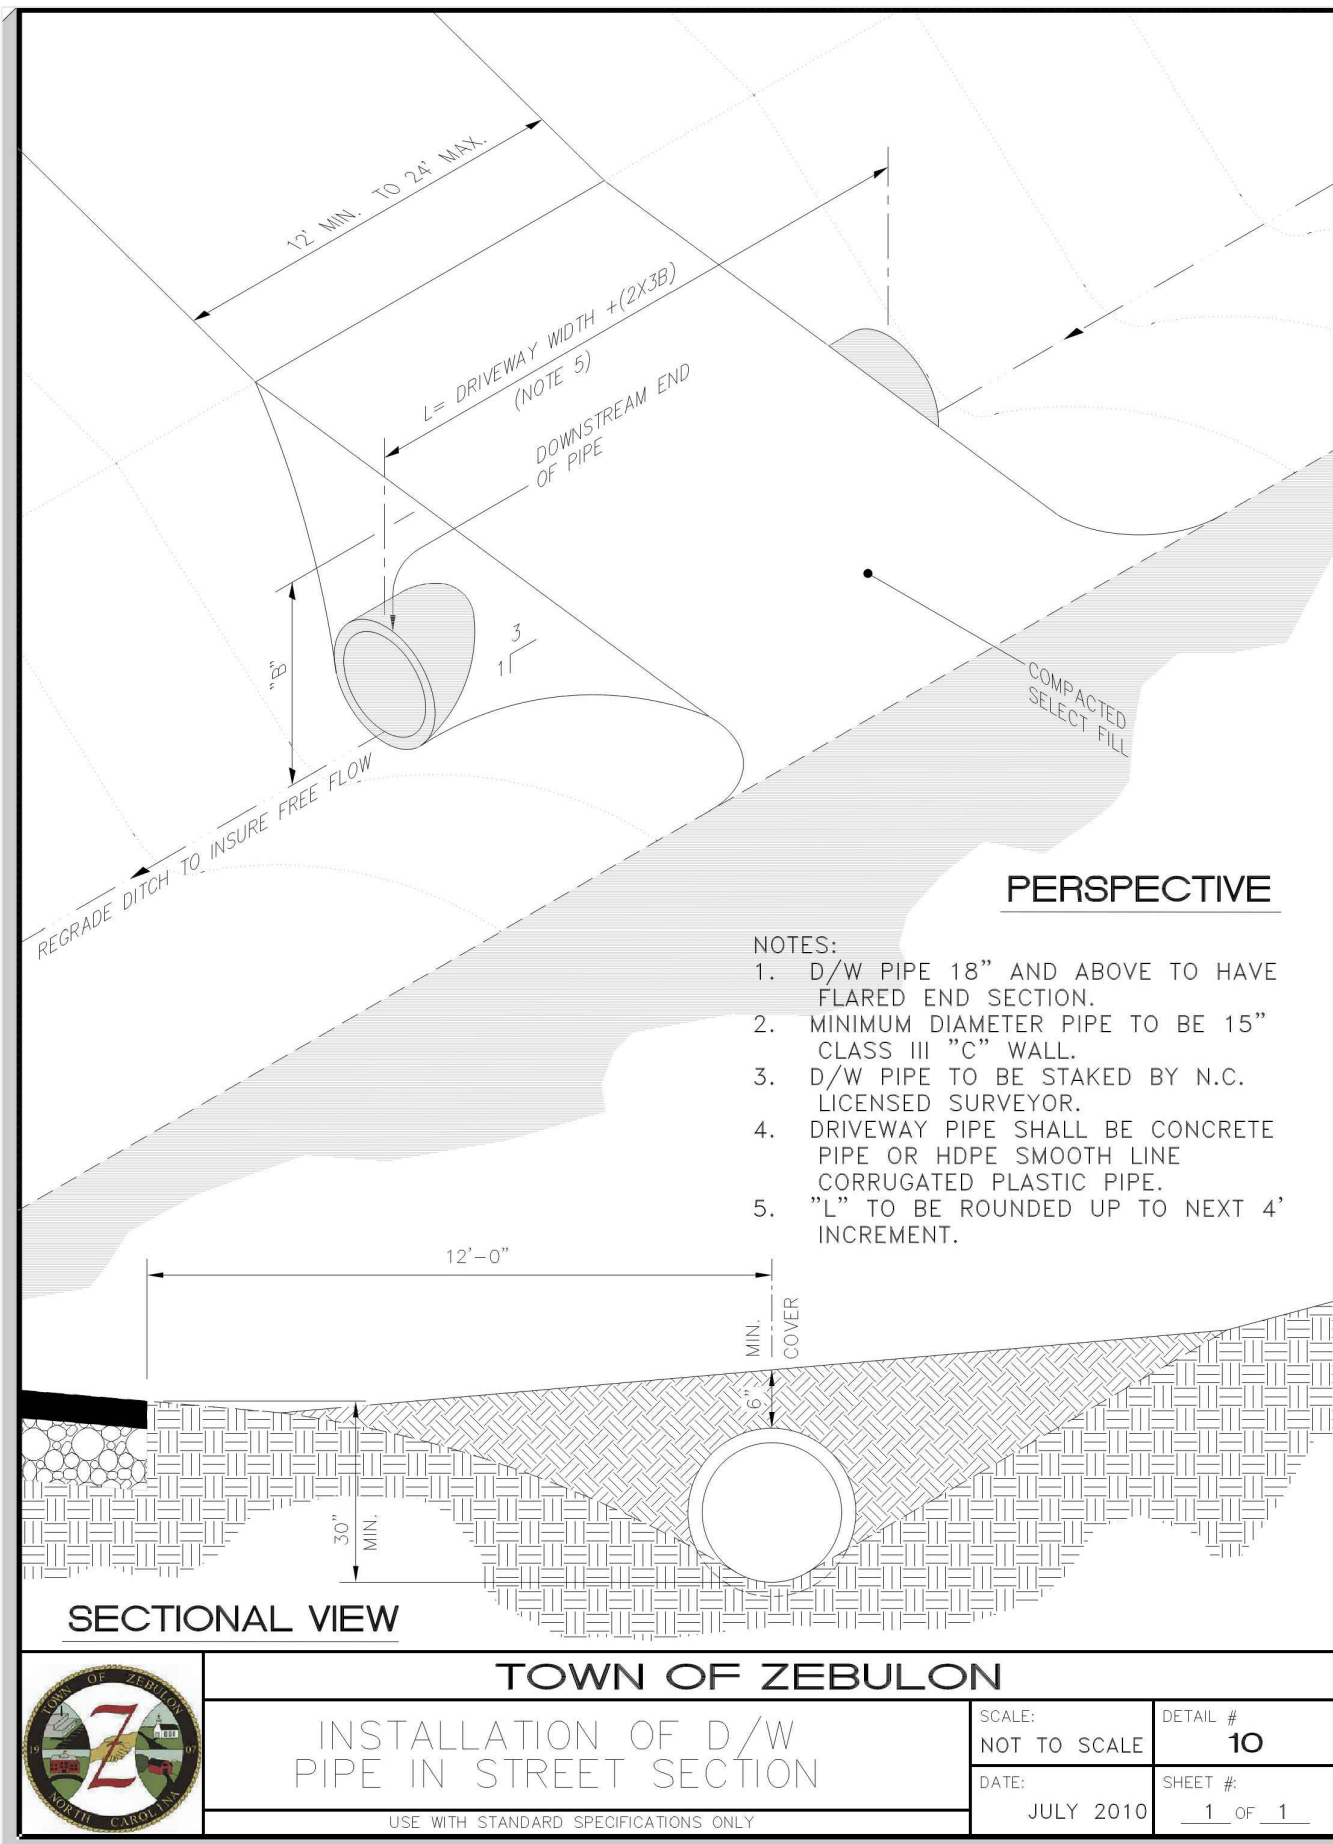

1 INSTALLATION OF D/W PIPE IN STREET SECTION N.T.S.

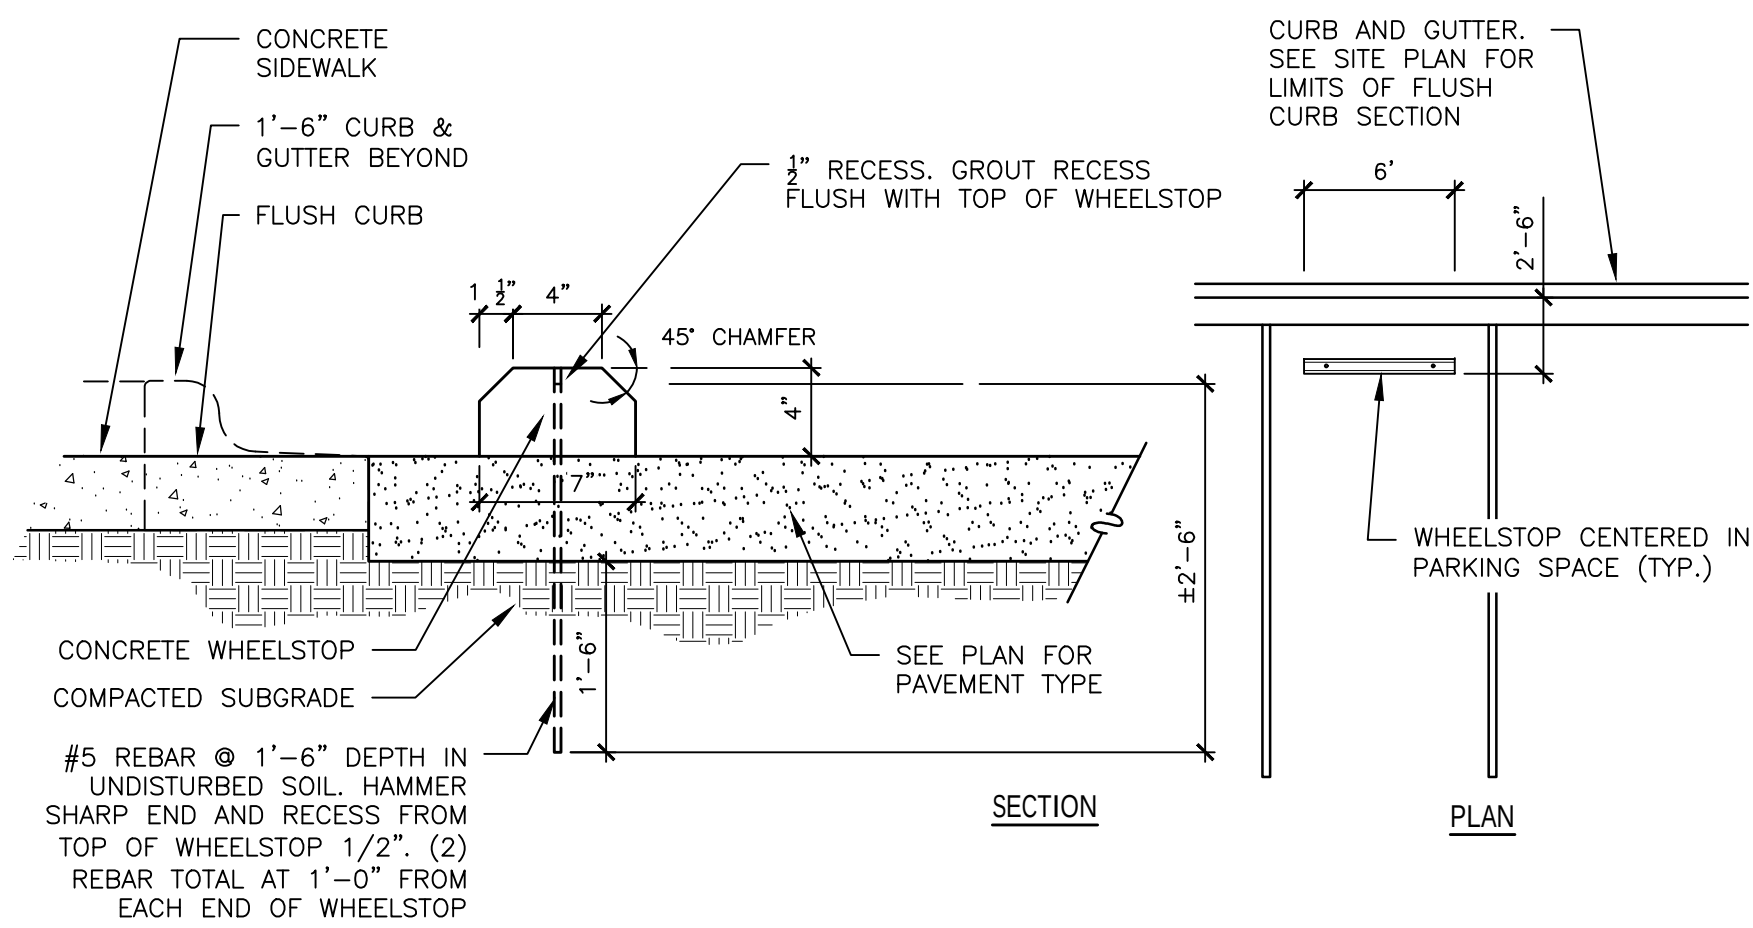

5 CONCRETE WHEELSTOP DETAIL N.T.S.

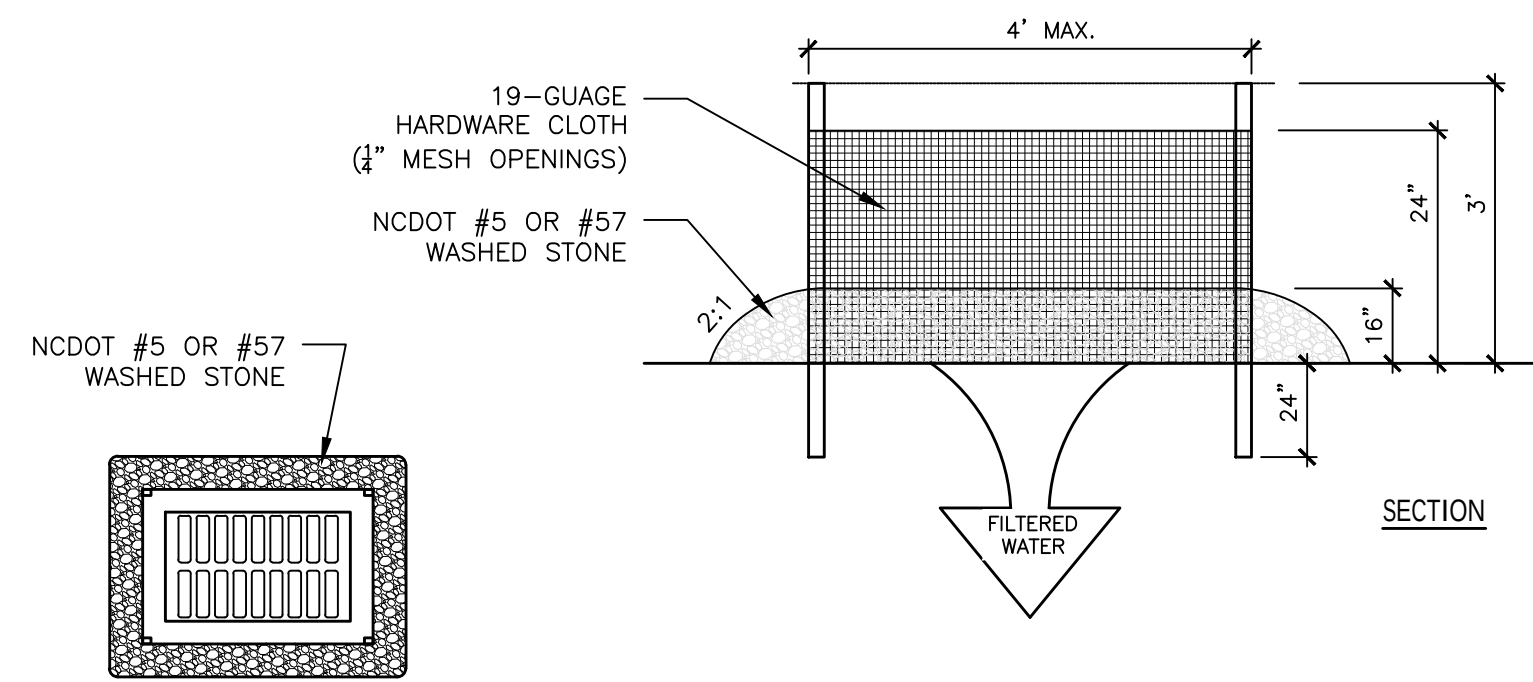

CONSTRUCTION SPECIFICATIONS

- UNIFORMLY GRADE A SHALLOW DEPRESSION APPROACHING INLET.
- DRIVE 5-FOOT STEEL POSTS 2 FEET INTO THE GROUND SURROUNDING THE INLET. SPACE POST EVENLY AROUND THE PERIMETER OF THE INLET. A MAXIMUM OF 4 FEET APART.
- SURROUND THE POSTS WITH WIRE MESH HARDWARE CLOTH. SECURE THE WIRE MESH TO THE STEEL POSTS AT THE TOP, MIDDLE, AND BOTTOM. PLACING A 2-FOOT FLAP OF WIRE MESH UNDER THE GRAVEL FOR ANCHORING IS RECOMMENDED.
- PLACE CLEAN GRAVEL (NCDOT #5 OR #57 STONE) ON A 2:1 SLOPE WITH A HEIGHT OF 18 INCHES AROUND THE WIRE, AND SMOOTH TO AN EVEN GRADE.
- ONCE THE CONTRIBUTING DRAINAGE AREA HAS BEEN STABILIZED, REMOVE ACCUMULATED SEDIMENT, AND ESTABLISH FINAL GRADING ELEVATIONS.
- COMPACT THE AREA PROPERLY AND STABILIZED IT WITH GROUND COVER.

MAINTENANCE


INSPECT INLETS AT LEAST WEEKLY AND AFTER EACH SIGNIFICANT (1/2 INCH OR GREATER) RAINFALL EVENT. CLEAR THE MESH WIRE OF ANY DEBRIS OR OTHER OBJECTS TO PROVIDE ADEQUATE FLOW FOR SUBSEQUENT RAINS. TAKE CARE NOT TO DAMAGE OR UNDERCUT THE WIRE MESH DURING SEDIMENT REMOVAL. REPLACE STONE AS NEEDED.

REFERENCES


- INLET PROTECTION
- 6.52. BLOCK AND GRAVEL INLET PROTECTION
- 6.54. ROCK DOUGHNUT INLET PROTECTION

NORTH CAROLINA DEPARTMENT OF TRANSPORTATION STANDARD SPECIFICATION FOR ROADS AND STRUCTURES


6 HARDWARE CLOTH AND GRAVEL INLET PROTECTION NCDEQ STD. 6.51

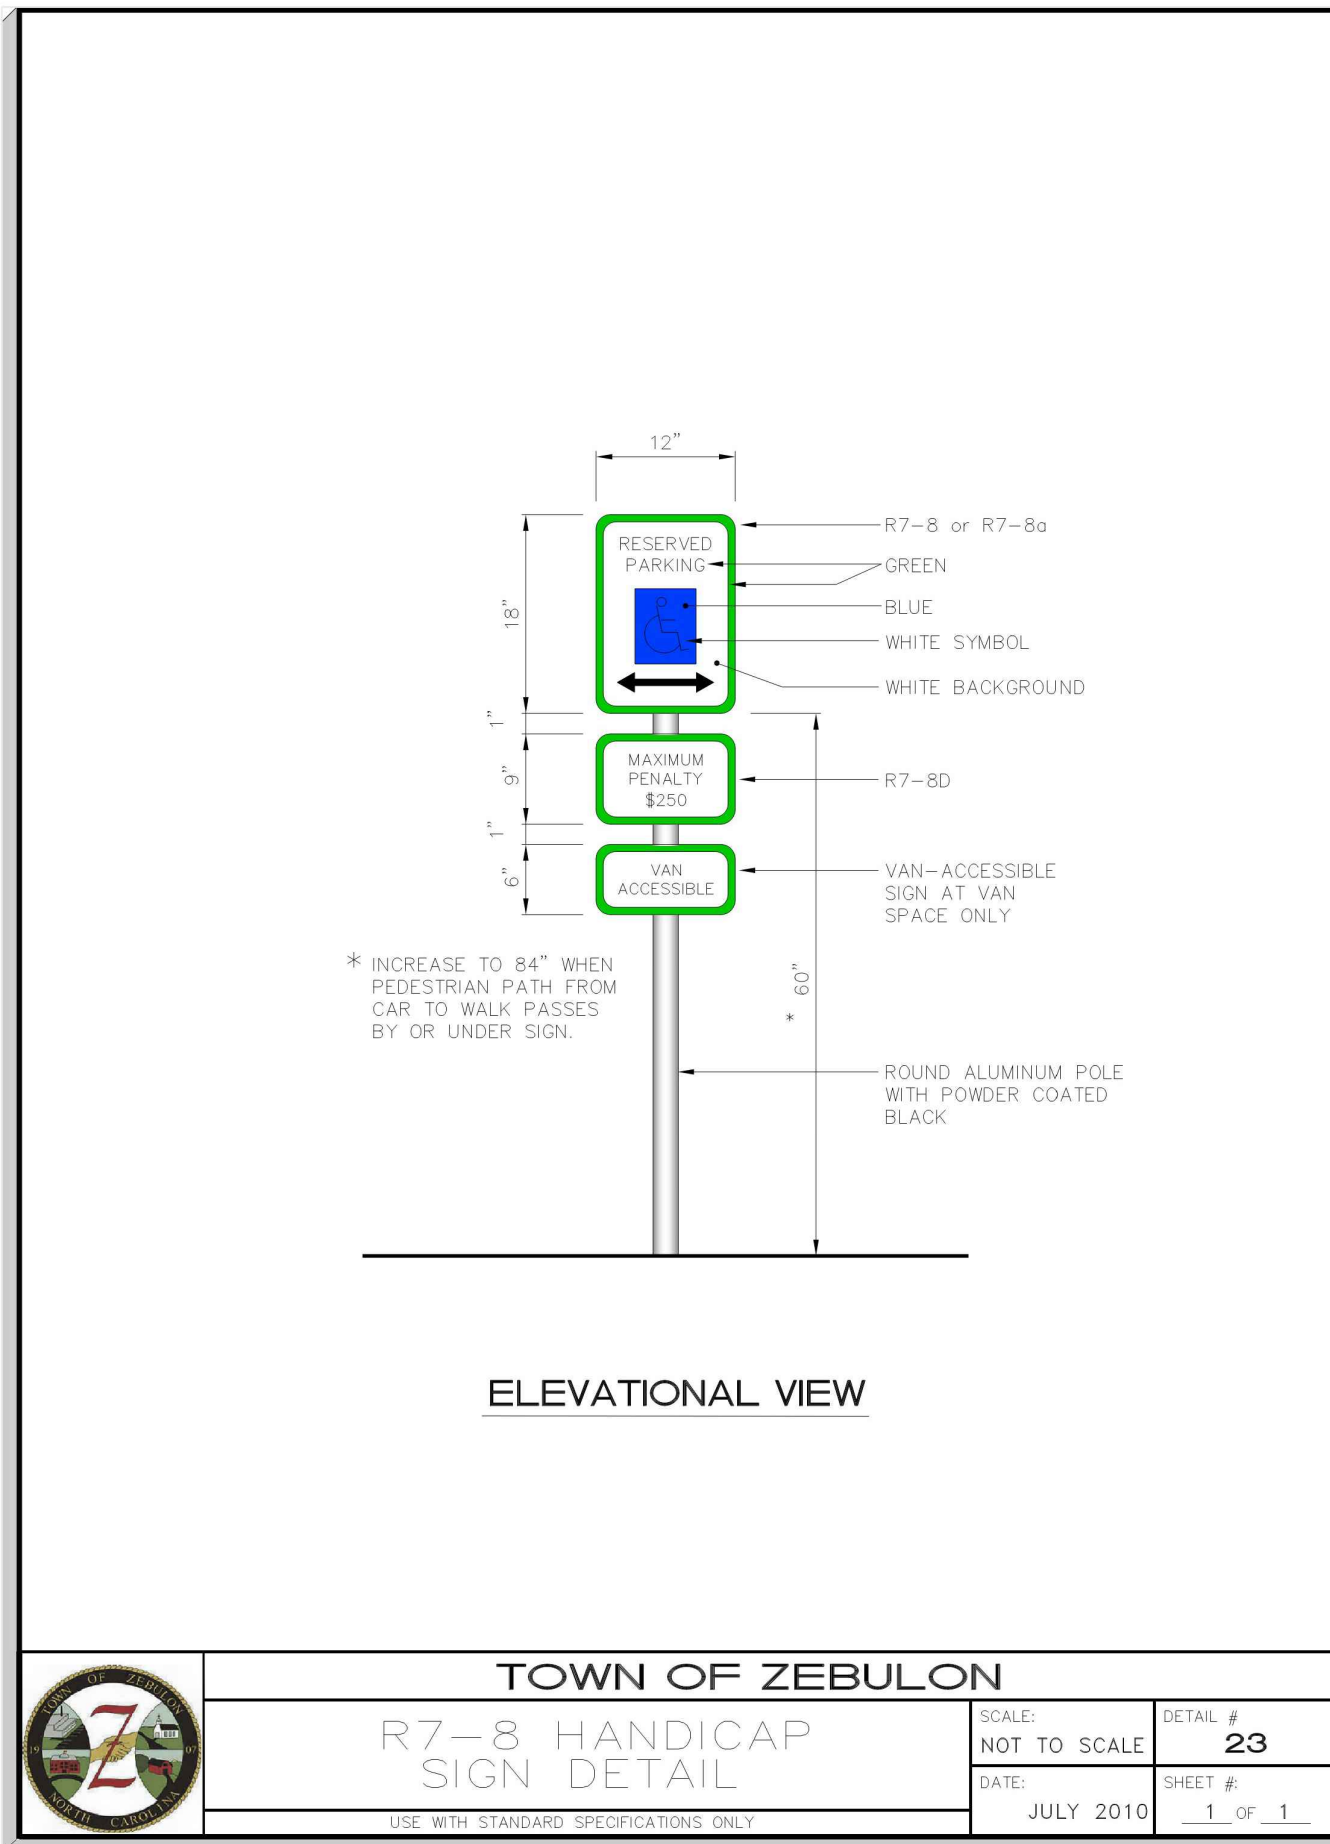


2 R7-8 HANDICAP SIGN N.T.S.

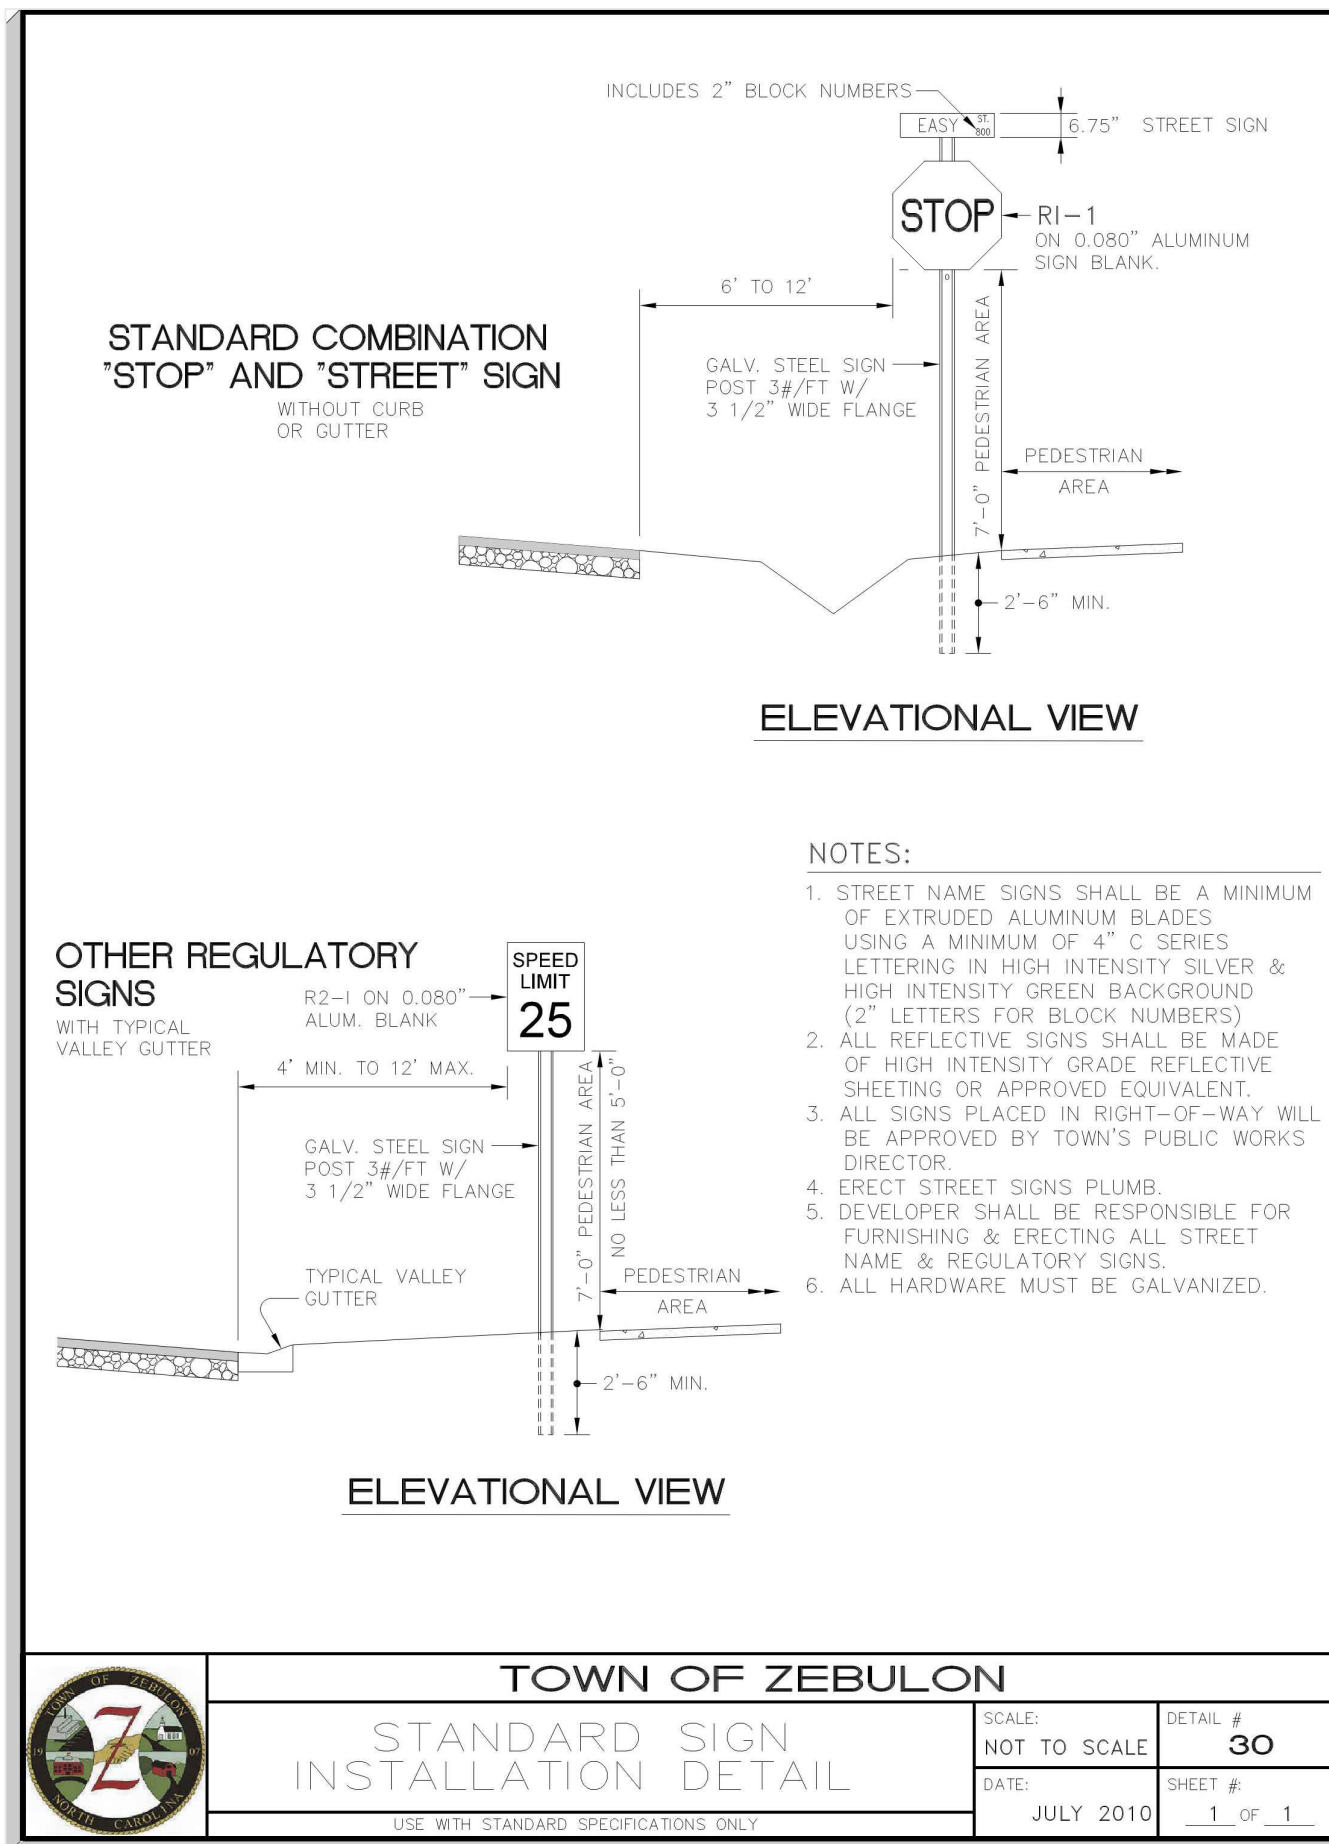

3 STANDARD SIGN INSTALLATION N.T.S.

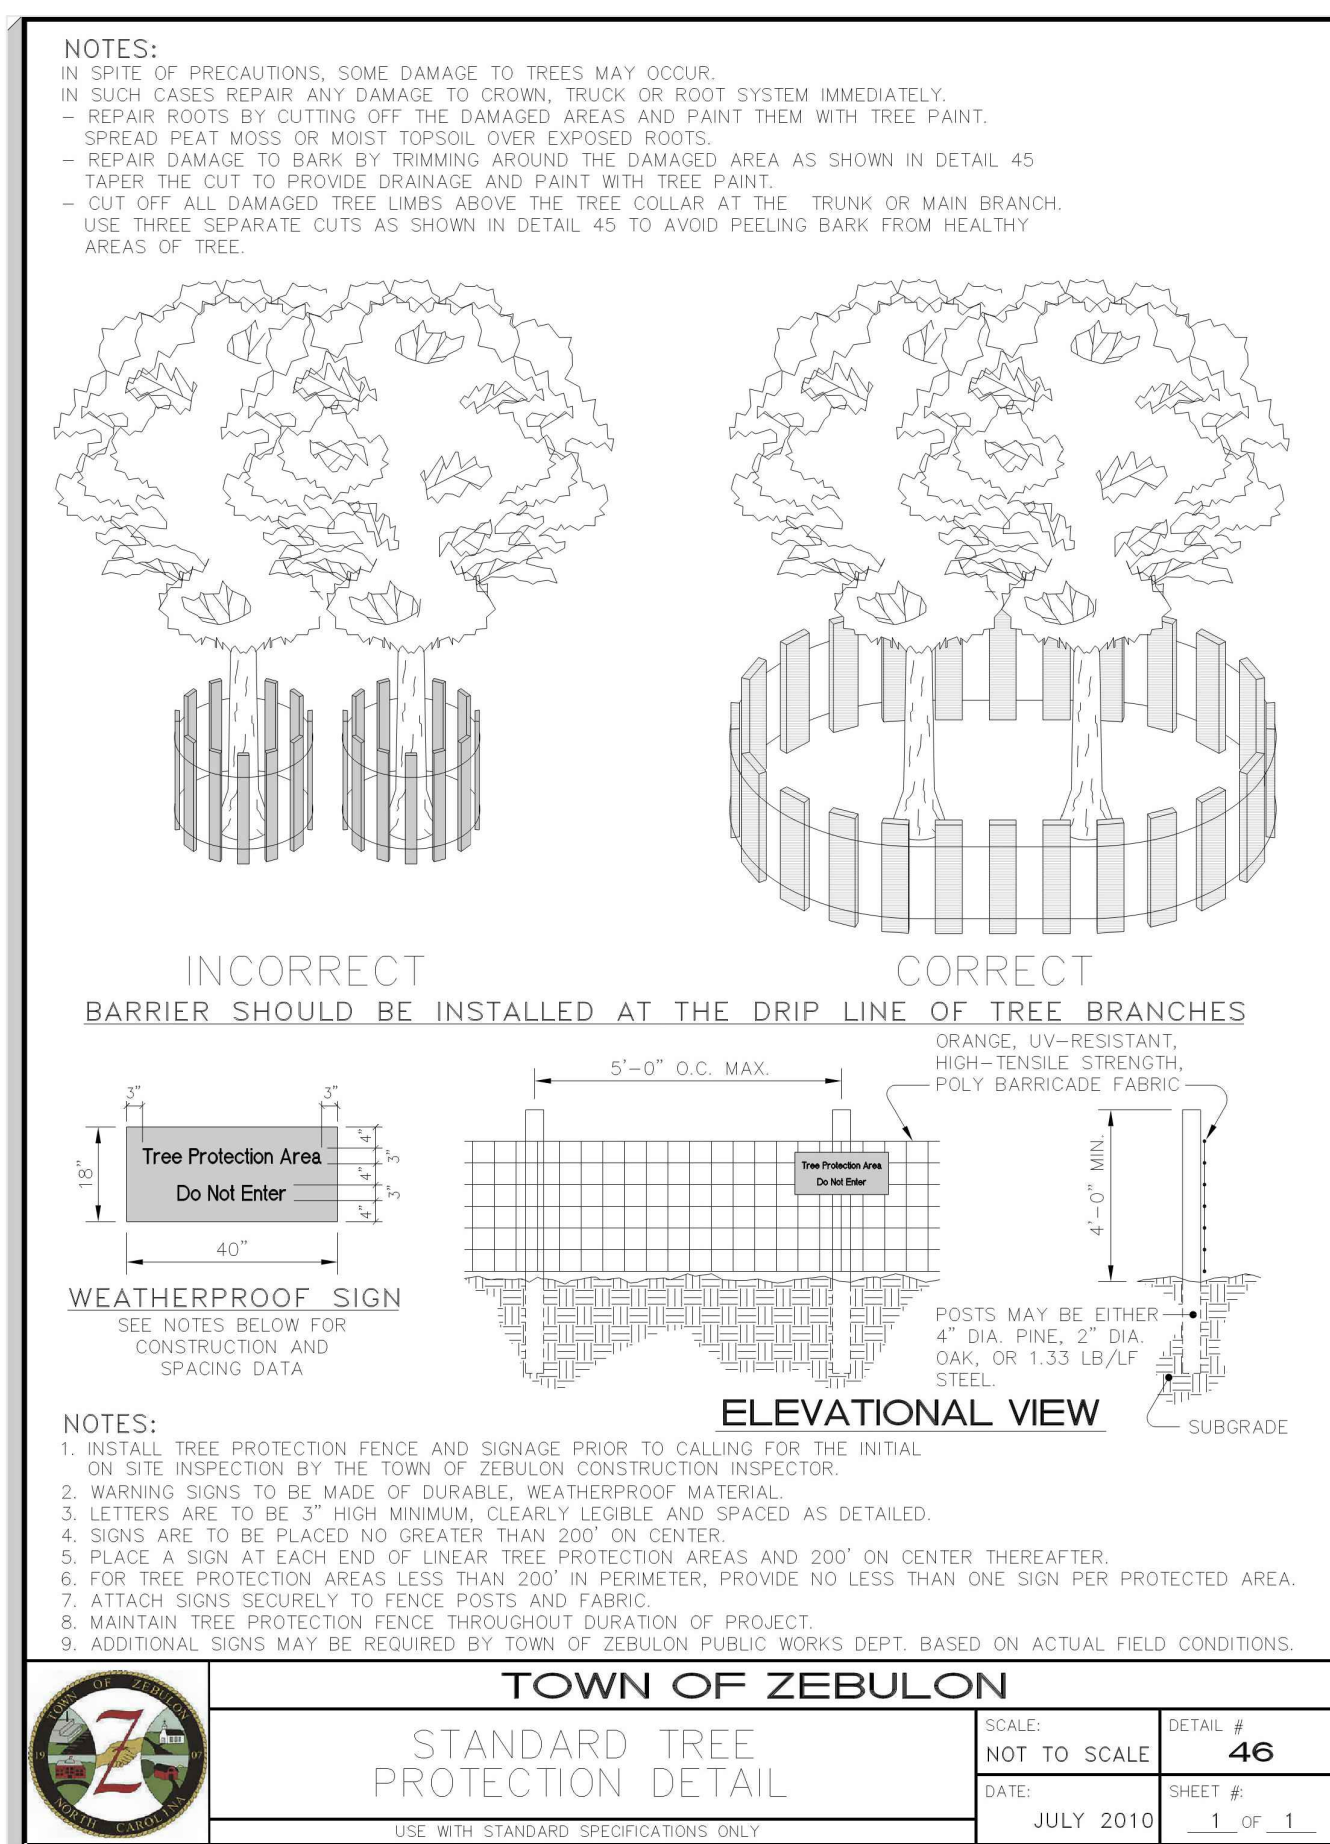

4 STANDARD TREE PROTECTION N.T.S.

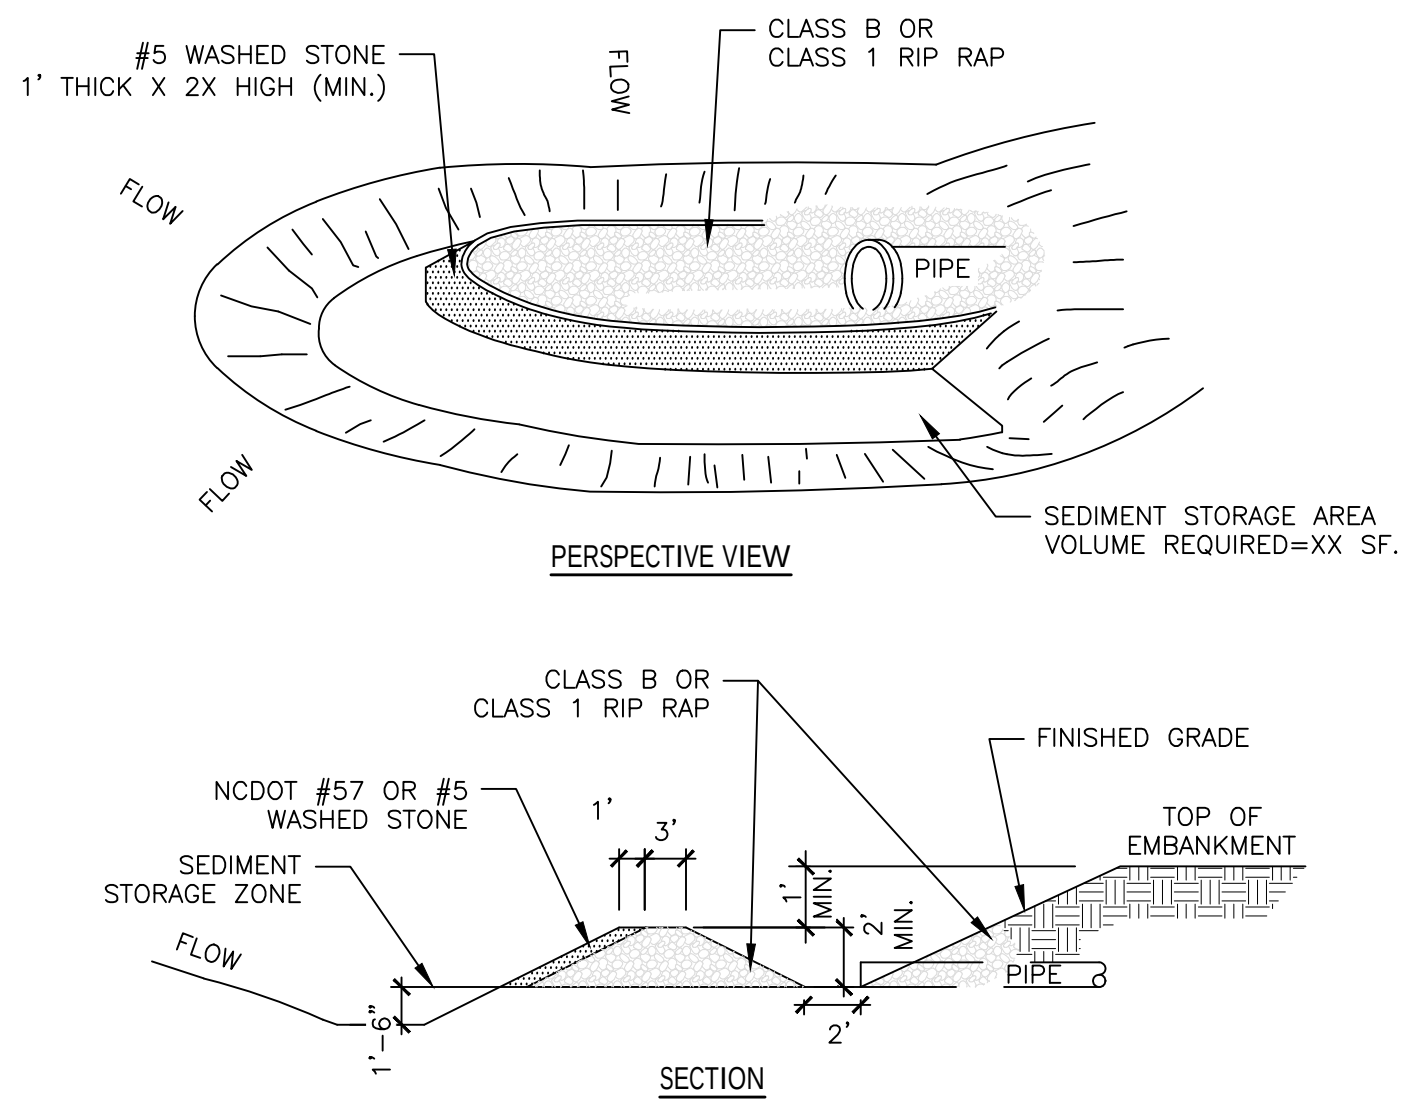


CONSTRUCTION SPECIFICATIONS

- CLEAR THE AREA OF ALL DEBRIS THAT MIGHT HINDER EXCAVATION AND DISPOSAL OF 'SPILL'.
- INSTALL THE CLASS B OR CLASS 1 RIP RAP IN A SEMI-CIRCLE AROUND THE PIPE INLET. THE STONE SHOULD BE BUILT UP HIGHER ON EACH END WHERE IT MEETS INTO THE EMBANKMENT THAN TO ITS ORIGINAL DIMENSIONS WHEN THE SEDIMENT HAS ACCUMULATED TO ONE-HALF THE DESIGN DEPTH OF THE TRAP. PLACE THE SEDIMENT THAT IS REMOVED IN THE DESIGNATED DISPOSAL AREA AND REPLACE THE CONTAMINATED PART OF THE GRAVEL FACING.
- CHECK THE STRUCTURE FOR DAMAGE. ANY RIPRAP DISPLACED FROM THE STONE HORSESHOE MUST BE REPLACED IMMEDIATELY.
- AFTER ALL THE SEDIMENT-PRODUCING AREAS HAVE BEEN PERMANENTLY STABILIZED, REMOVE THE STRUCTURE AND ALL THE UNSTABLE SEDIMENT. SMOOTH THE AREA TO BLEND WITH THE ADJOINING AREAS AND PROVIDE PERMANENT GROUND COVER.

MAINTENANCE REQUIREMENTS

- INSPECT ROCK PIPE INLET PROTECTION AT LEAST WEEKLY AND AFTER EACH SIGNIFICANT (QUINCH OR GREATER) RAINFALL EVENT AND REMOVE IMMEDIATELY. REMOVE SEDIMENT AND RESTORE THE SEDIMENT STORAGE AREA TO ITS ORIGINAL DIMENSIONS WHEN THE SEDIMENT HAS ACCUMULATED TO ONE-HALF THE DESIGN DEPTH OF THE TRAP. PLACE THE SEDIMENT THAT IS REMOVED IN THE DESIGNATED DISPOSAL AREA AND REPLACE THE CONTAMINATED PART OF THE GRAVEL FACING.
- CHECK THE STRUCTURE FOR DAMAGE. ANY RIPRAP DISPLACED FROM THE STONE HORSESHOE MUST BE REPLACED IMMEDIATELY.
- AFTER ALL THE SEDIMENT-PRODUCING AREAS HAVE BEEN PERMANENTLY STABILIZED, REMOVE THE STRUCTURE AND ALL THE UNSTABLE SEDIMENT. SMOOTH THE AREA TO BLEND WITH THE ADJOINING AREAS AND PROVIDE PERMANENT GROUND COVER.

7 TEMPORARY FILTER BERM BASIN NCDEQ STD. 6.55

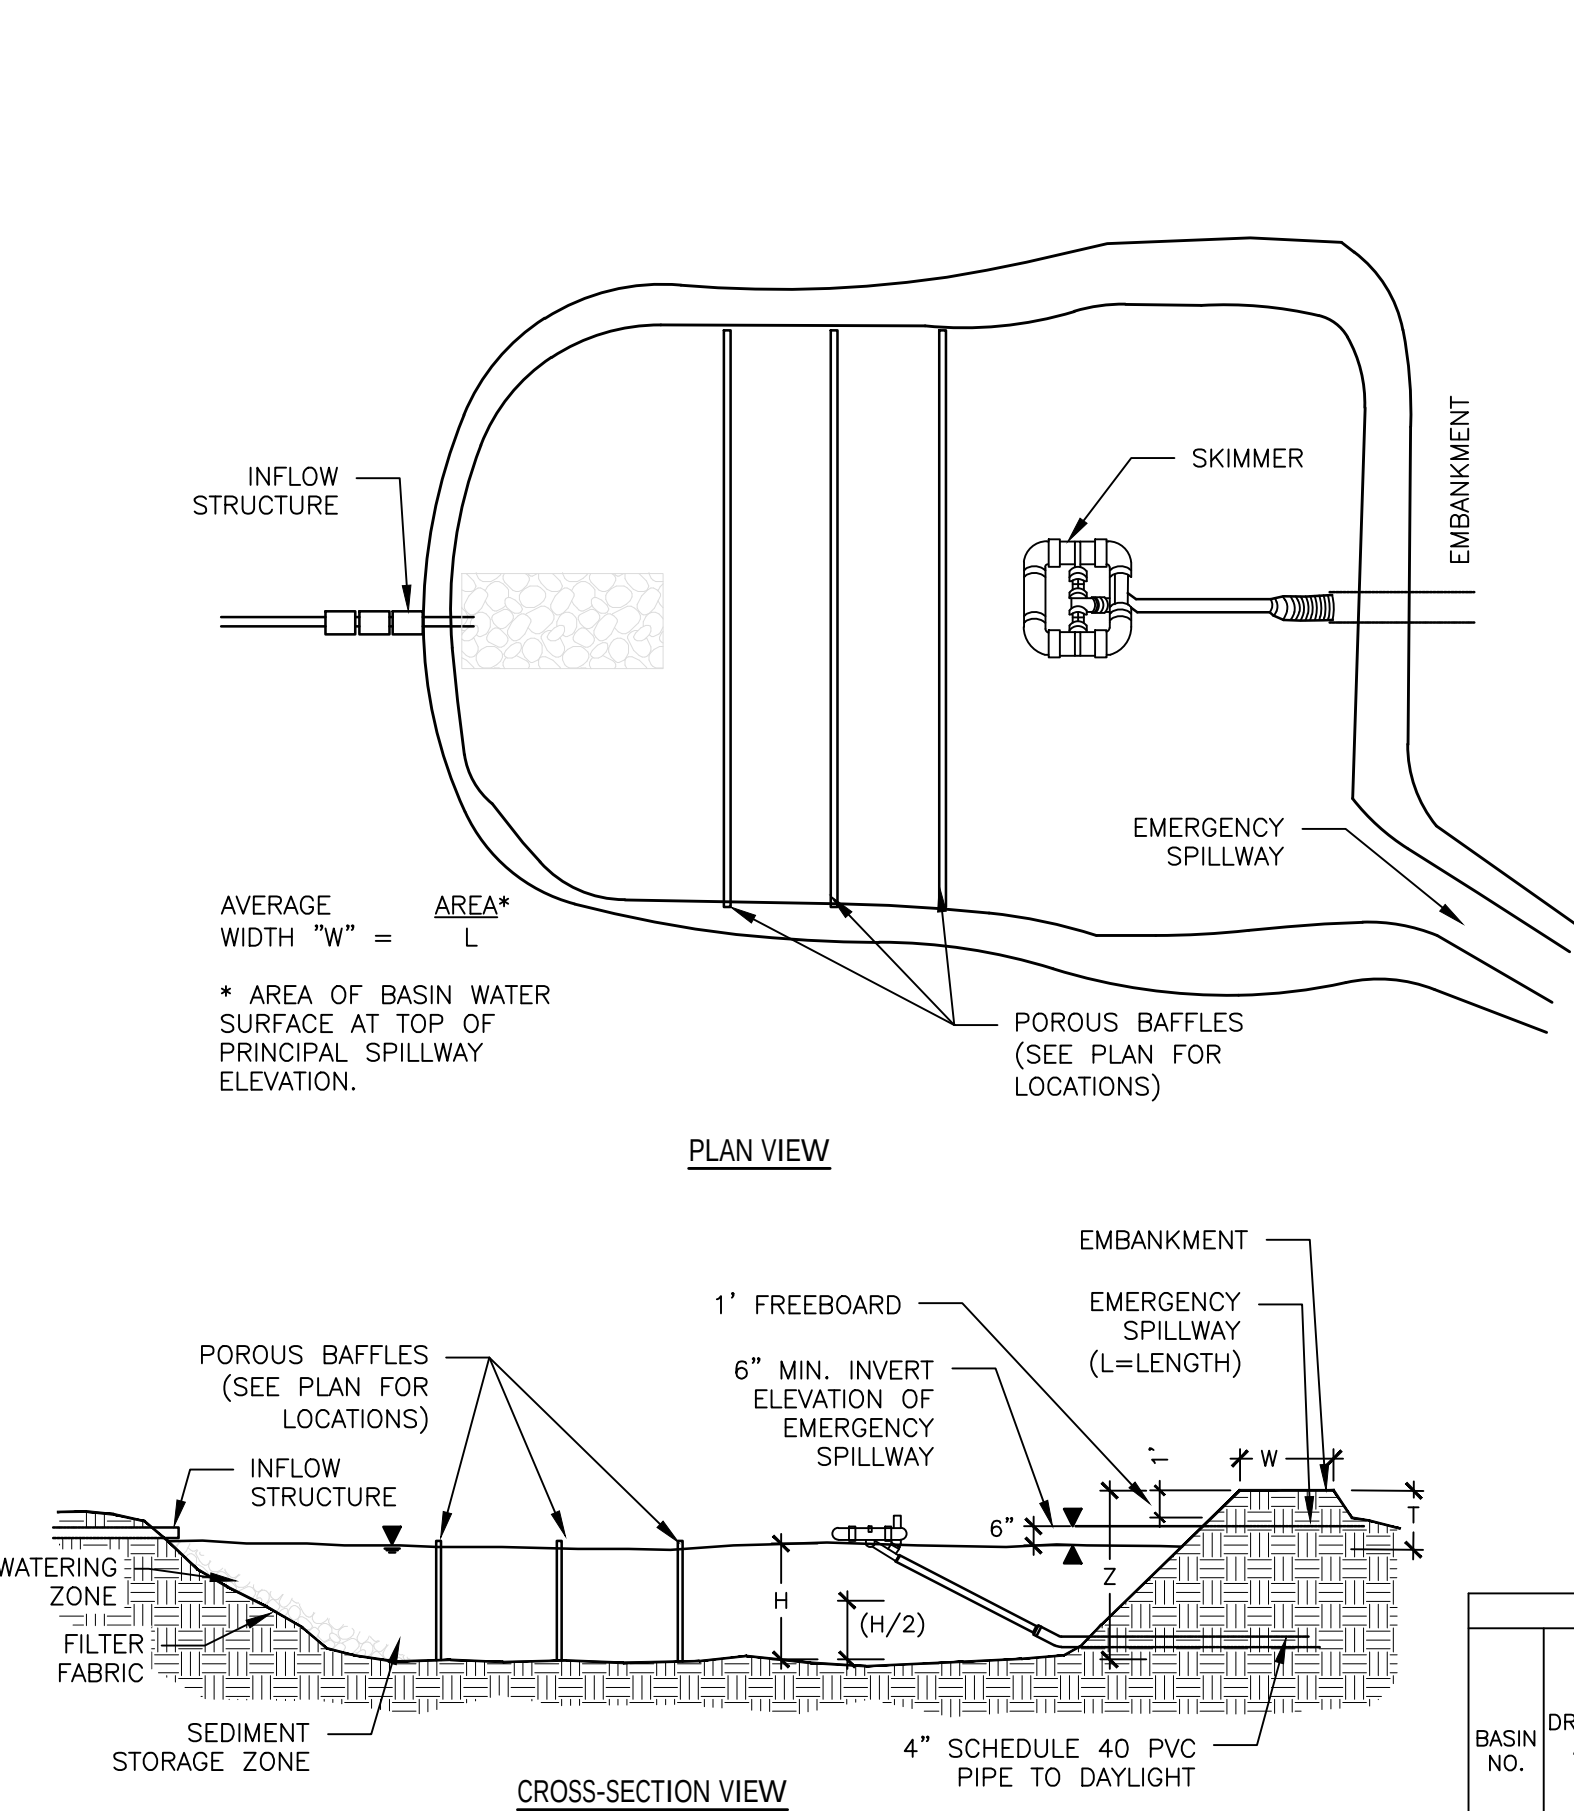

8 Temporary Skimmer Basin NCDEQ STD. 6.64

DATA BLOCK									
BASIN NO.	DRAINAGE AREA (AC.)	DENIED AREA (AC.)	Q10 (CFS)	BASIN VOLUME (CU. FT.)	PROVIDE (CU. FT.)	BASIN SURFACE AREA (SQ. FT.)	PROVIDE (SQ. FT.)	CLEANOUT DEPTH (FT.)	H (FEET)
1									
2									

Seals:




Corp. NC License: F-1320

Y:\North Carolina\1705-500672-00_Zebulon_Landmark_Engineering_Docs\Drawings\1705-500672-00-DETAILS.dwg


1 CONSTRUCTION ENTRANCE

N.T.S.

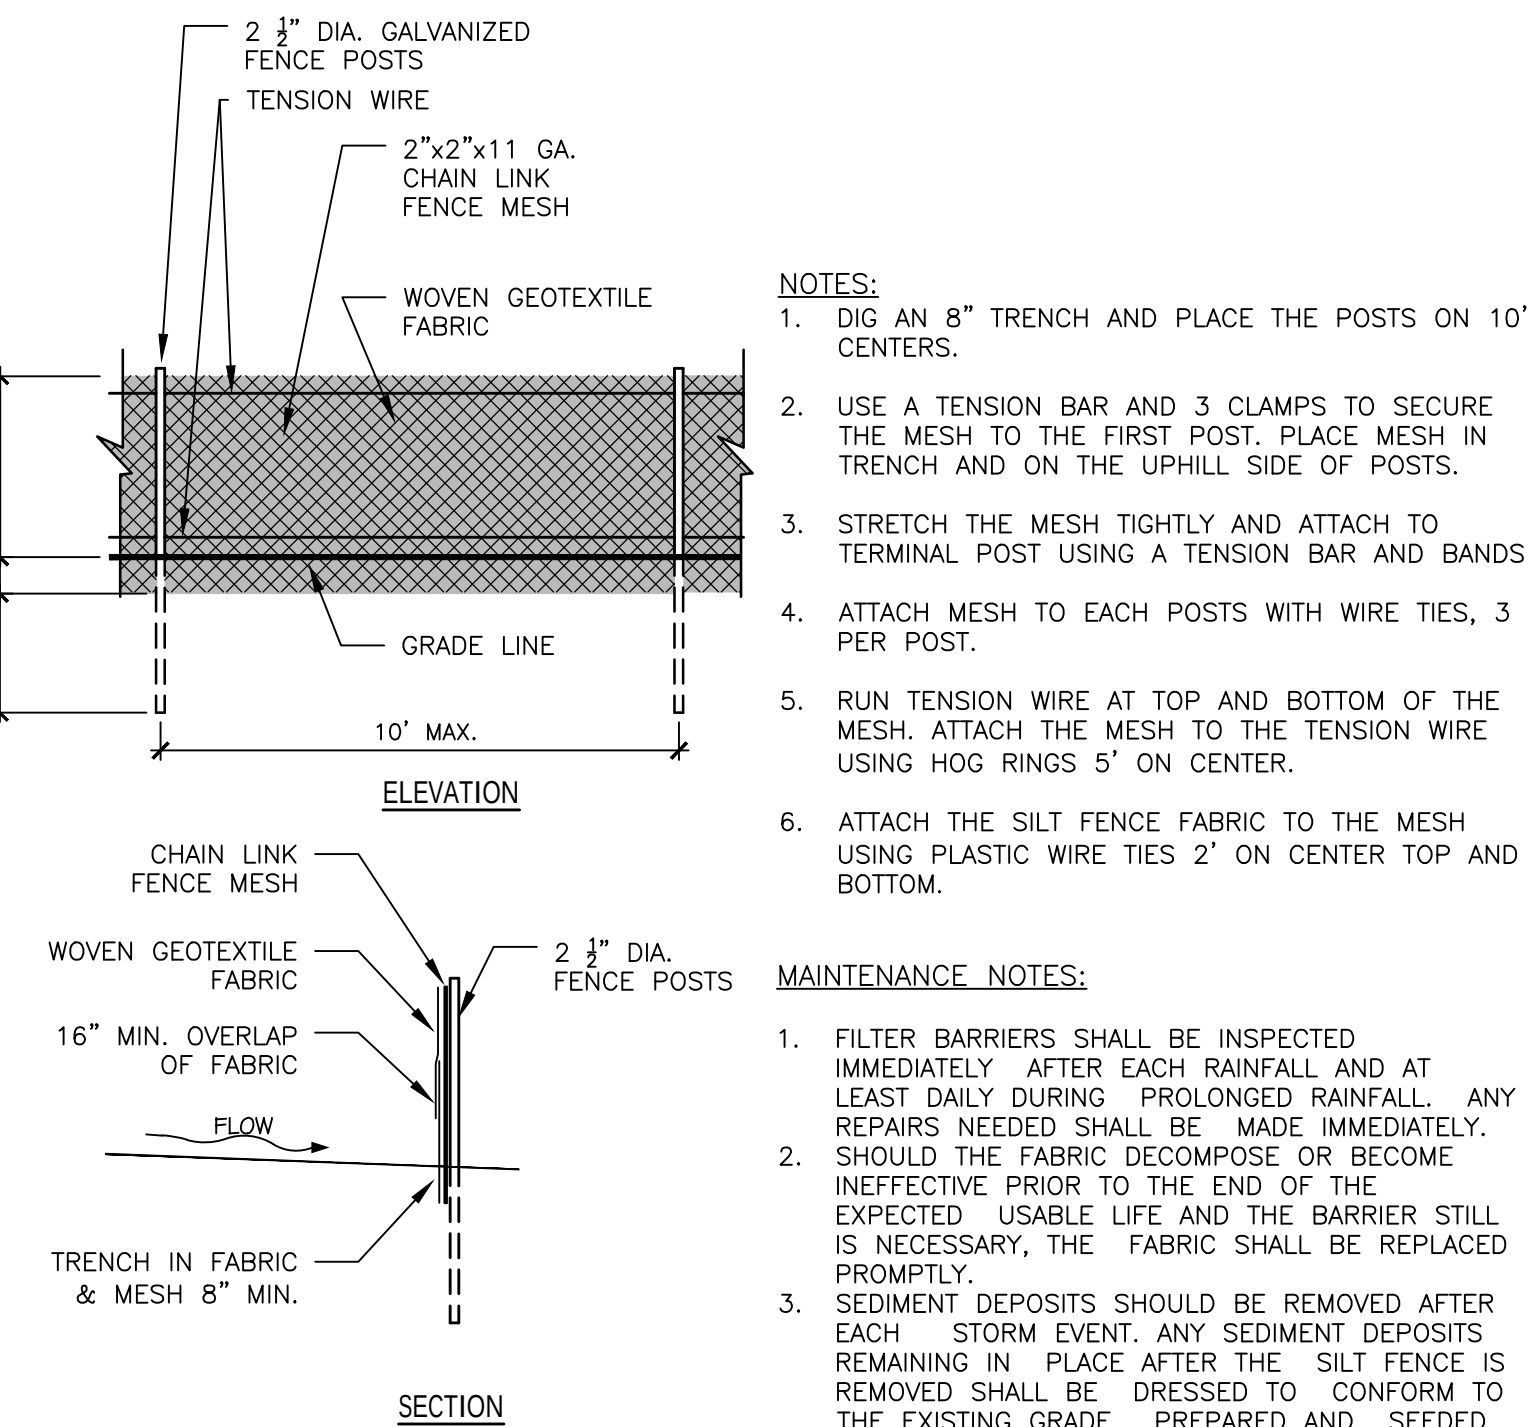

5 TEMPORARY SUPER SILT FENCE

N.T.S.

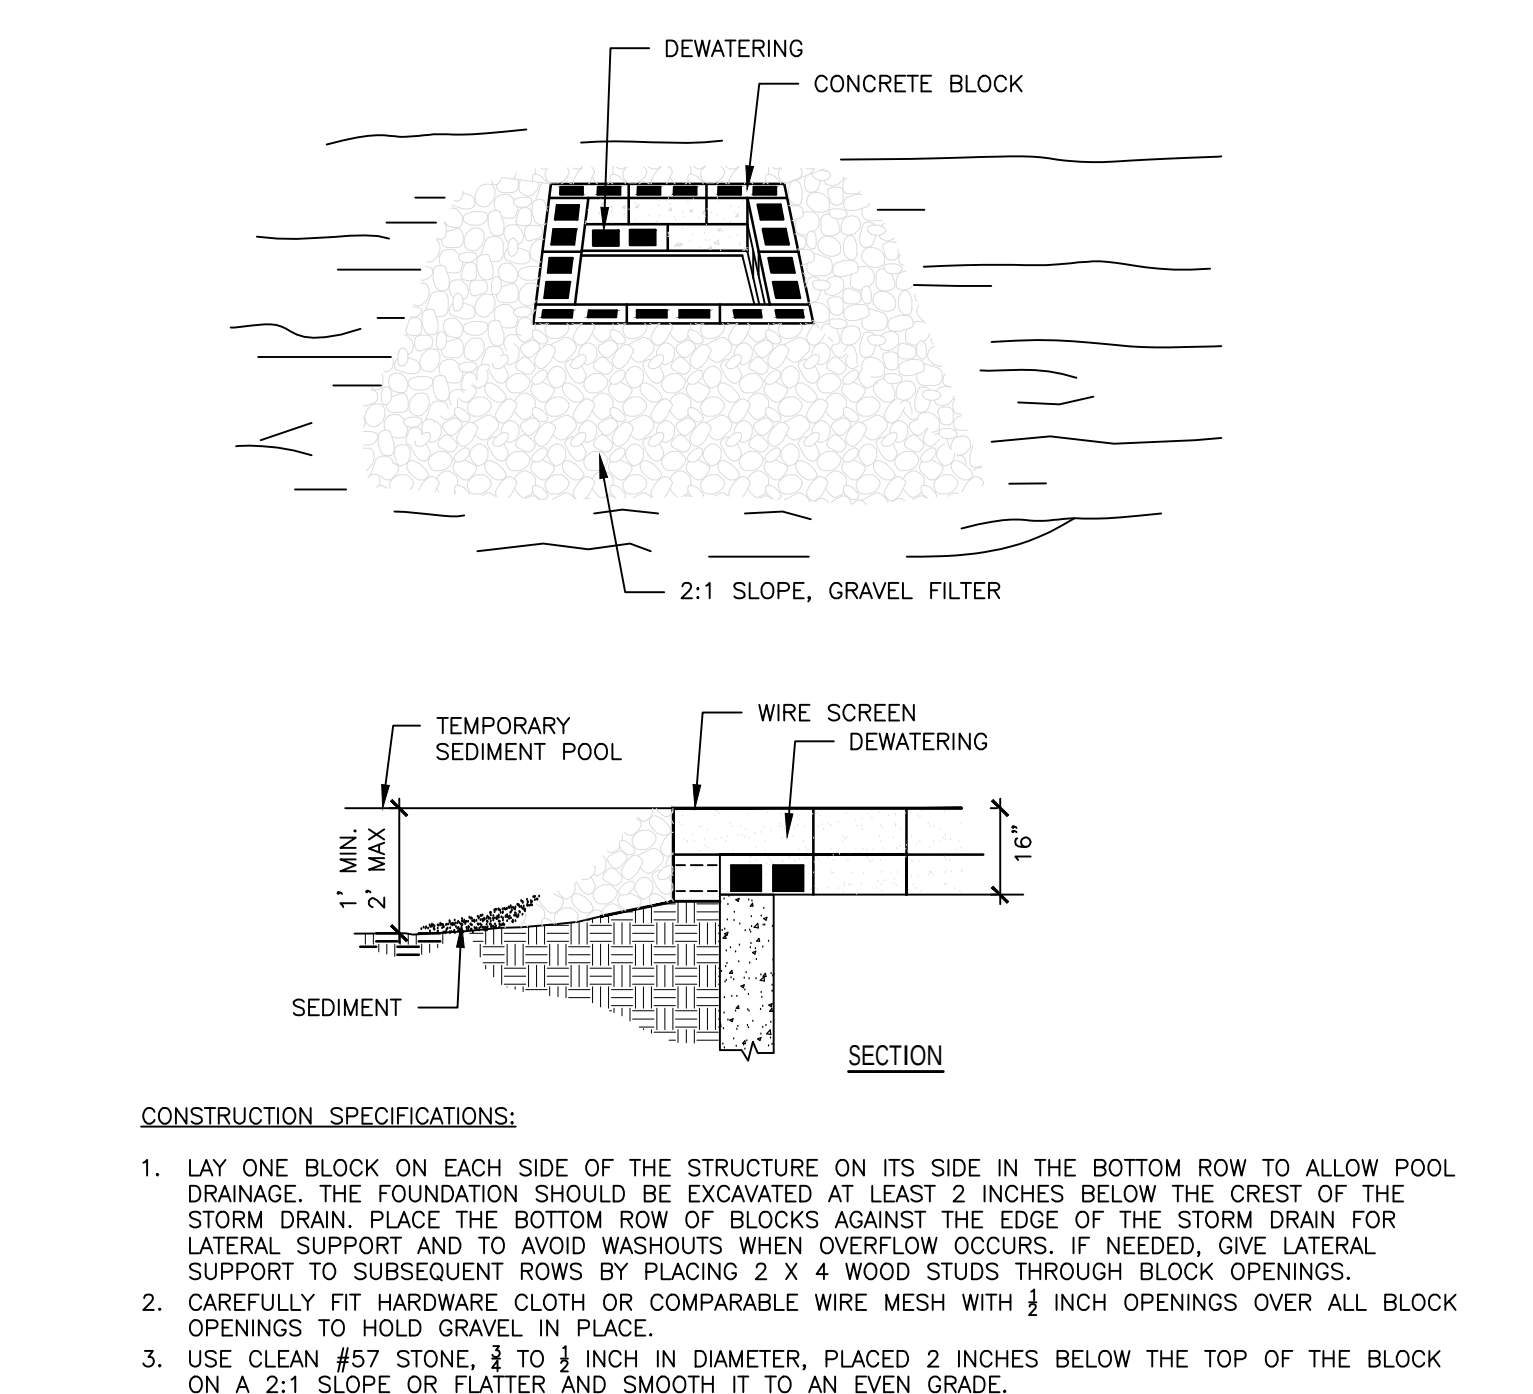


8 BLOCK AND GRAVEL DROP INLET PROTECTION

N.T.S.


2 SILT FENCE

N.T.S.

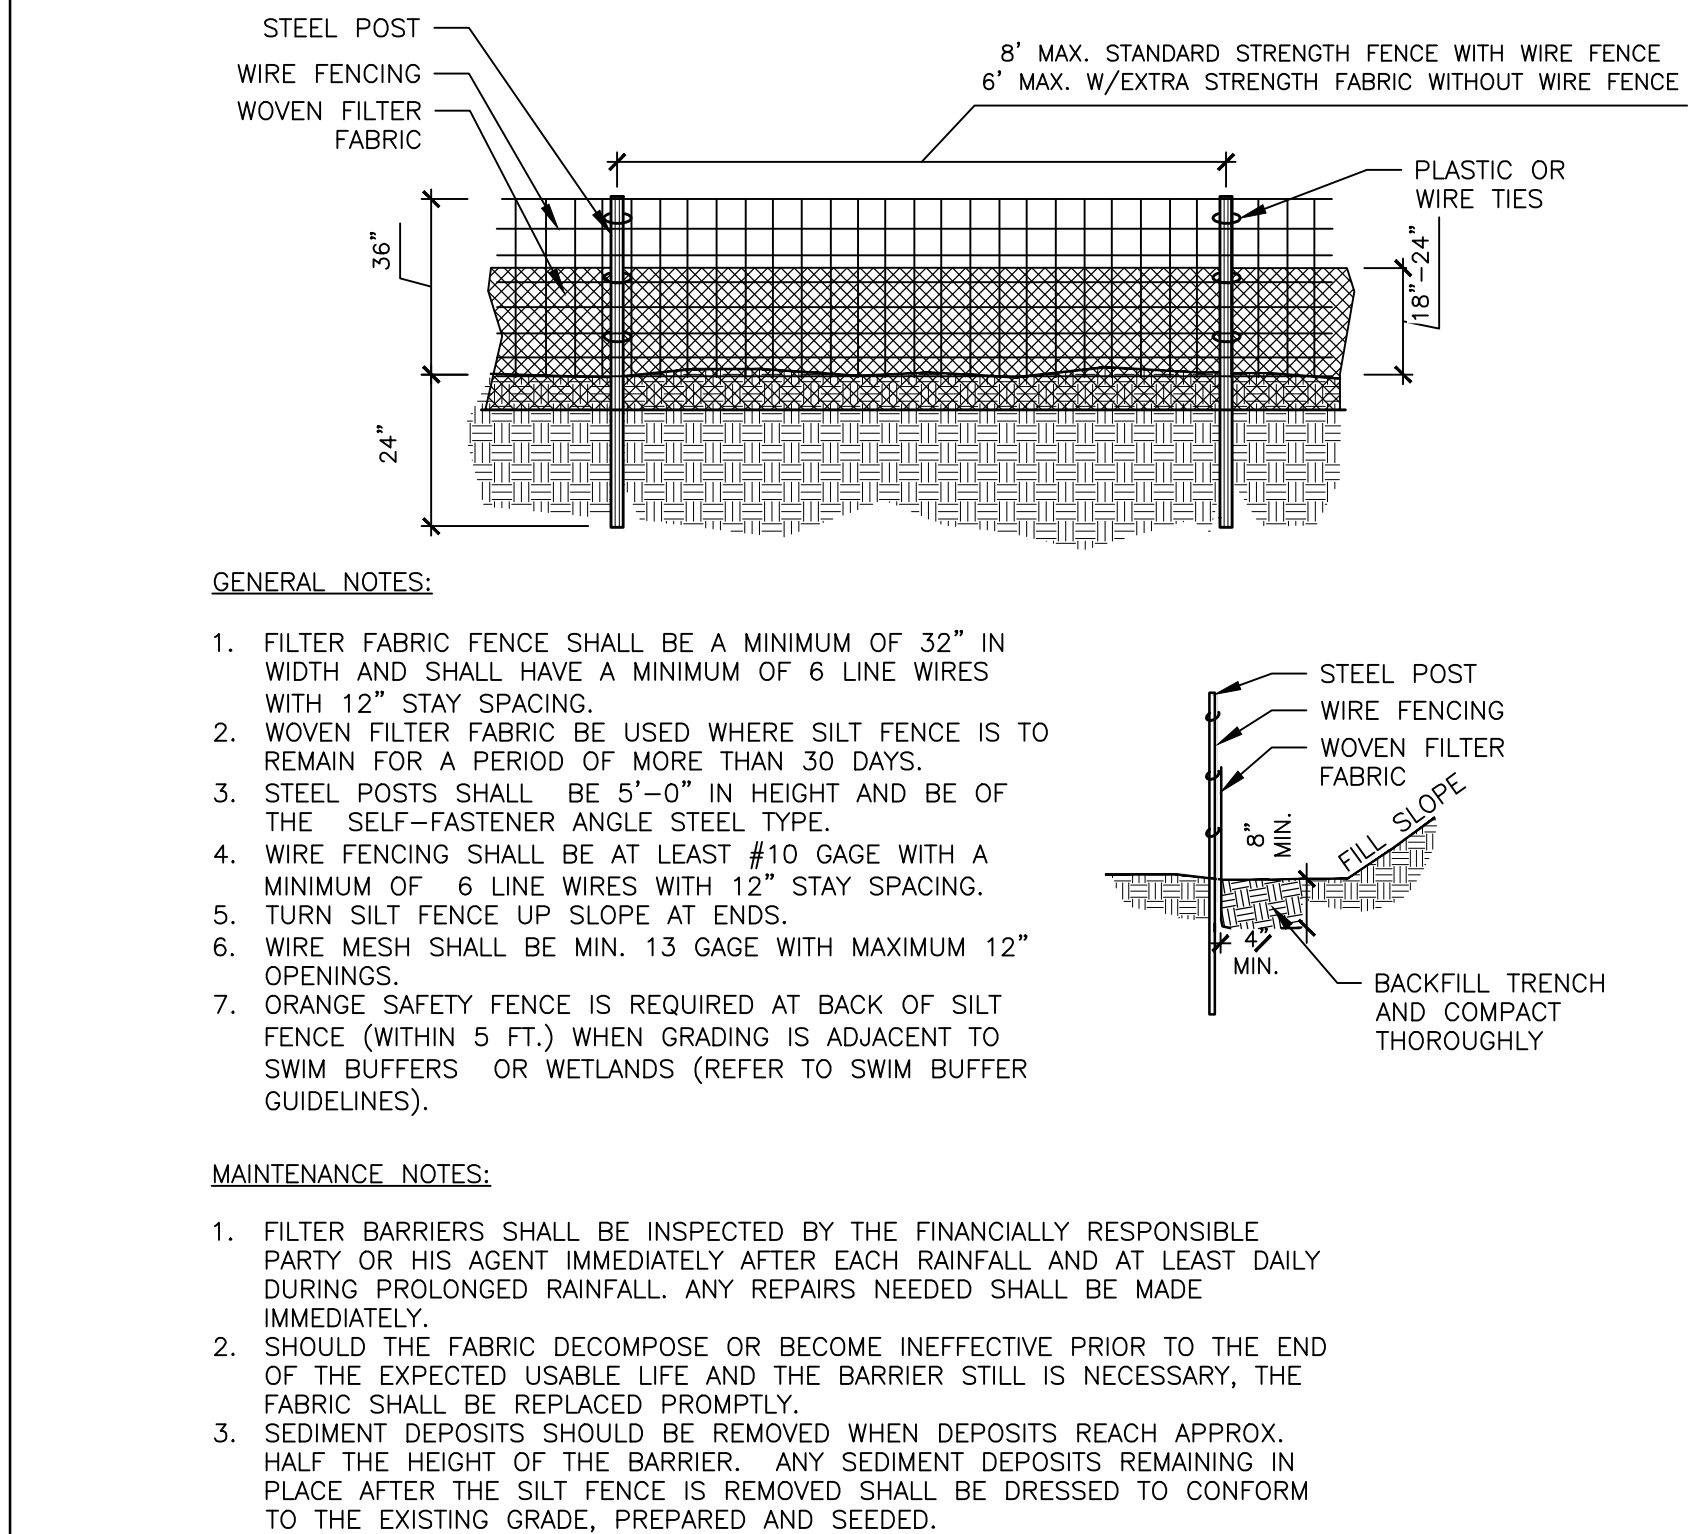


2 SILT FENCE

N.T.S.

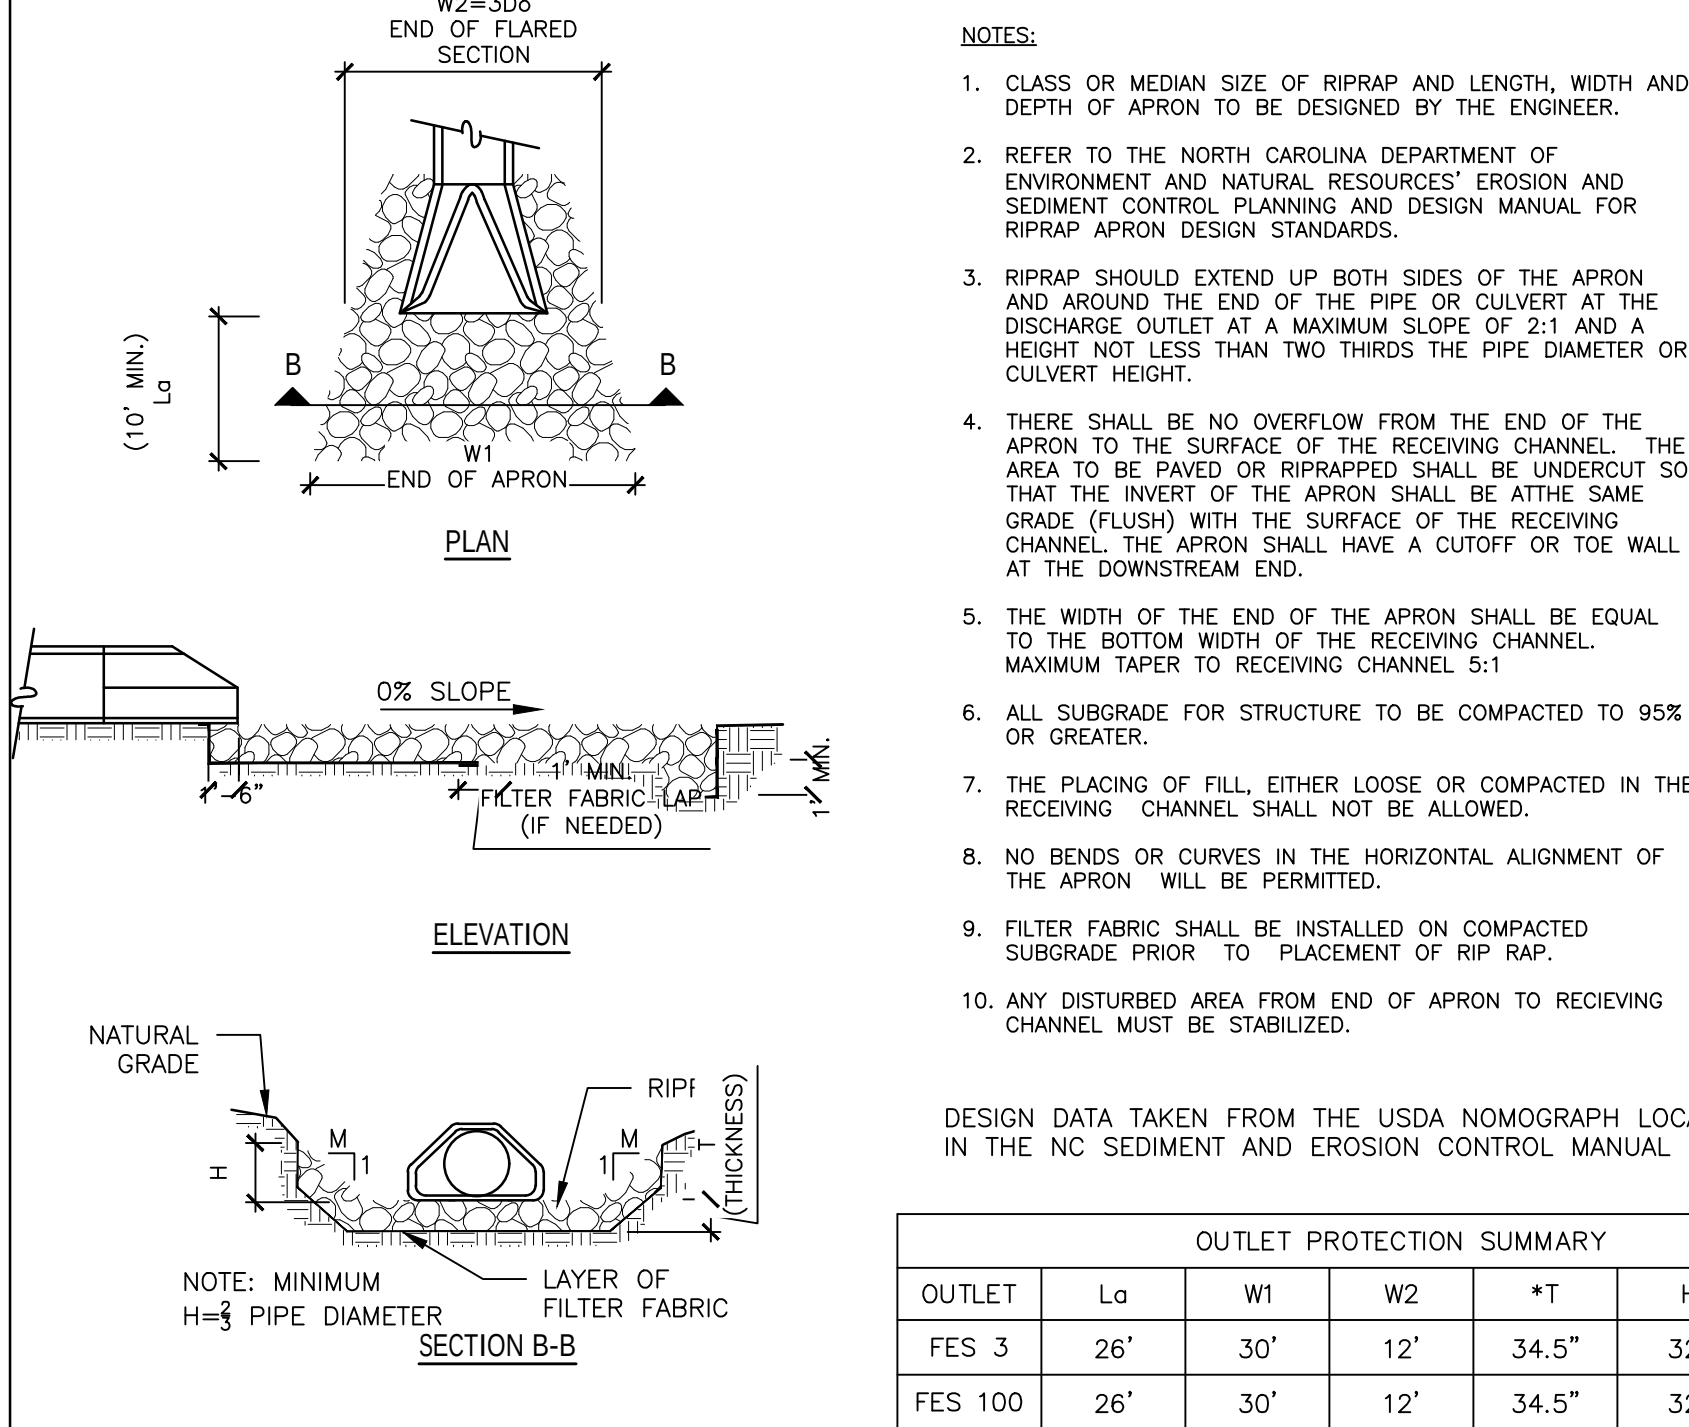

6 OUTLET PROTECTION

N.T.S.

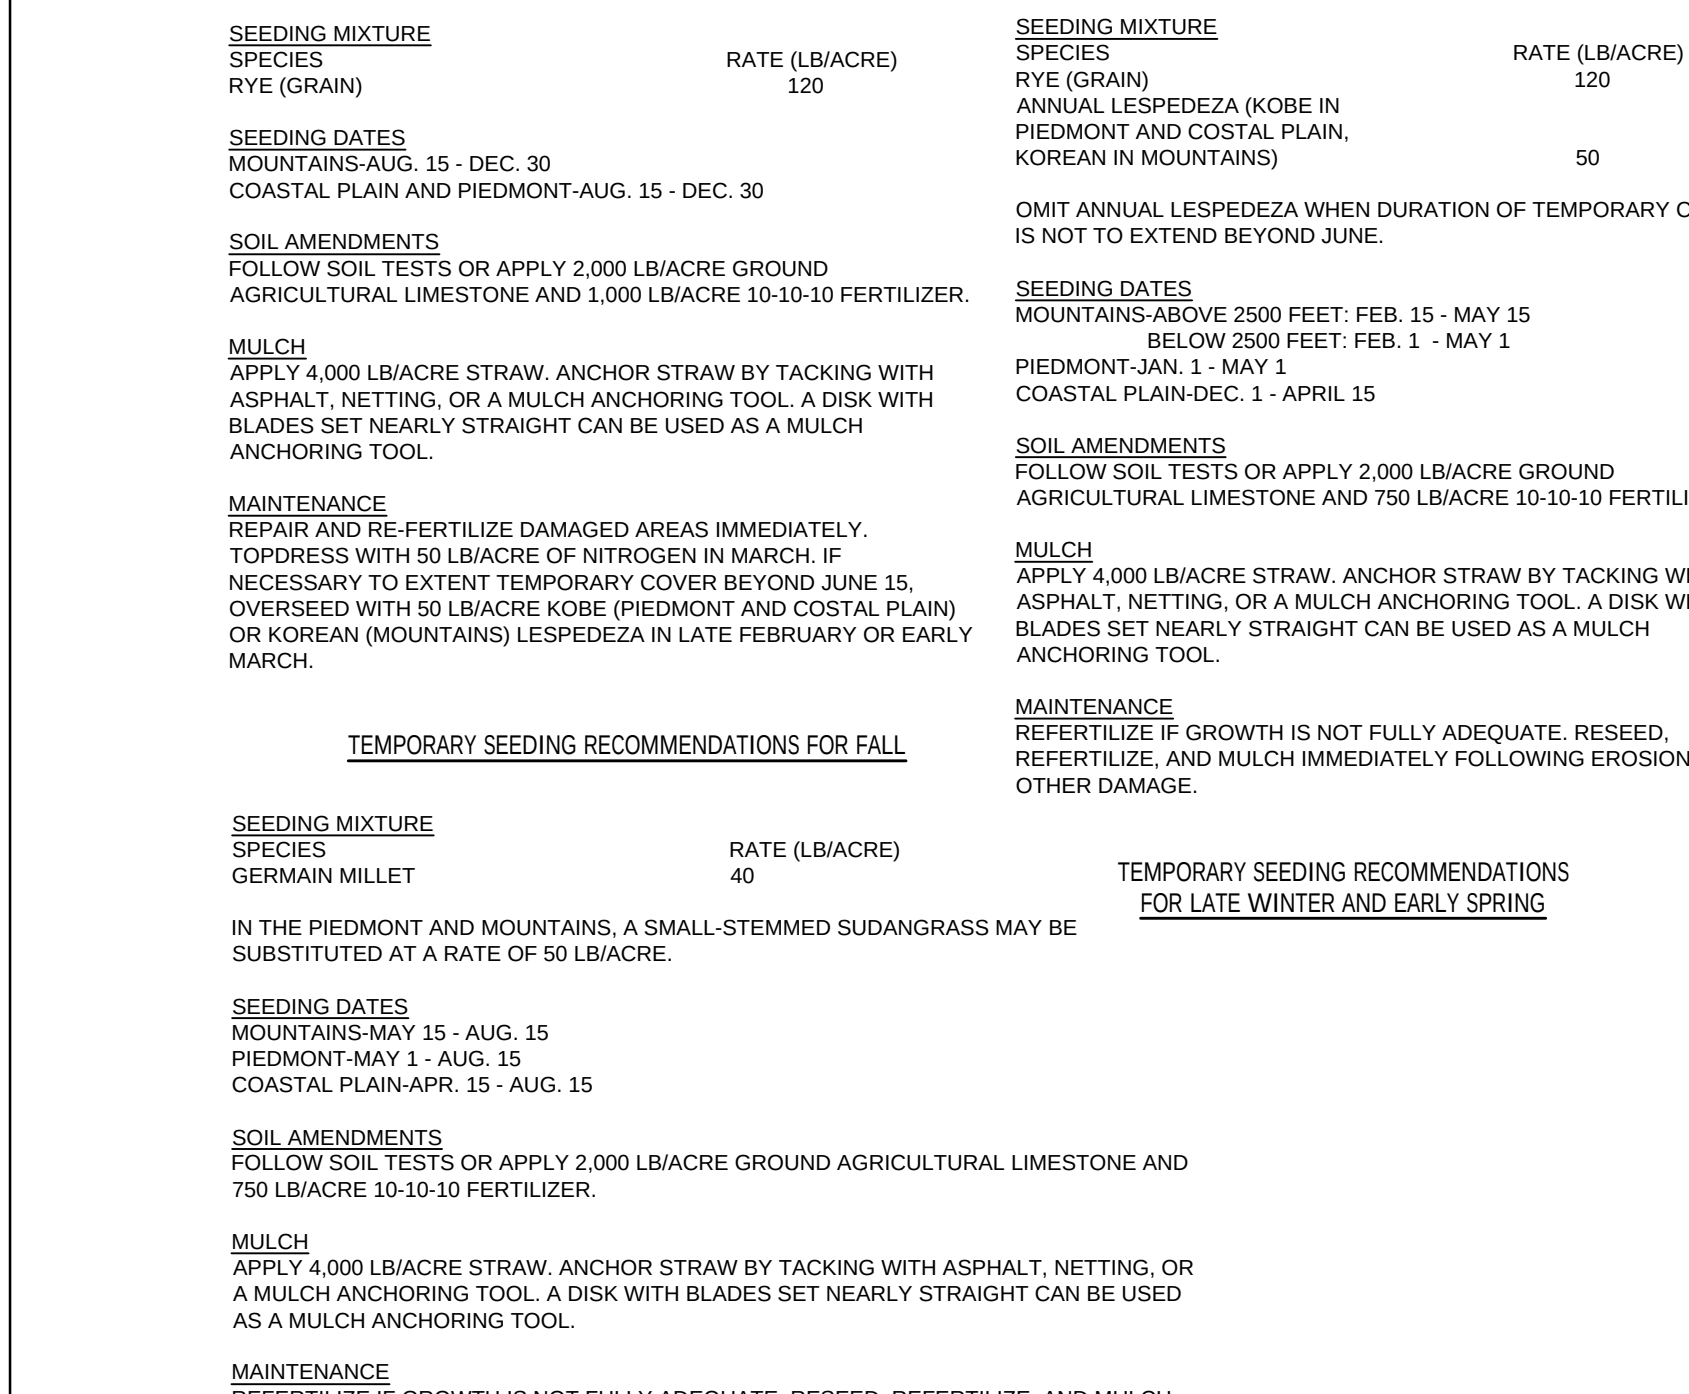


9 TEMPORARY SEEDING SPECIFICATIONS

N.T.S.


3 CHECK DAM

N.T.S.

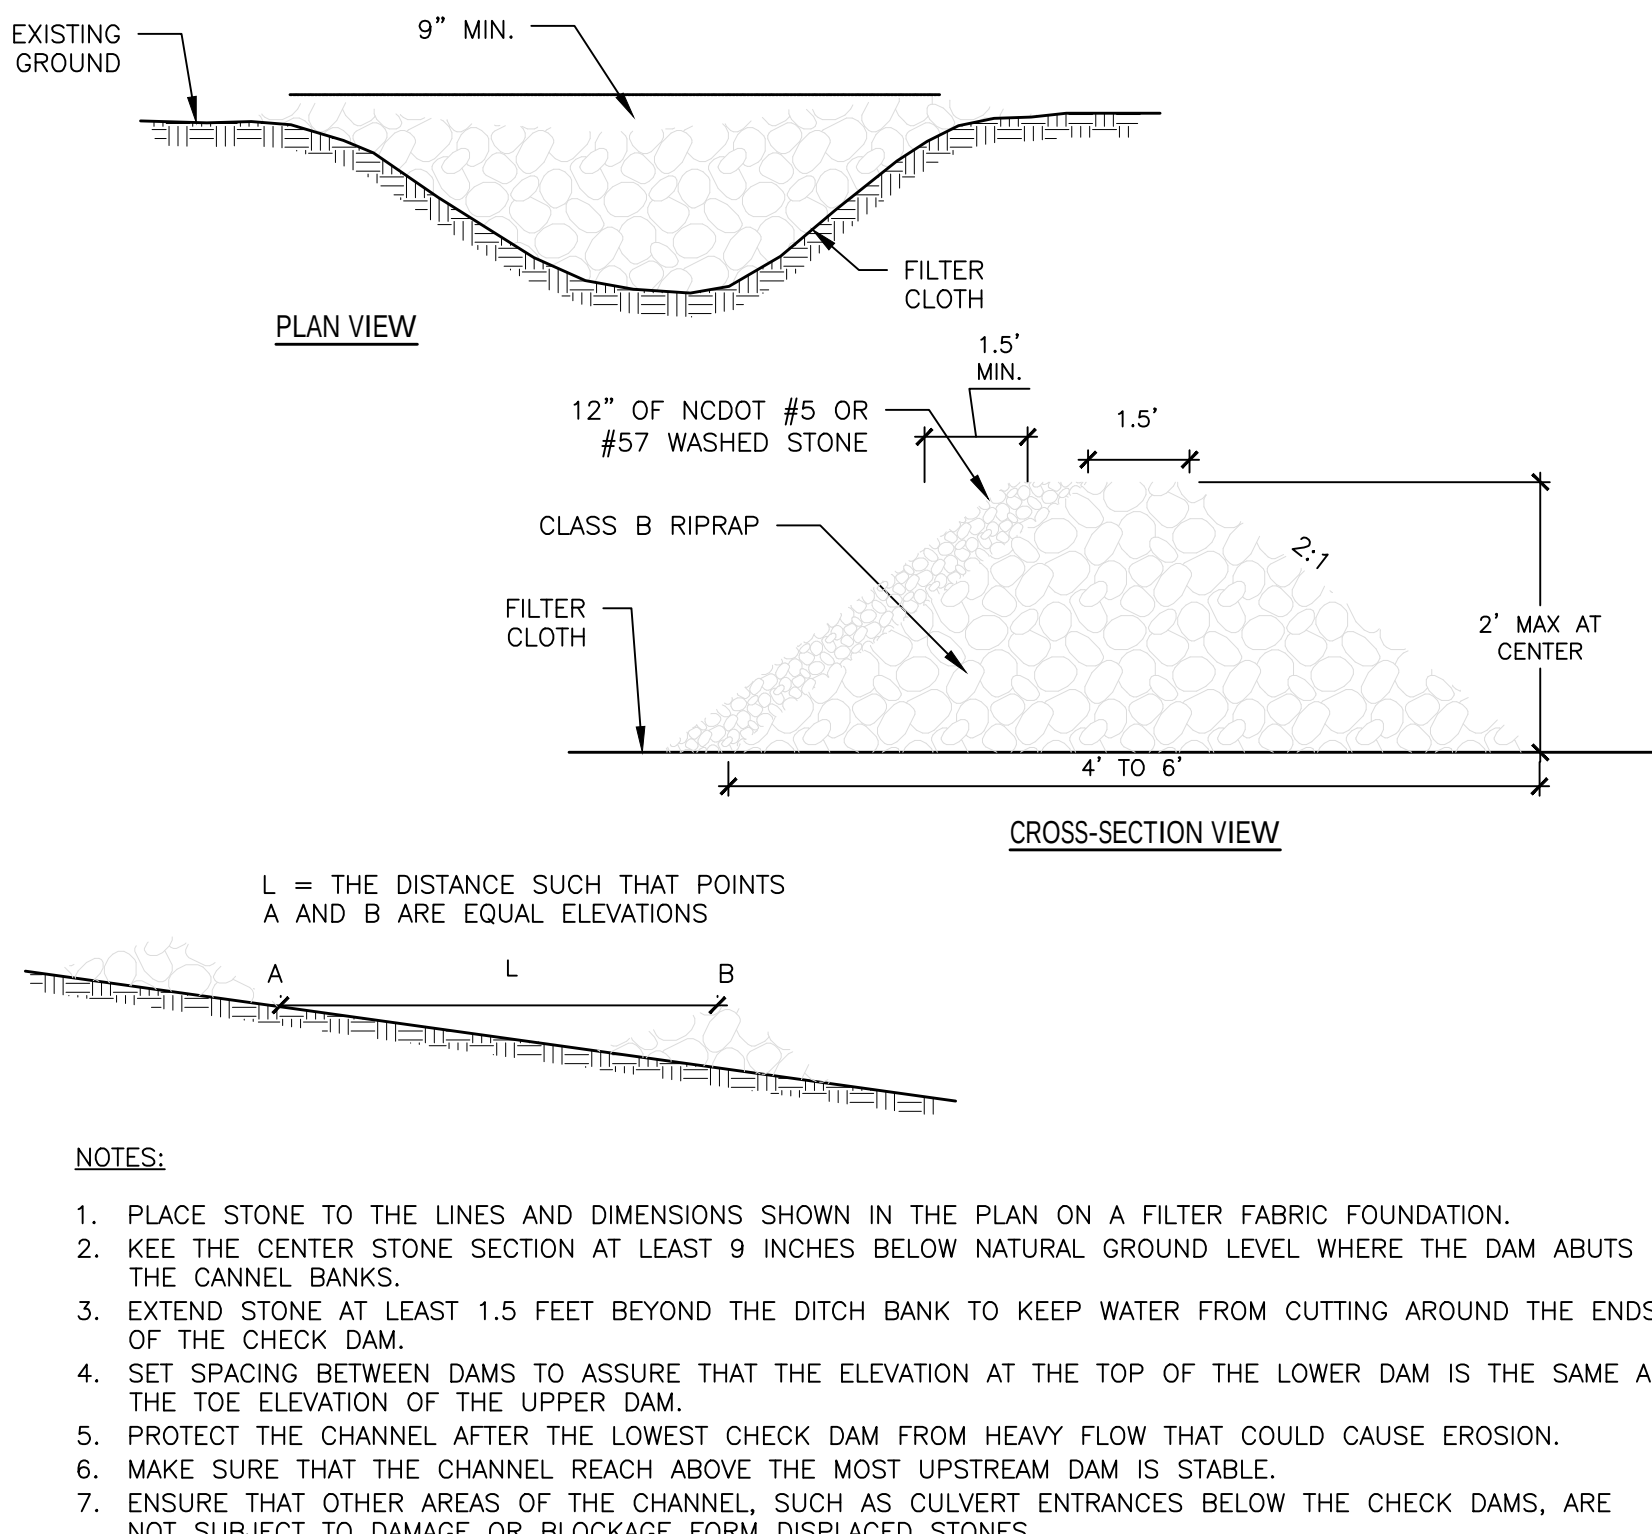


3 CHECK DAM

N.T.S.

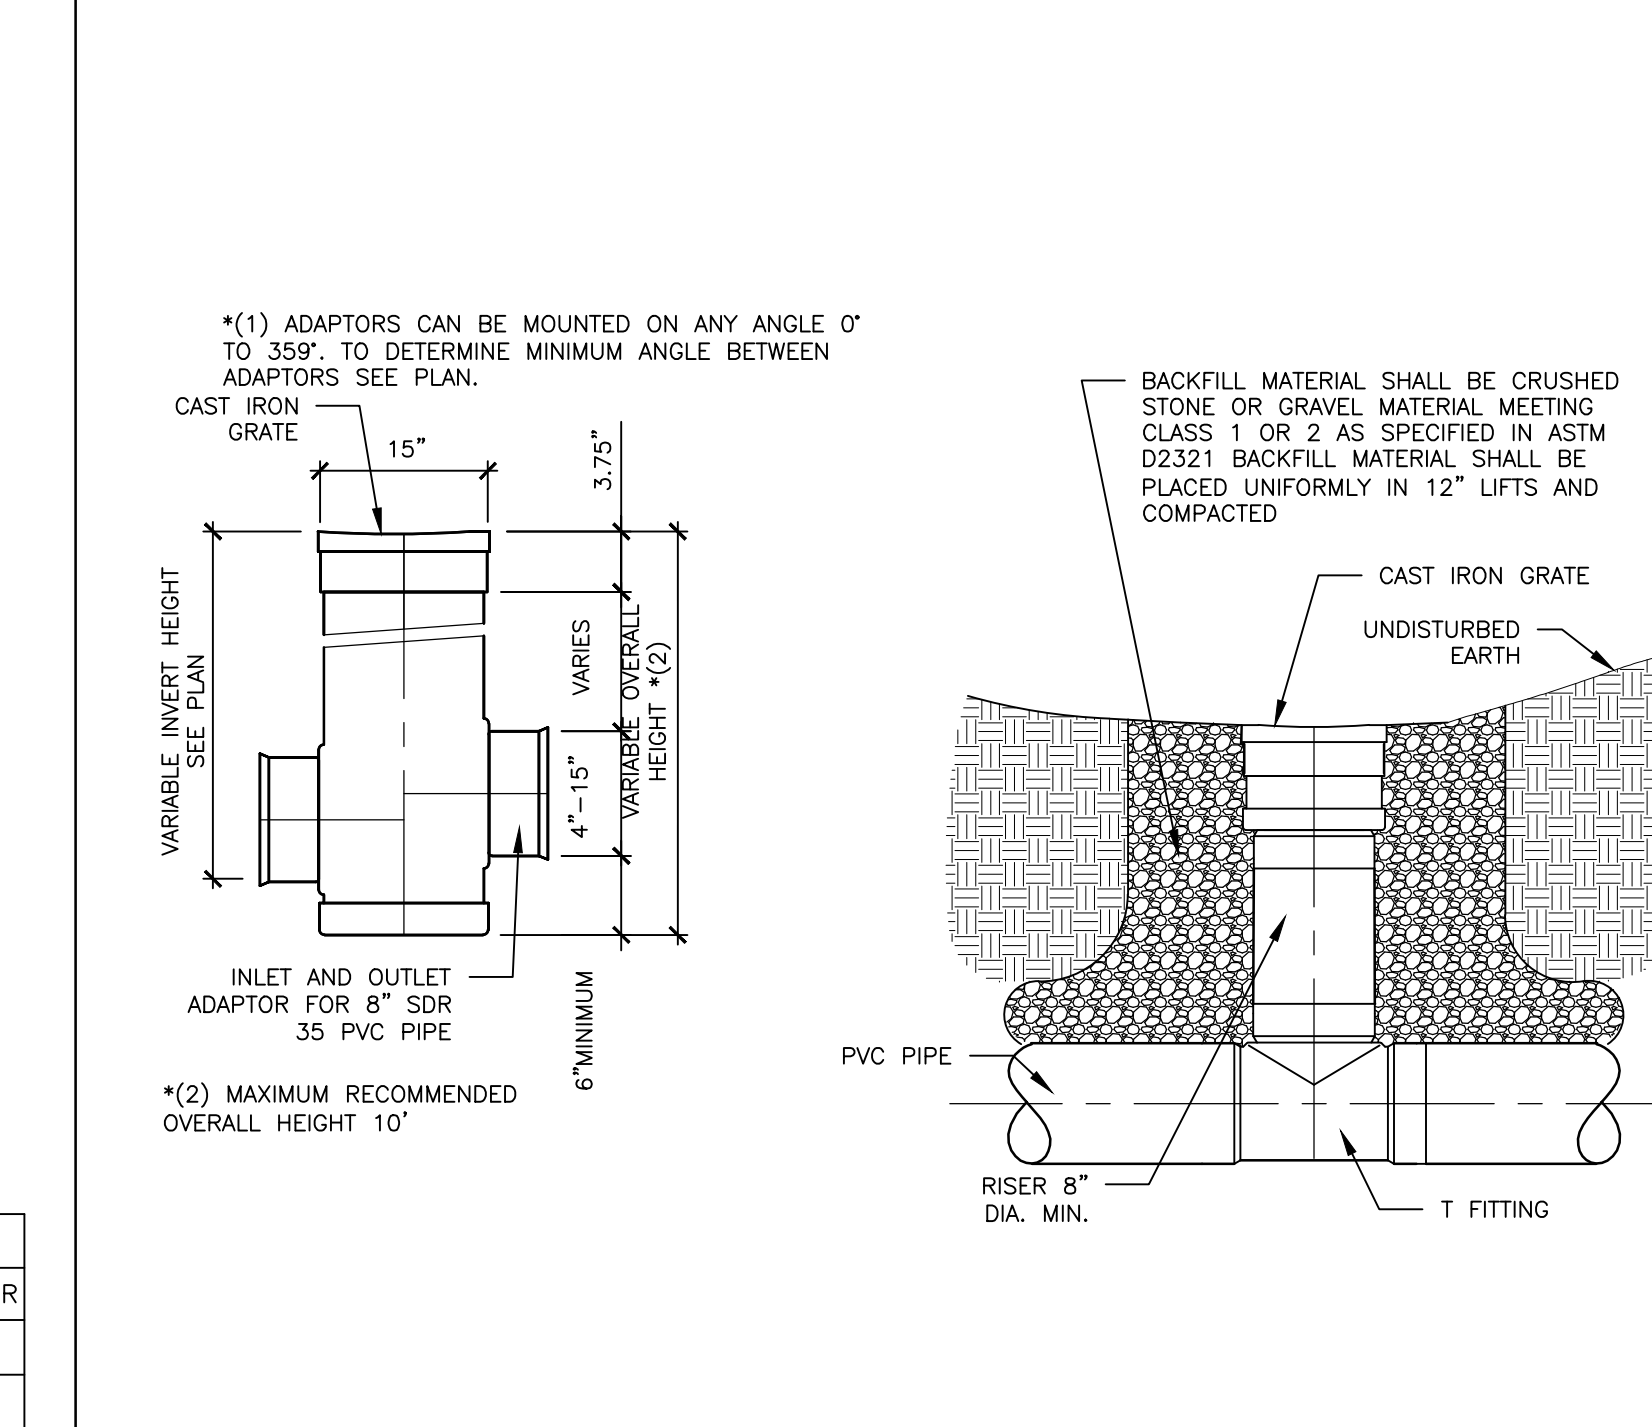

7 15' AREA DRAIN

N.T.S.

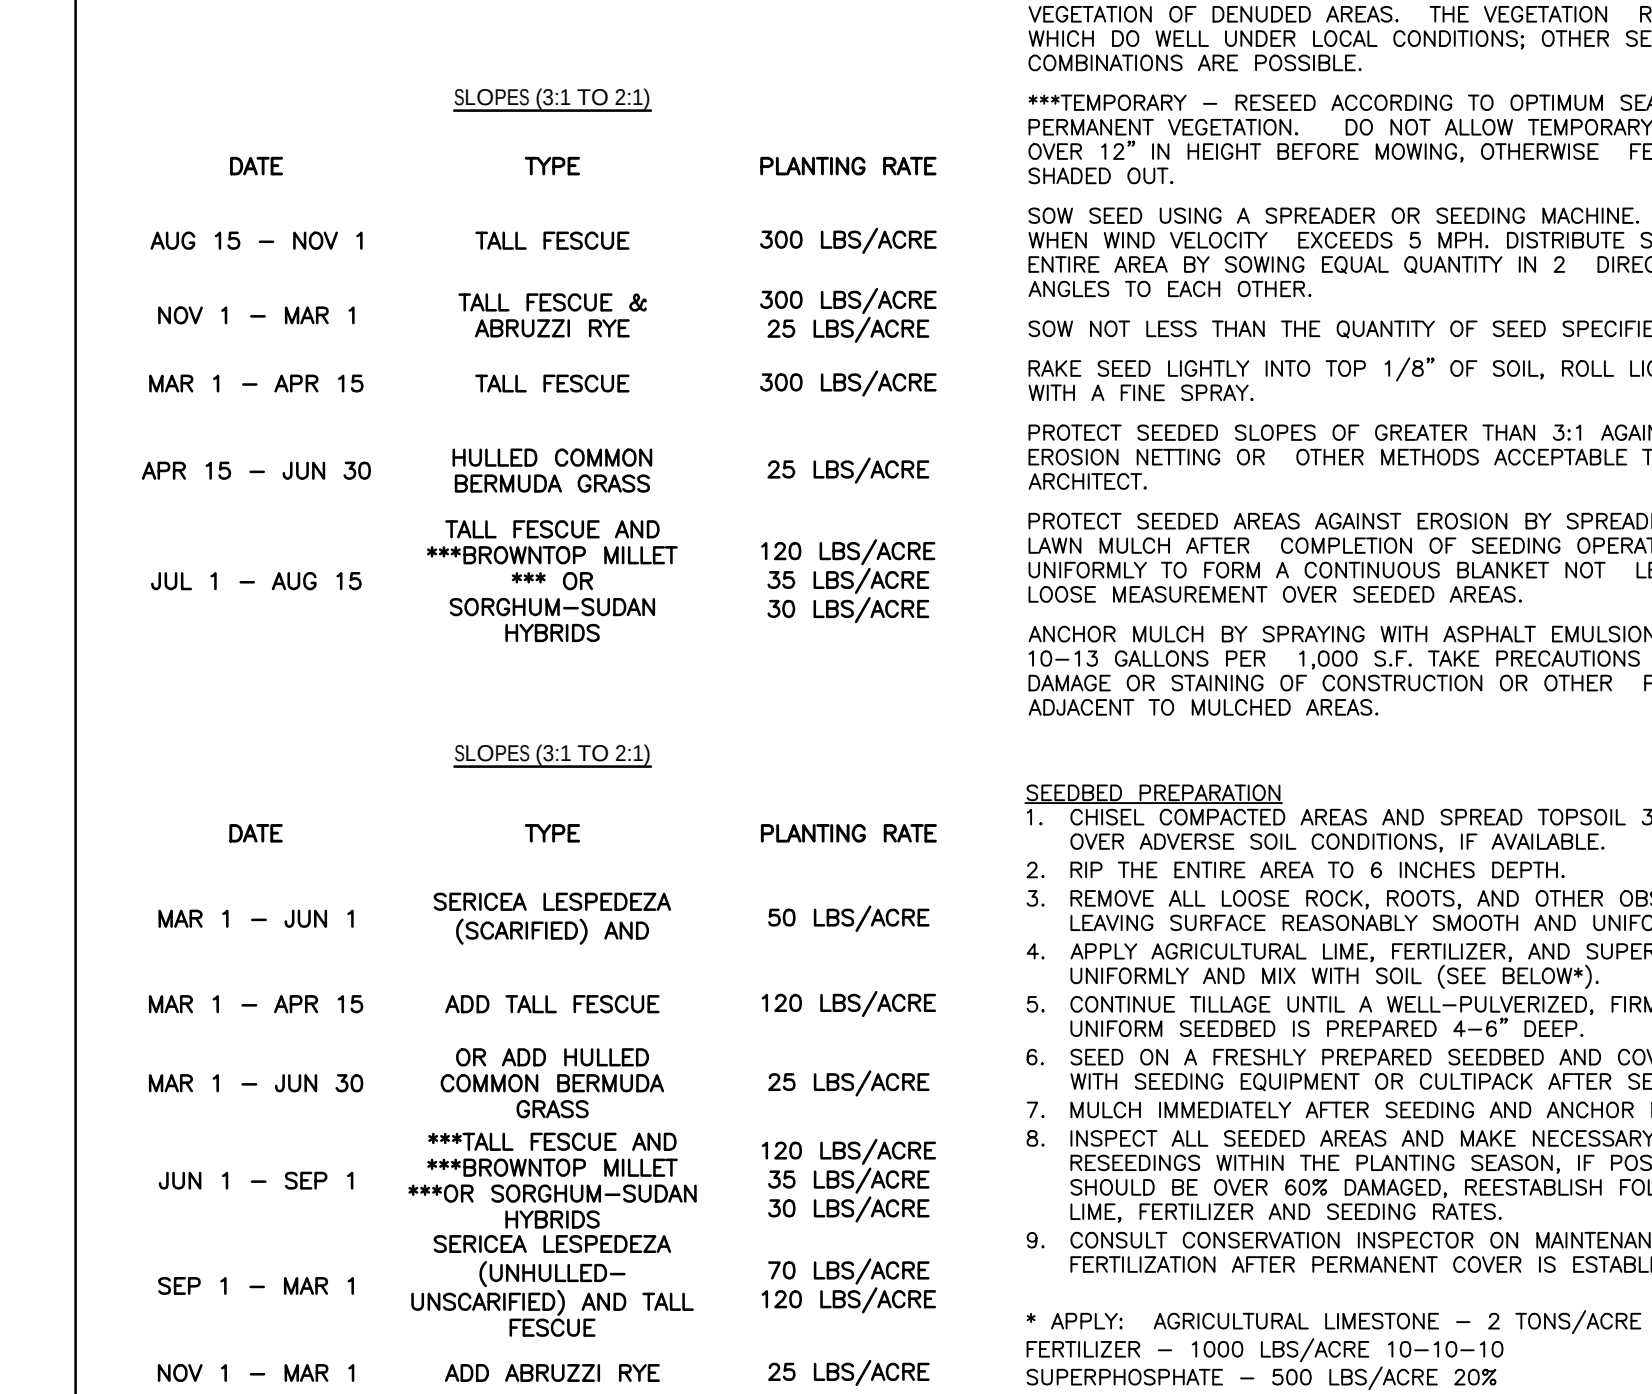


10 PERMANENT SEEDING SPECIFICATIONS

N.T.S.


4 FLARED END SECTION

N.T.S.

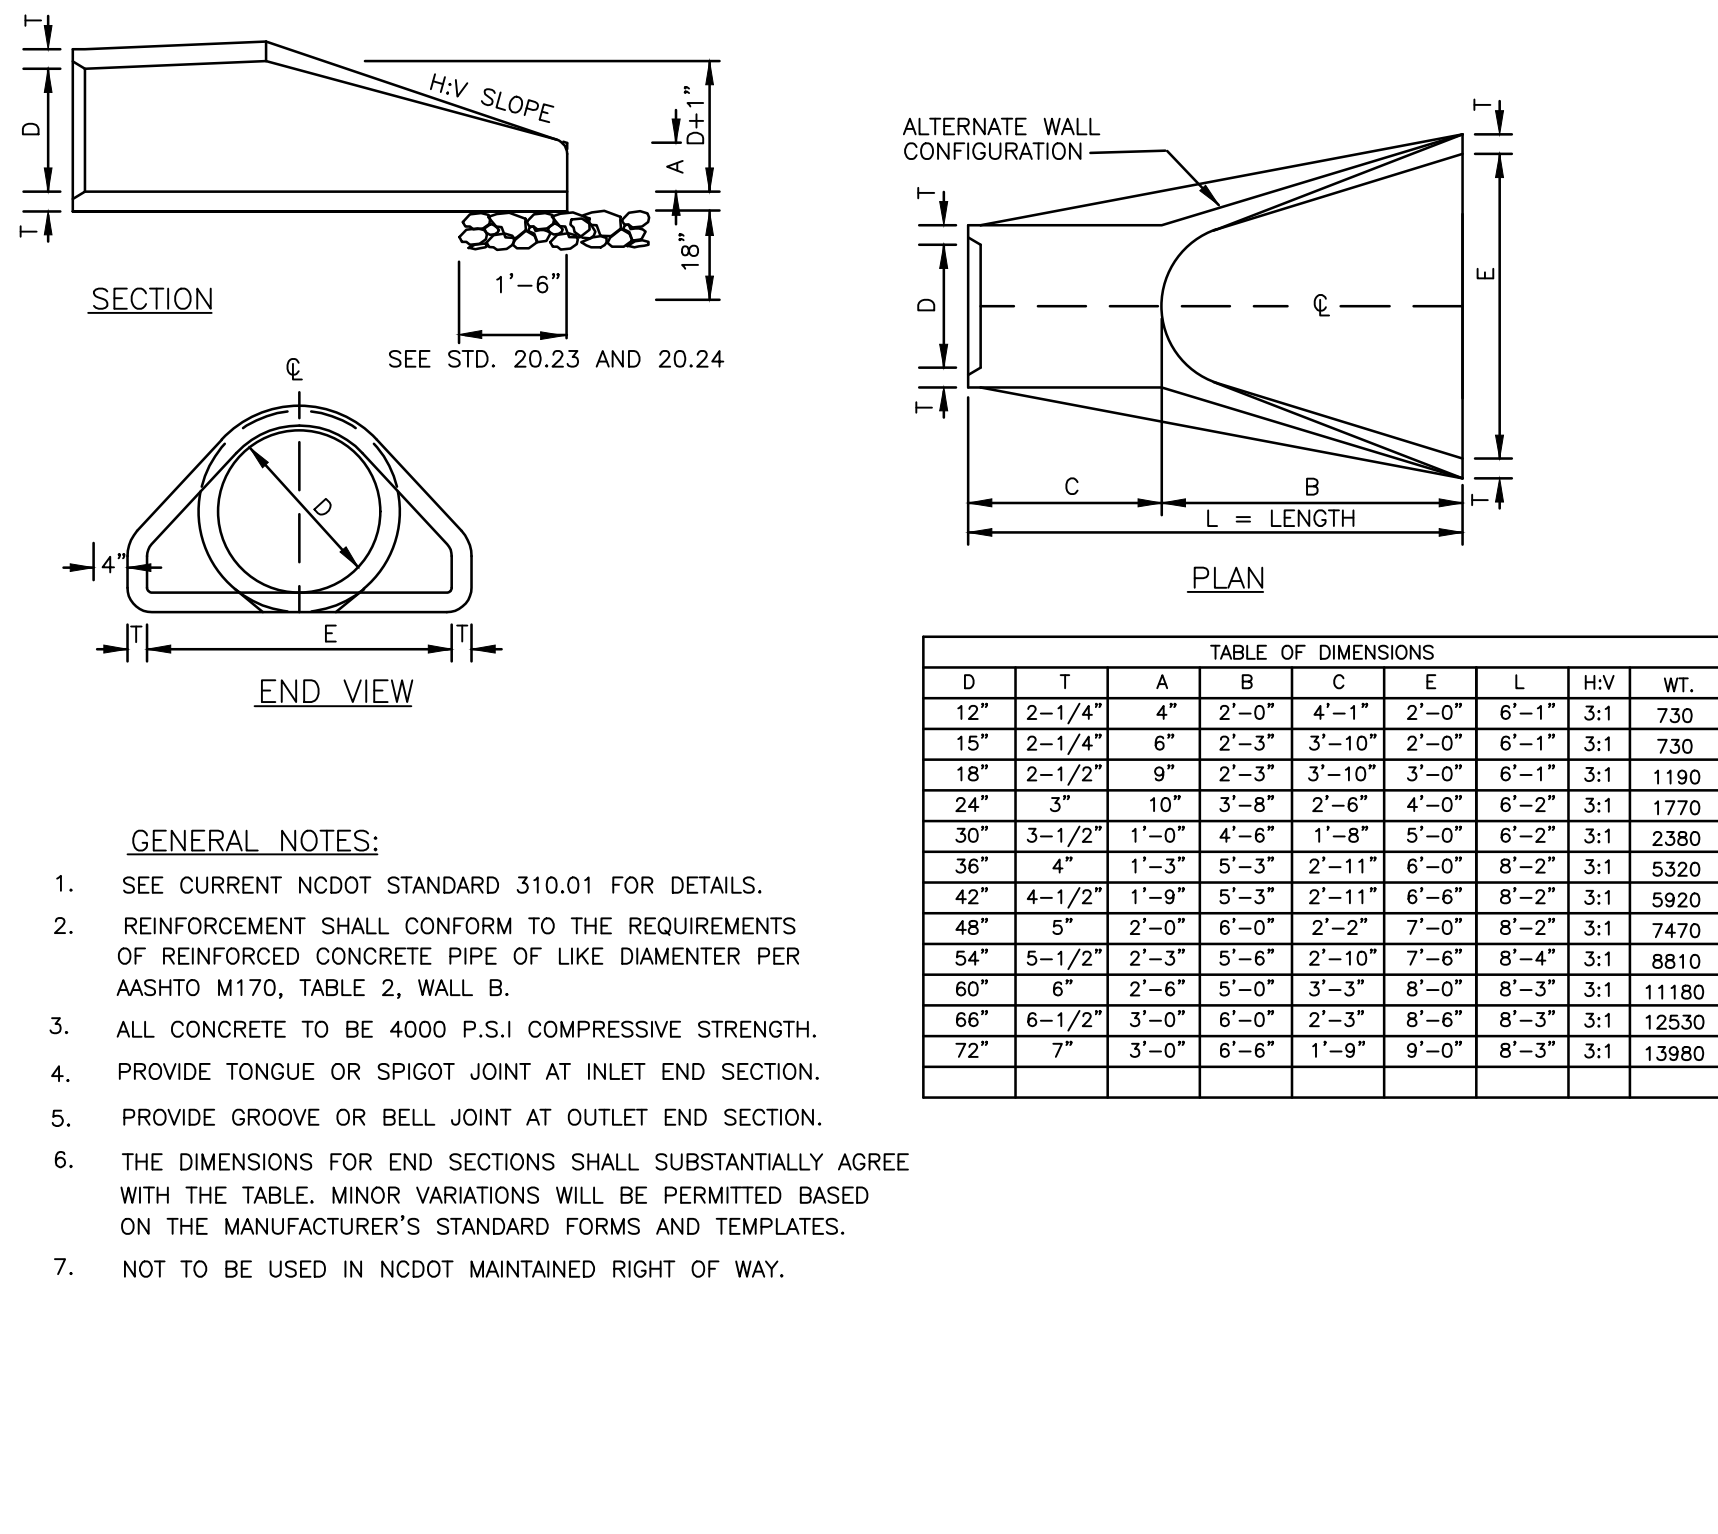


4 FLARED END SECTION

N.T.S.

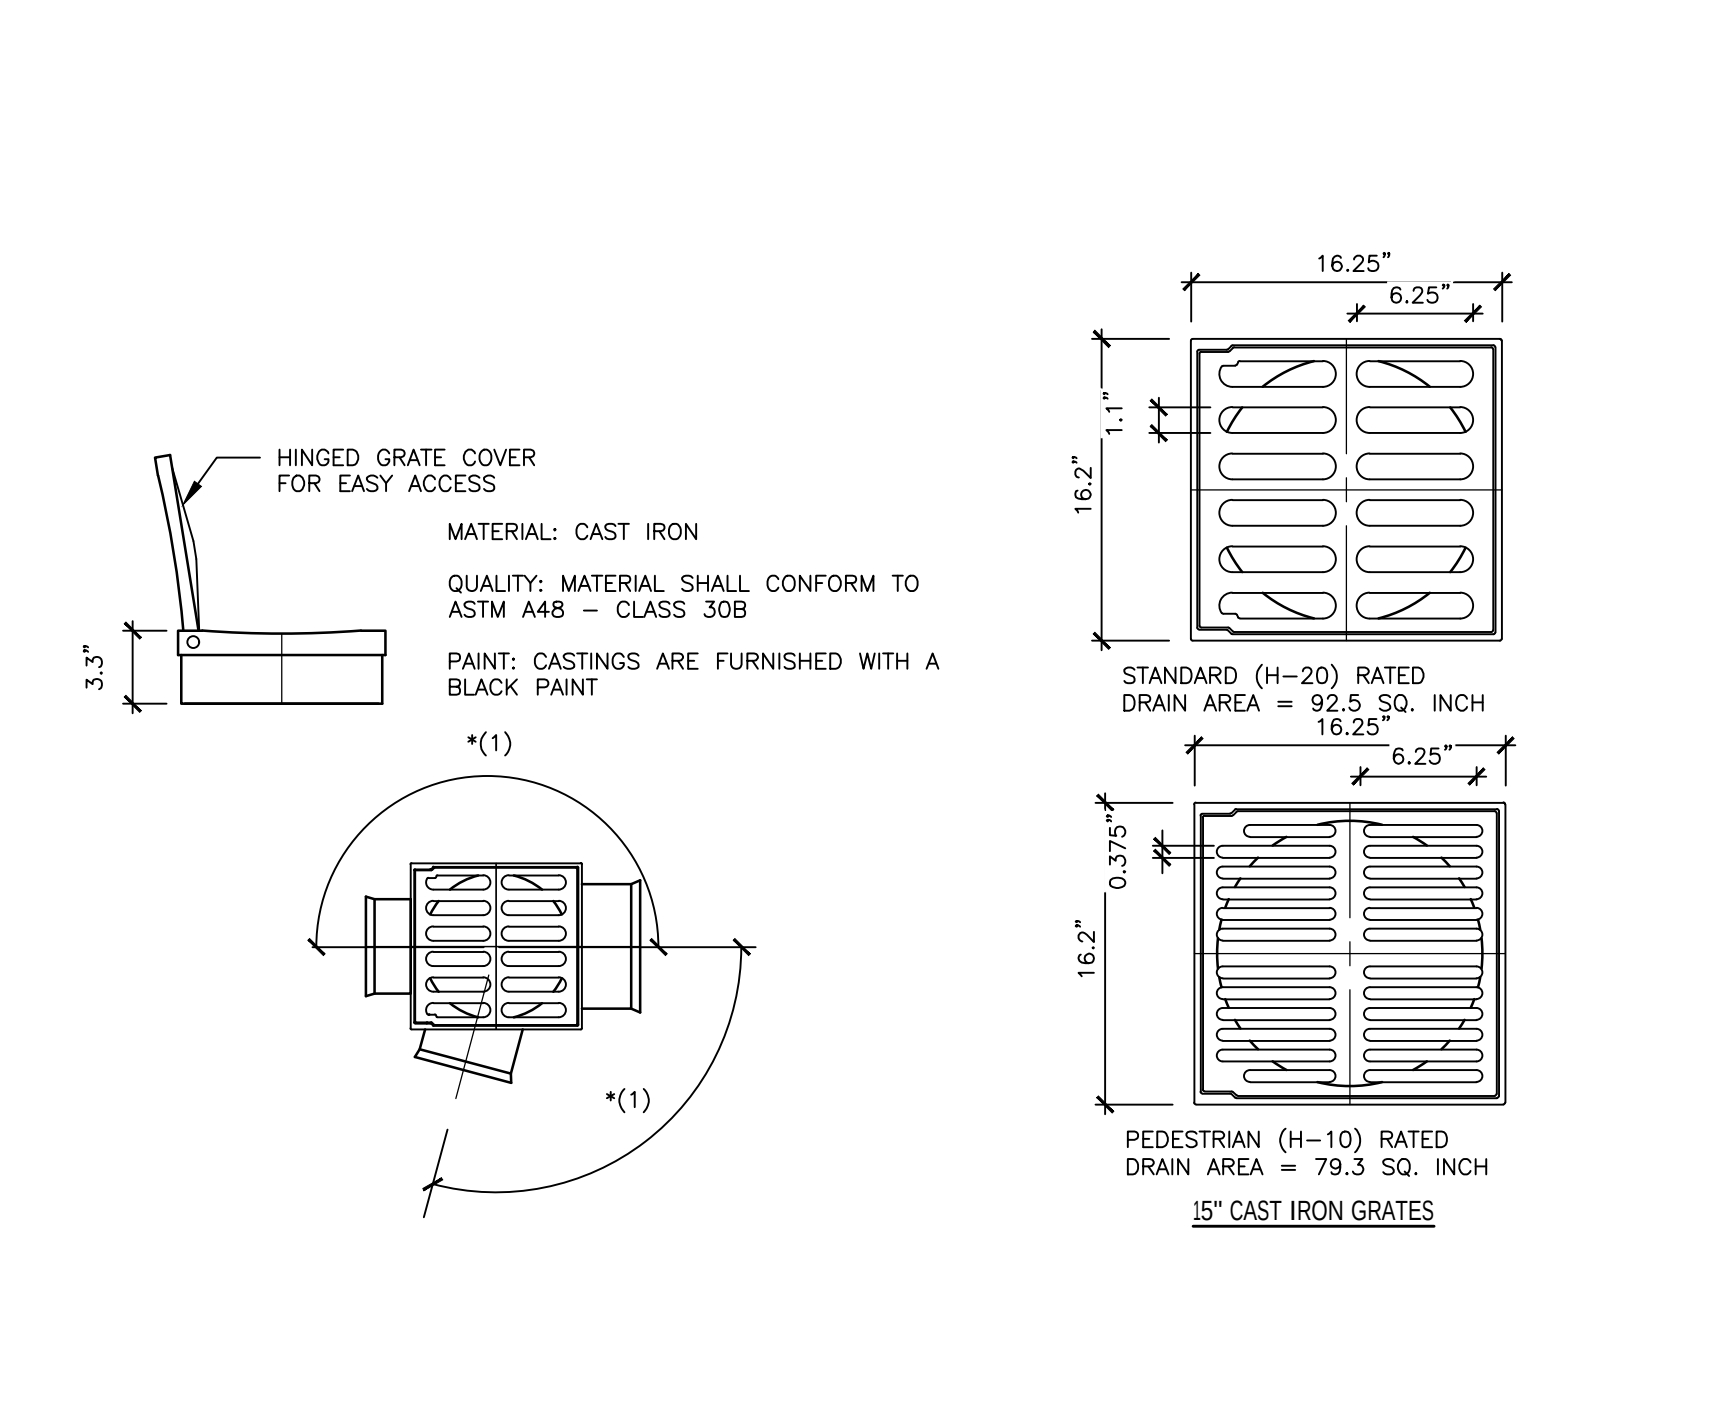


4 FLARED END SECTION

N.T.S.

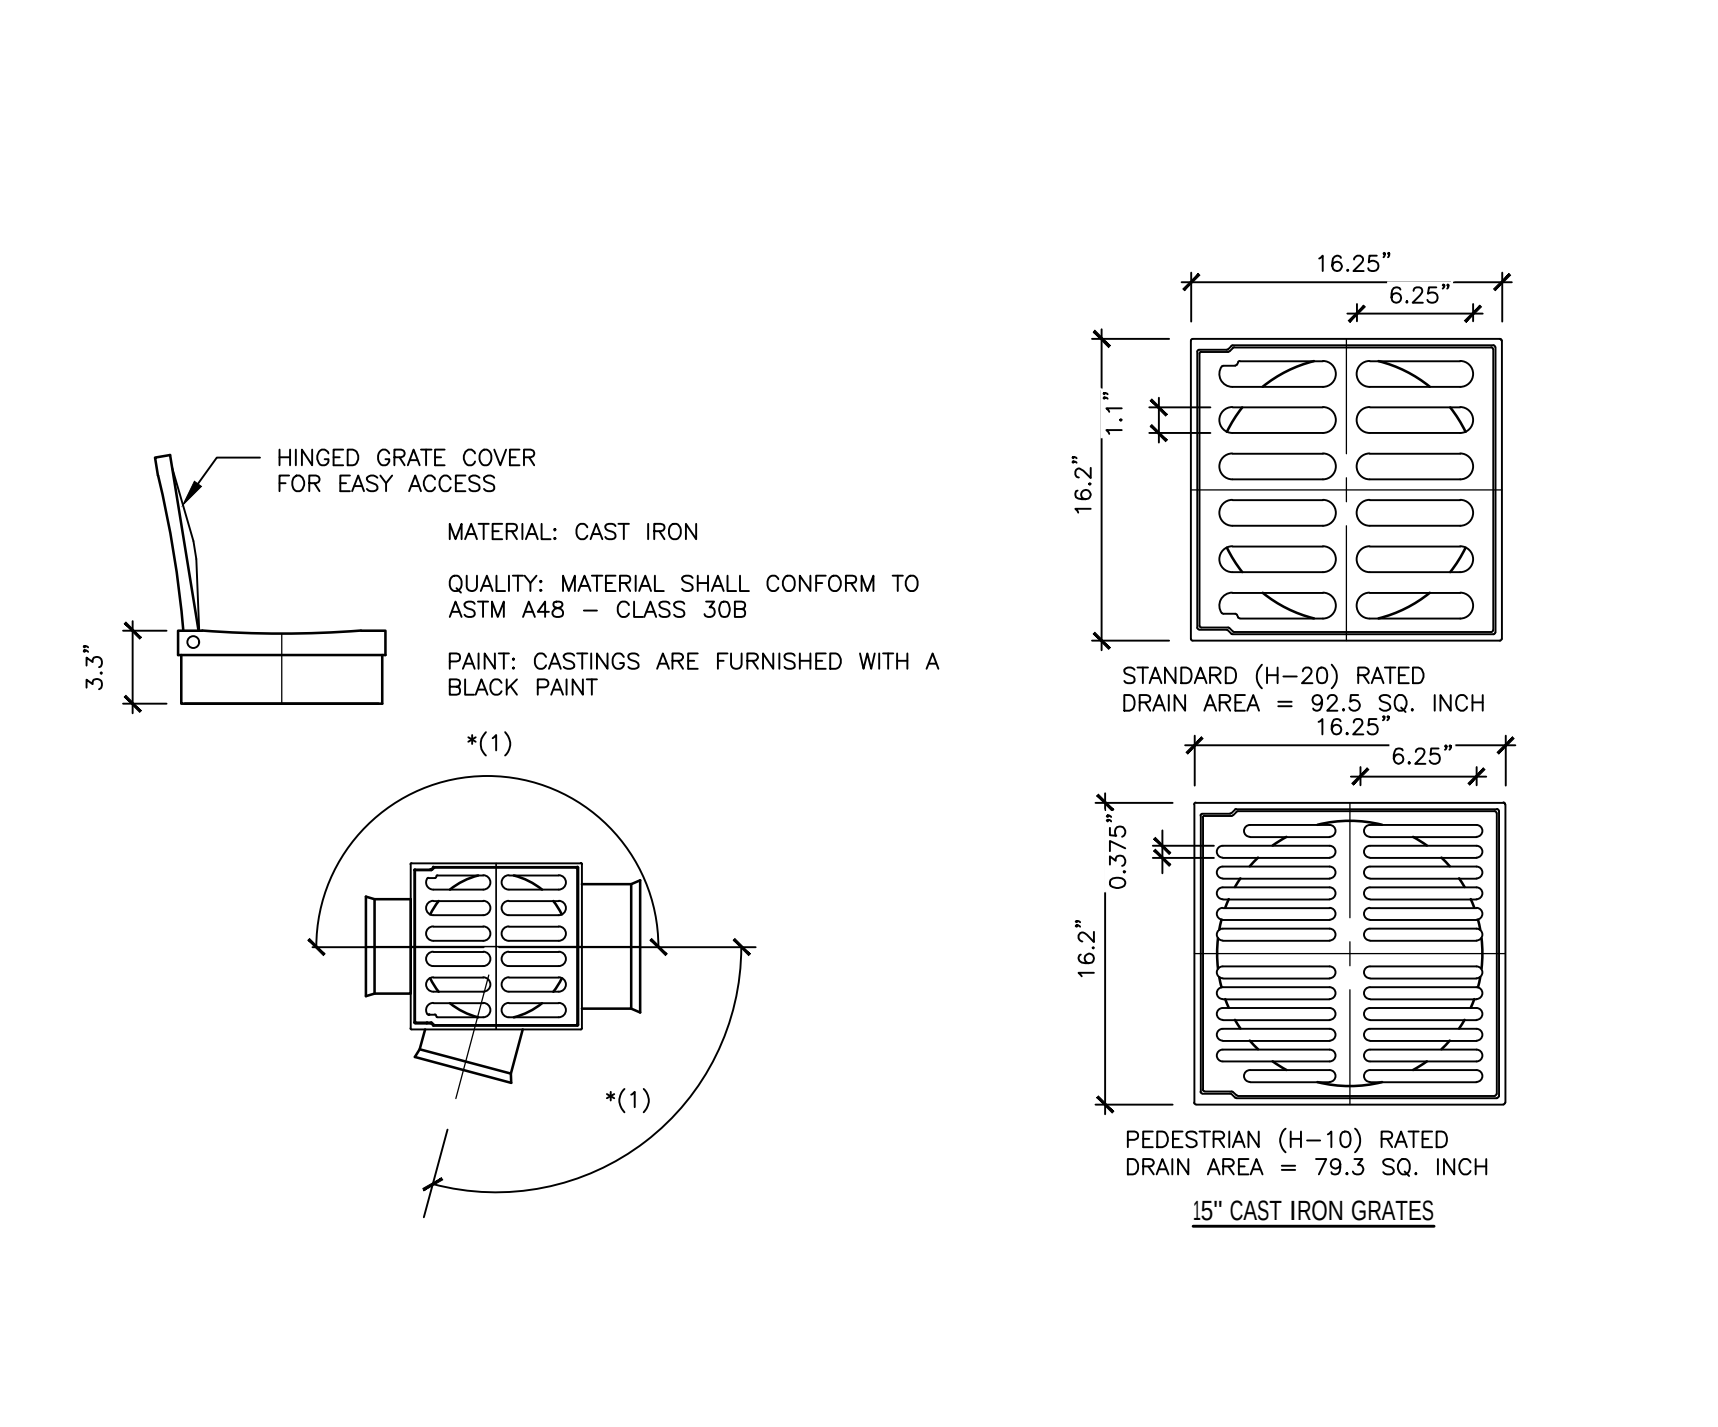


4 FLARED END SECTION

N.T.S.

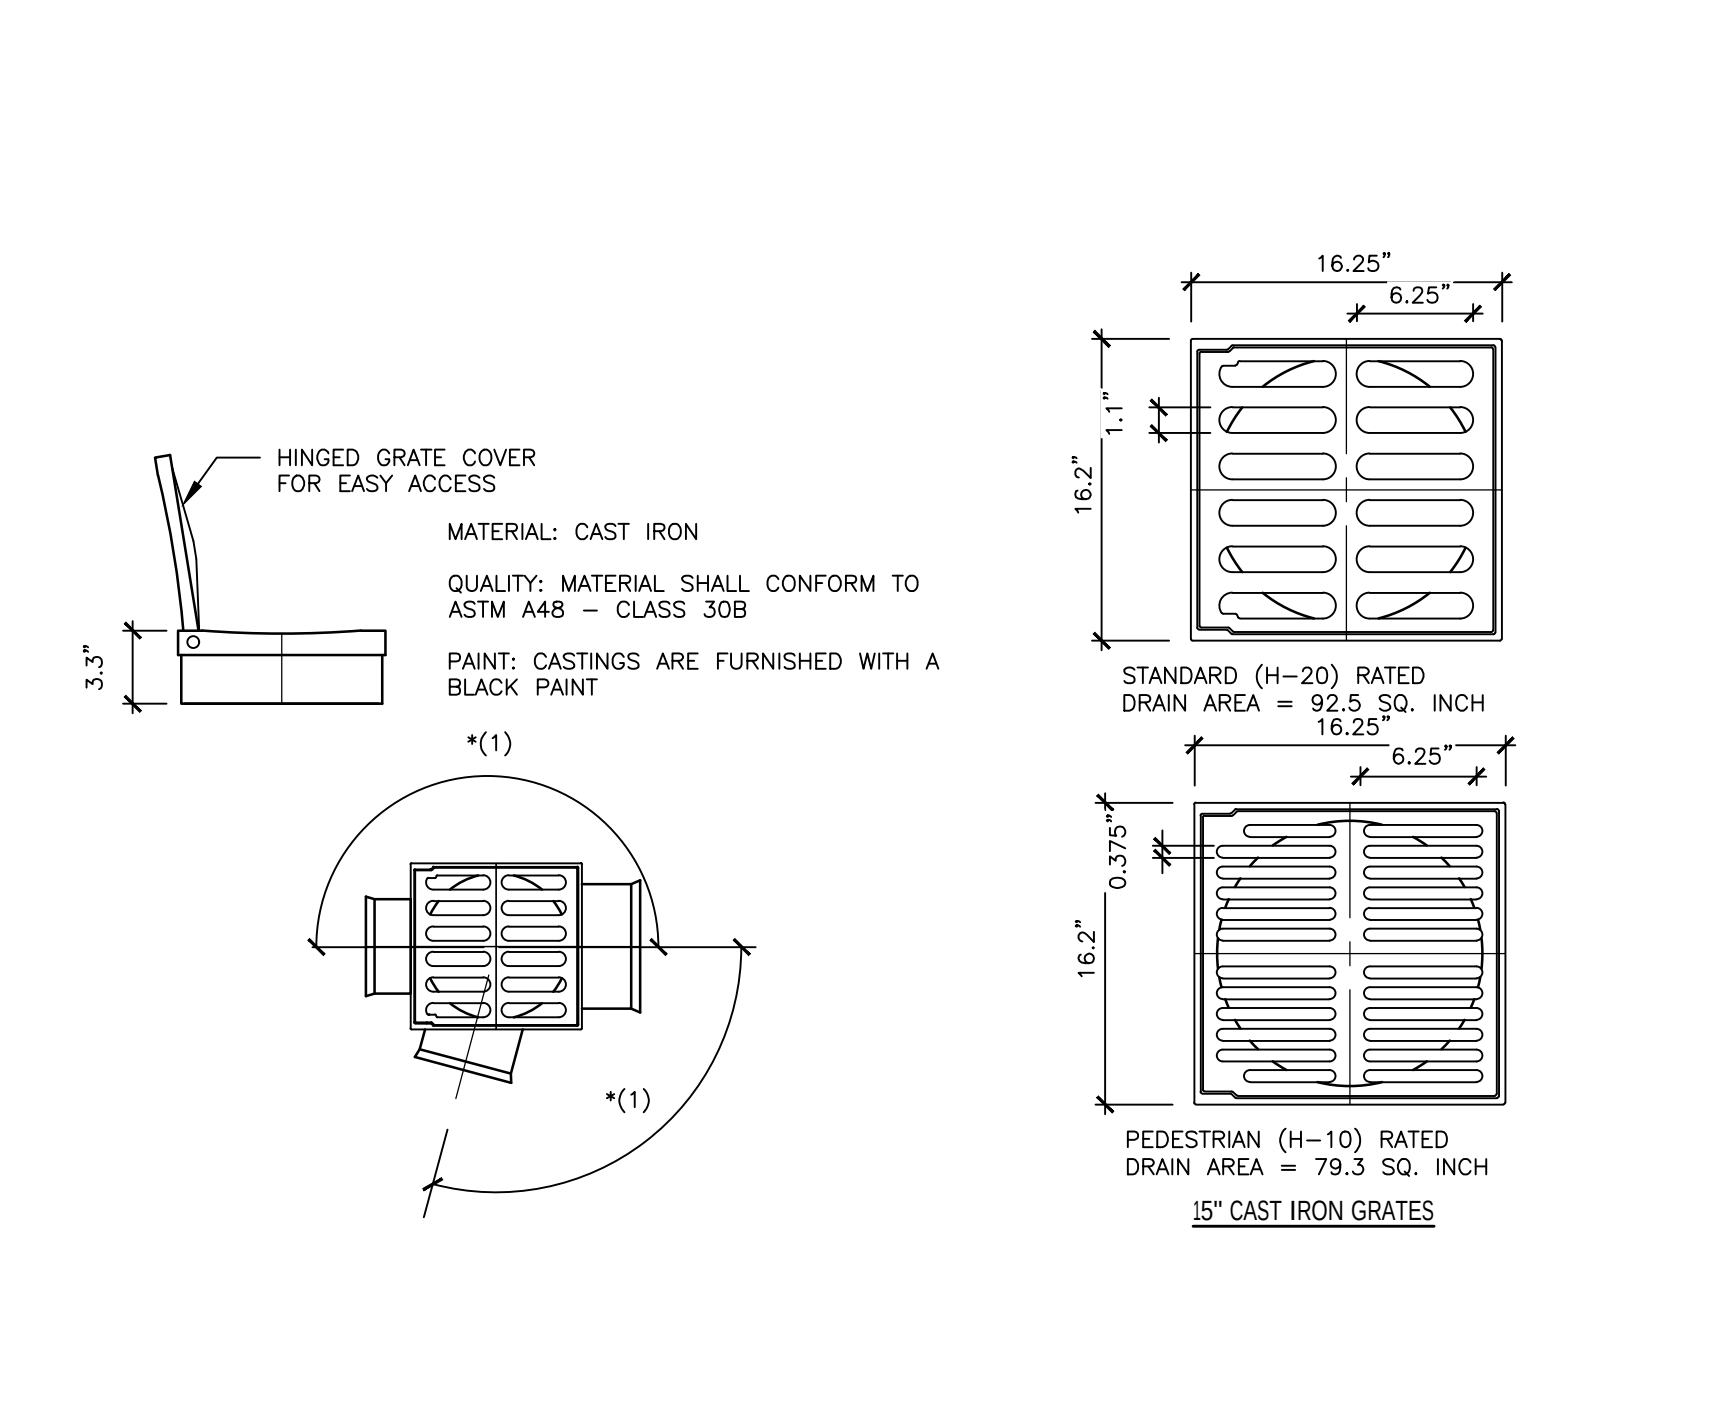


4 FLARED END SECTION

N.T.S.

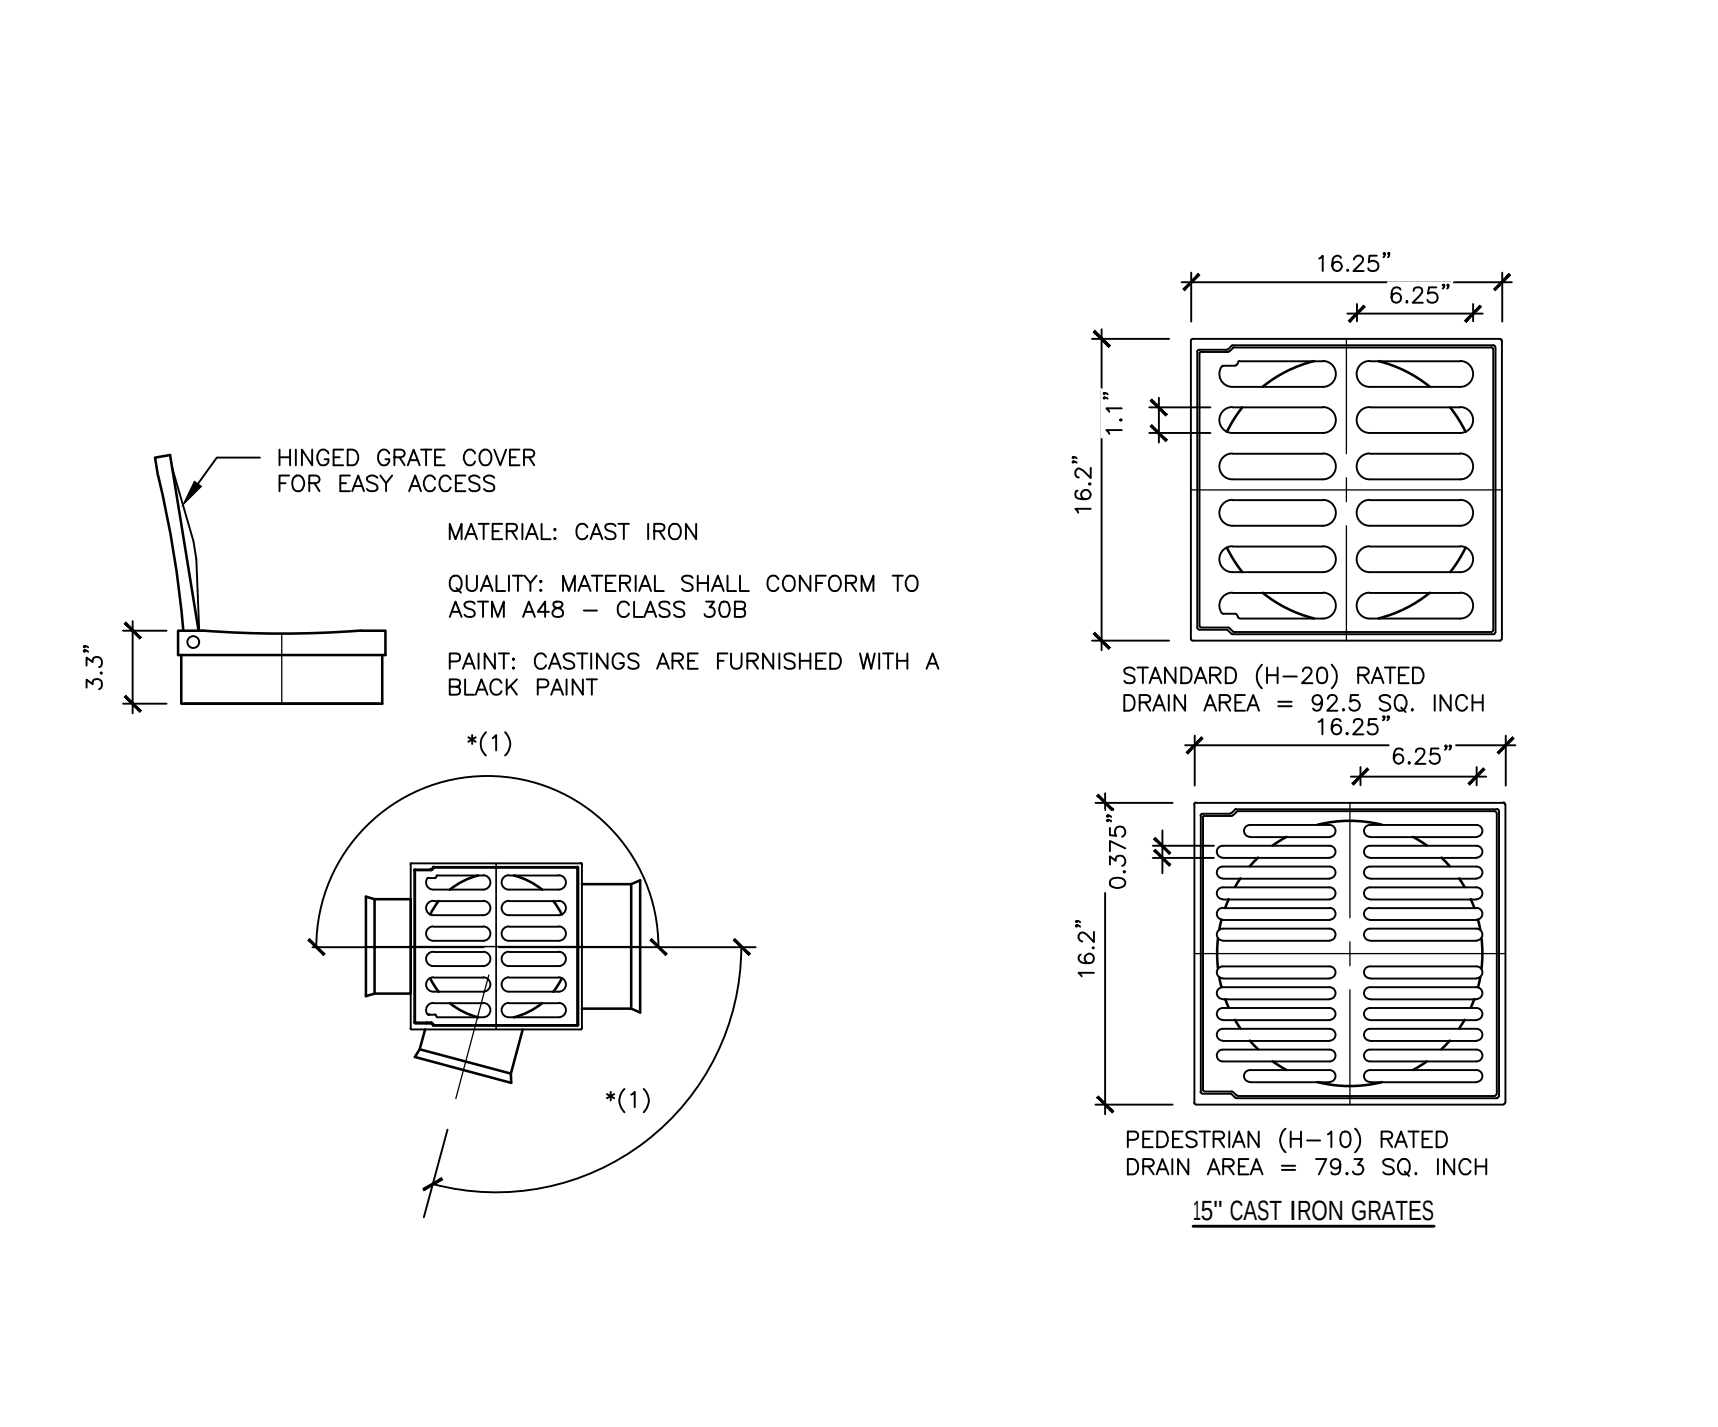


4 FLARED END SECTION

N.T.S.

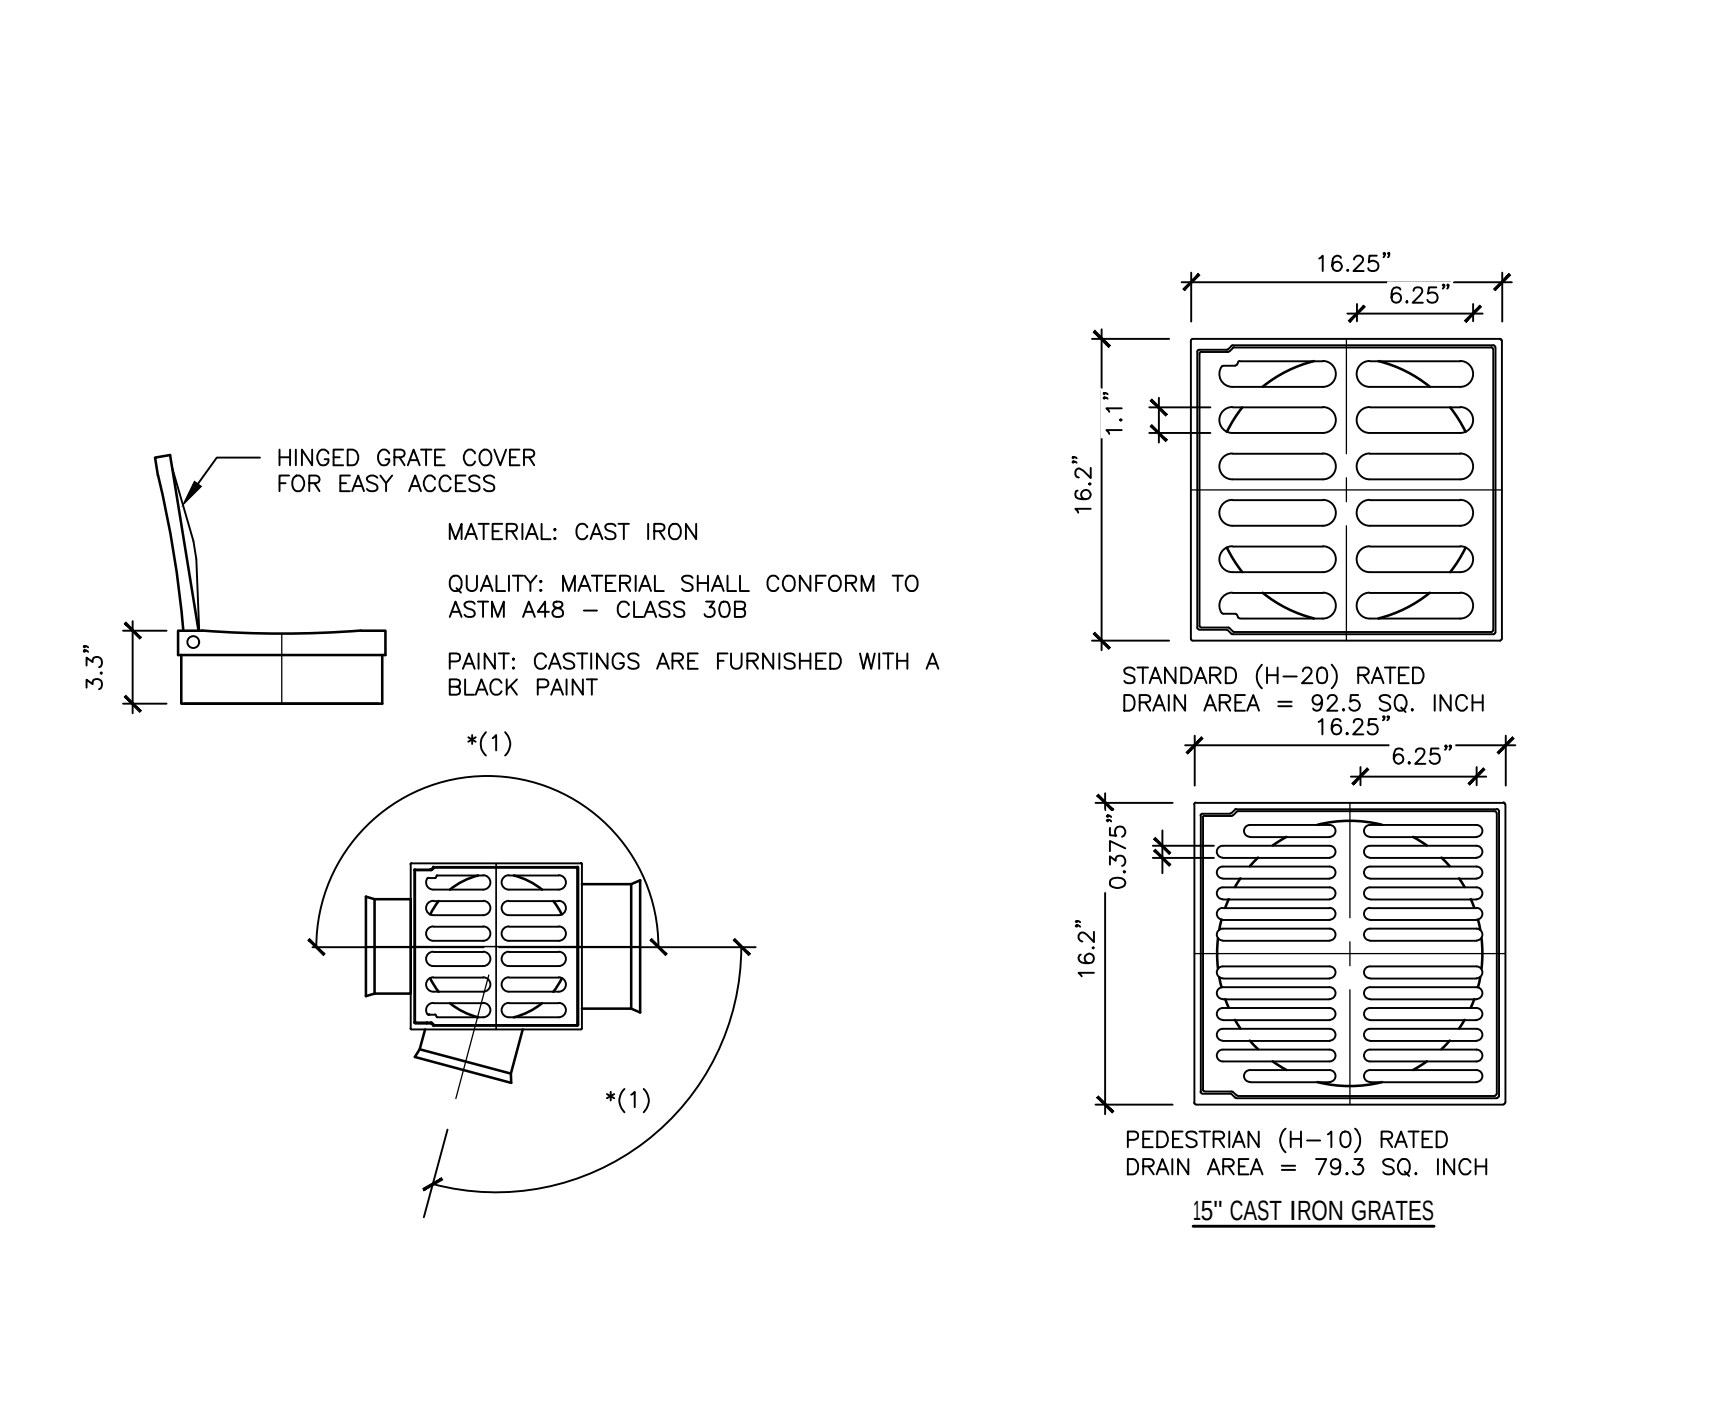


4 FLARED END SECTION

N.T.S.

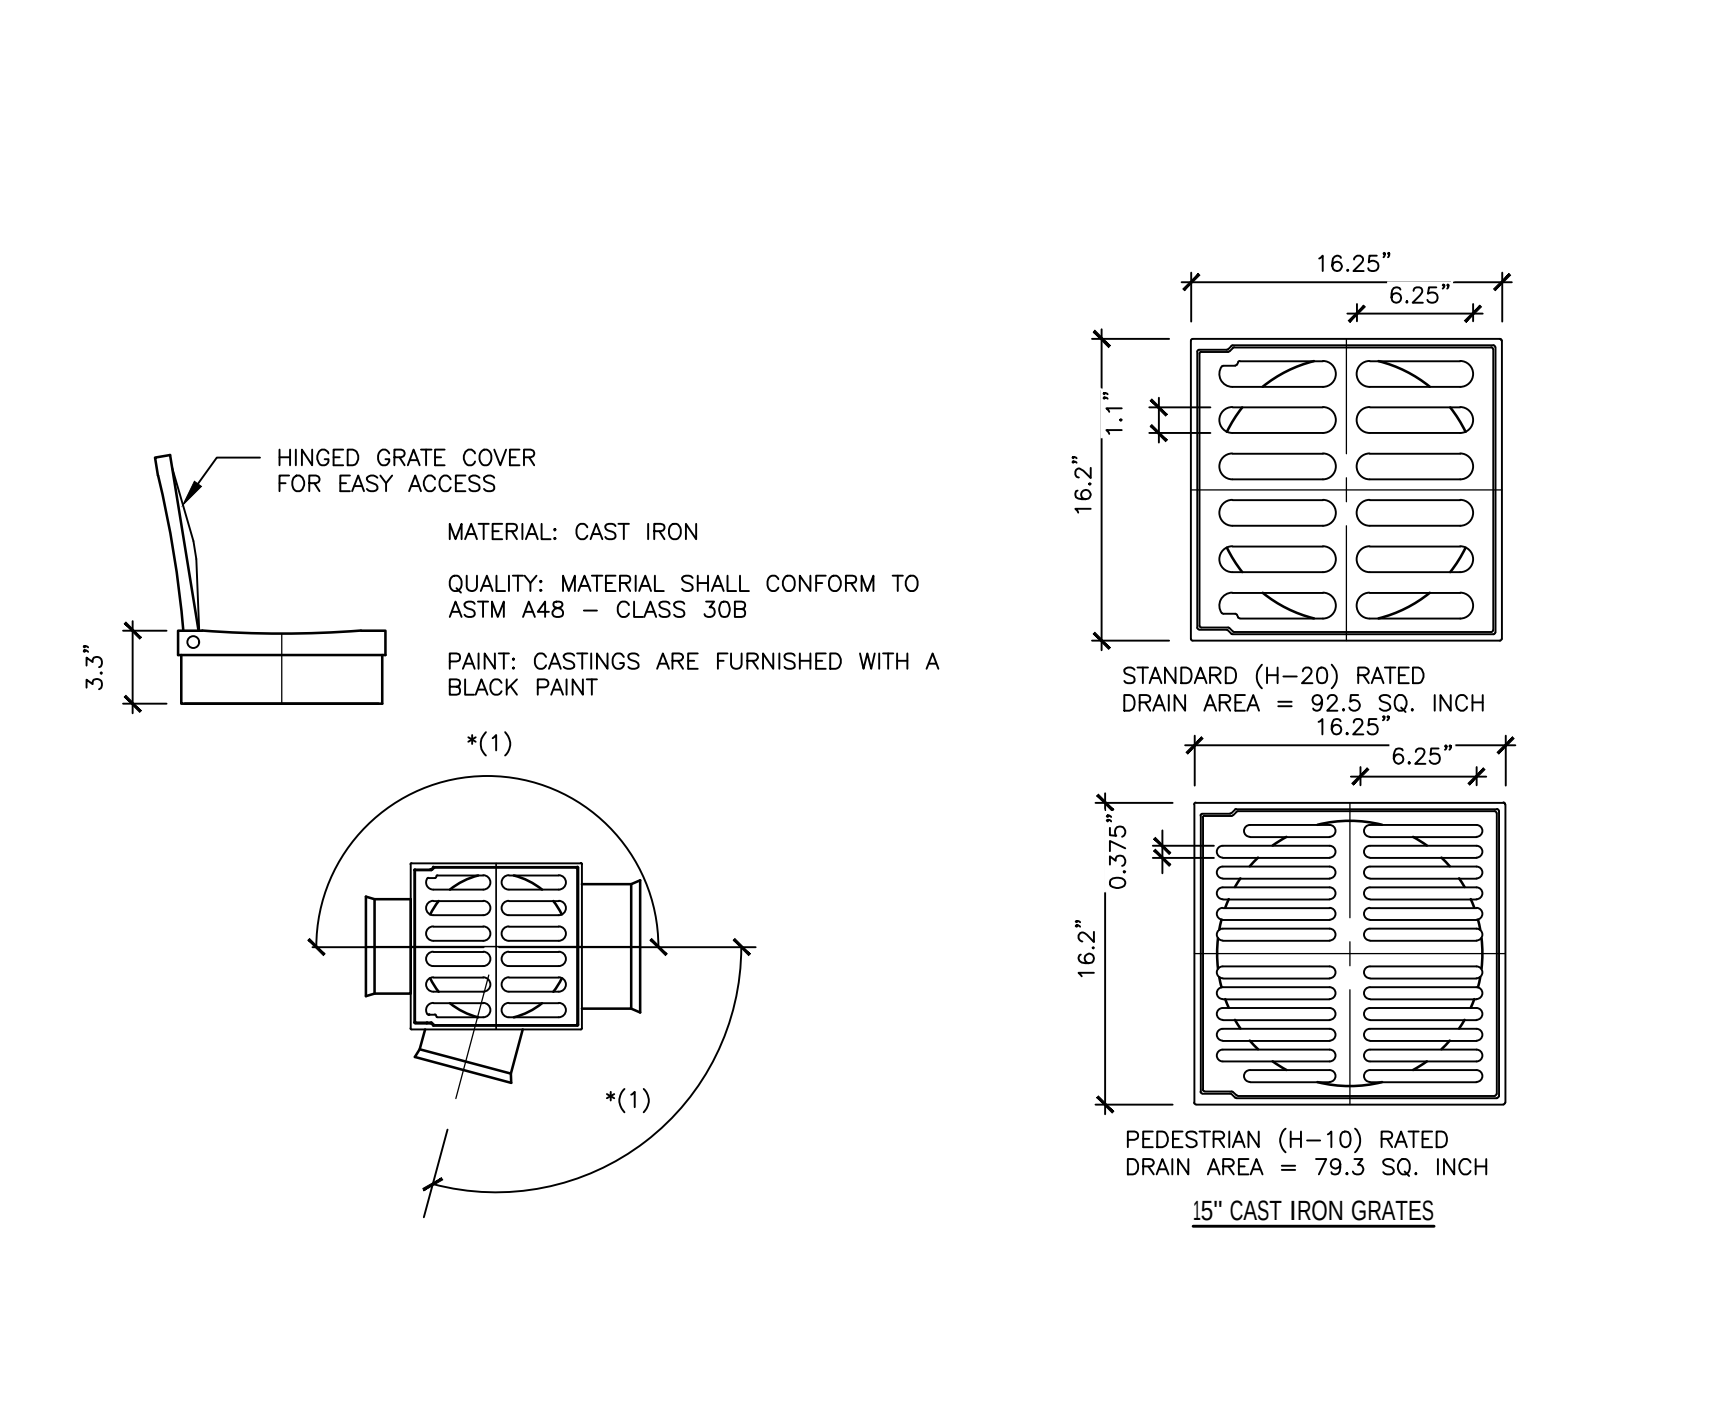


4 FLARED END SECTION

N.T.S.

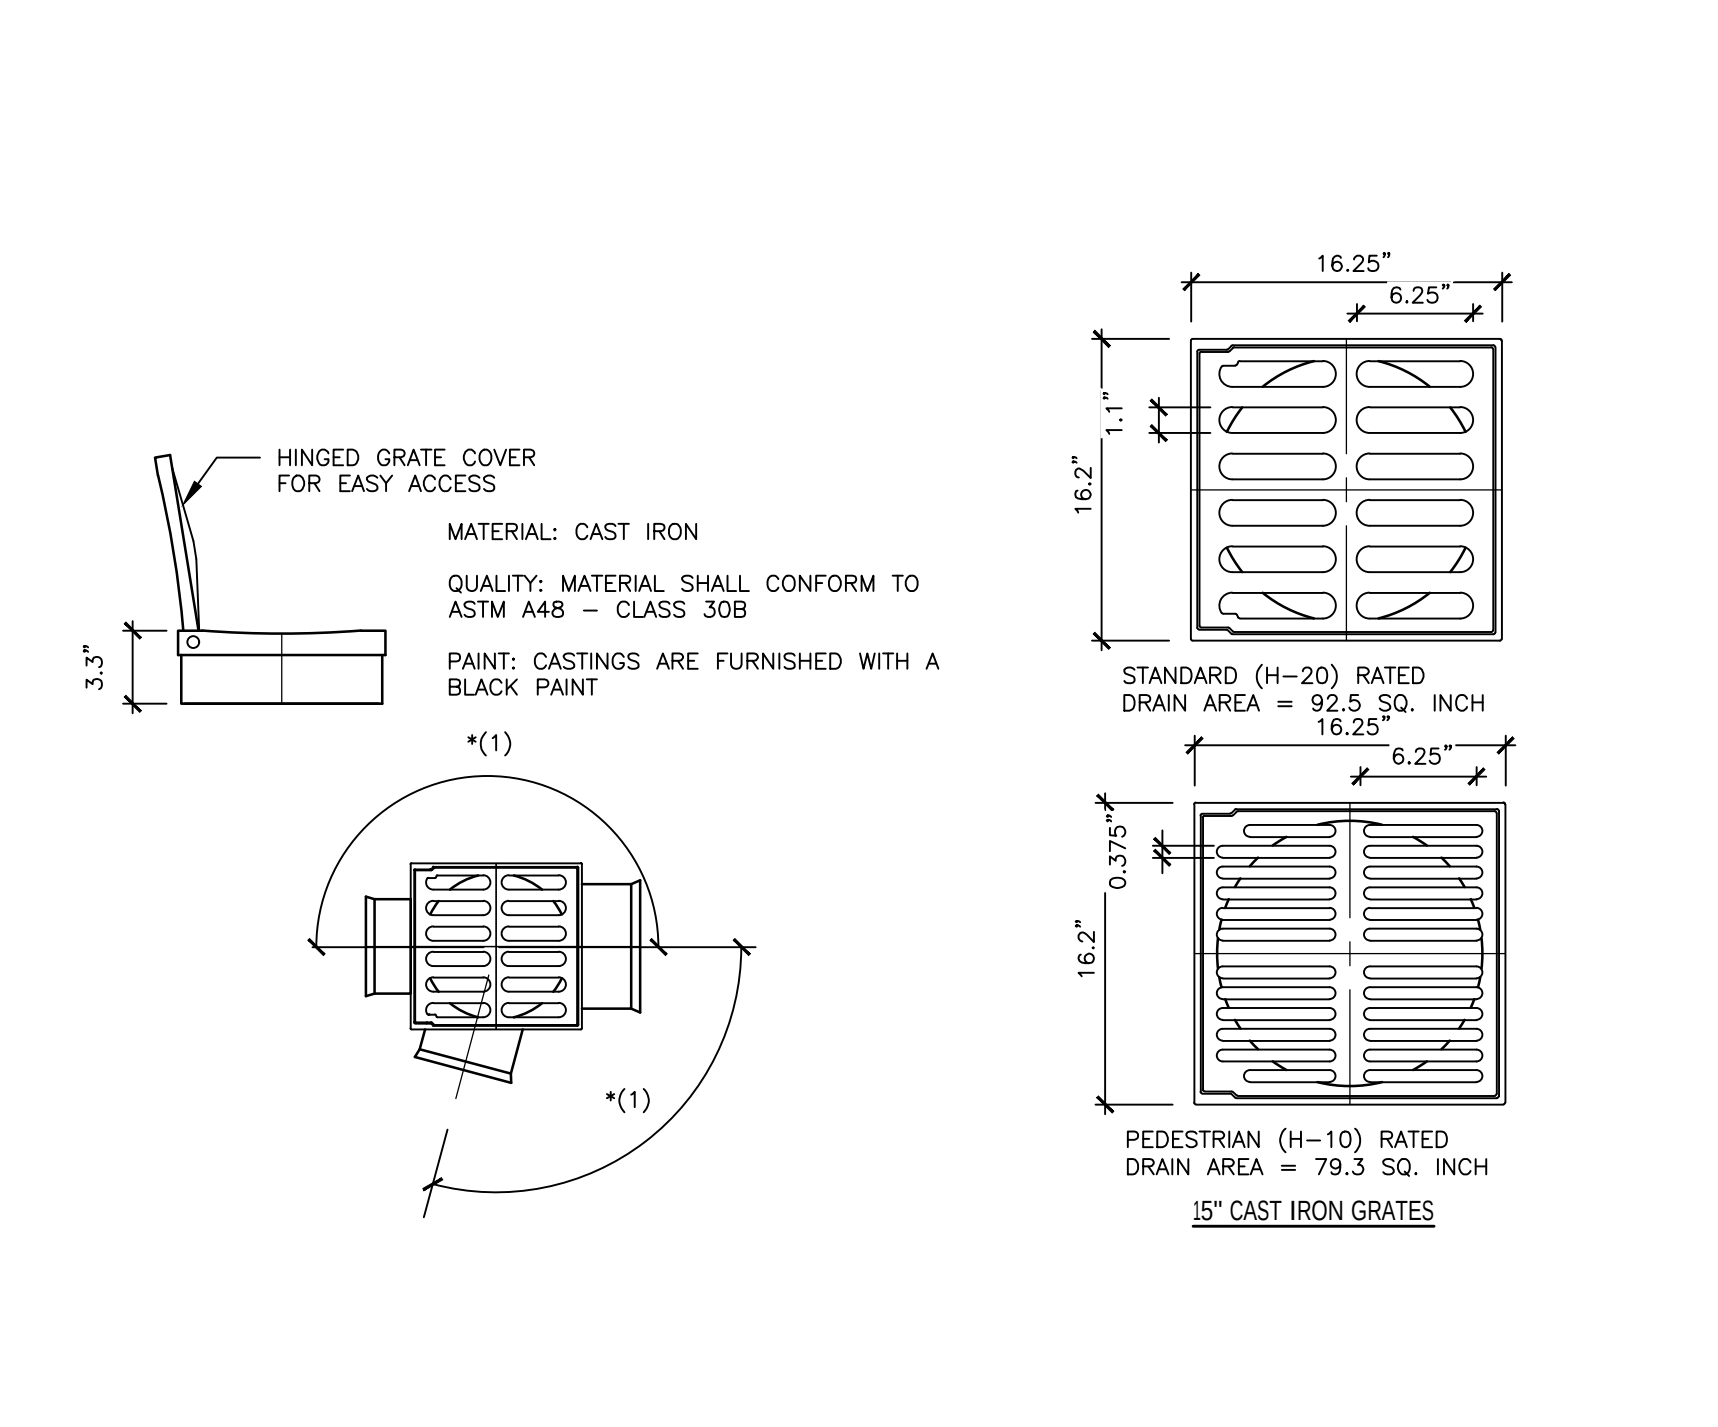


4 FLARED END SECTION

N.T.S.

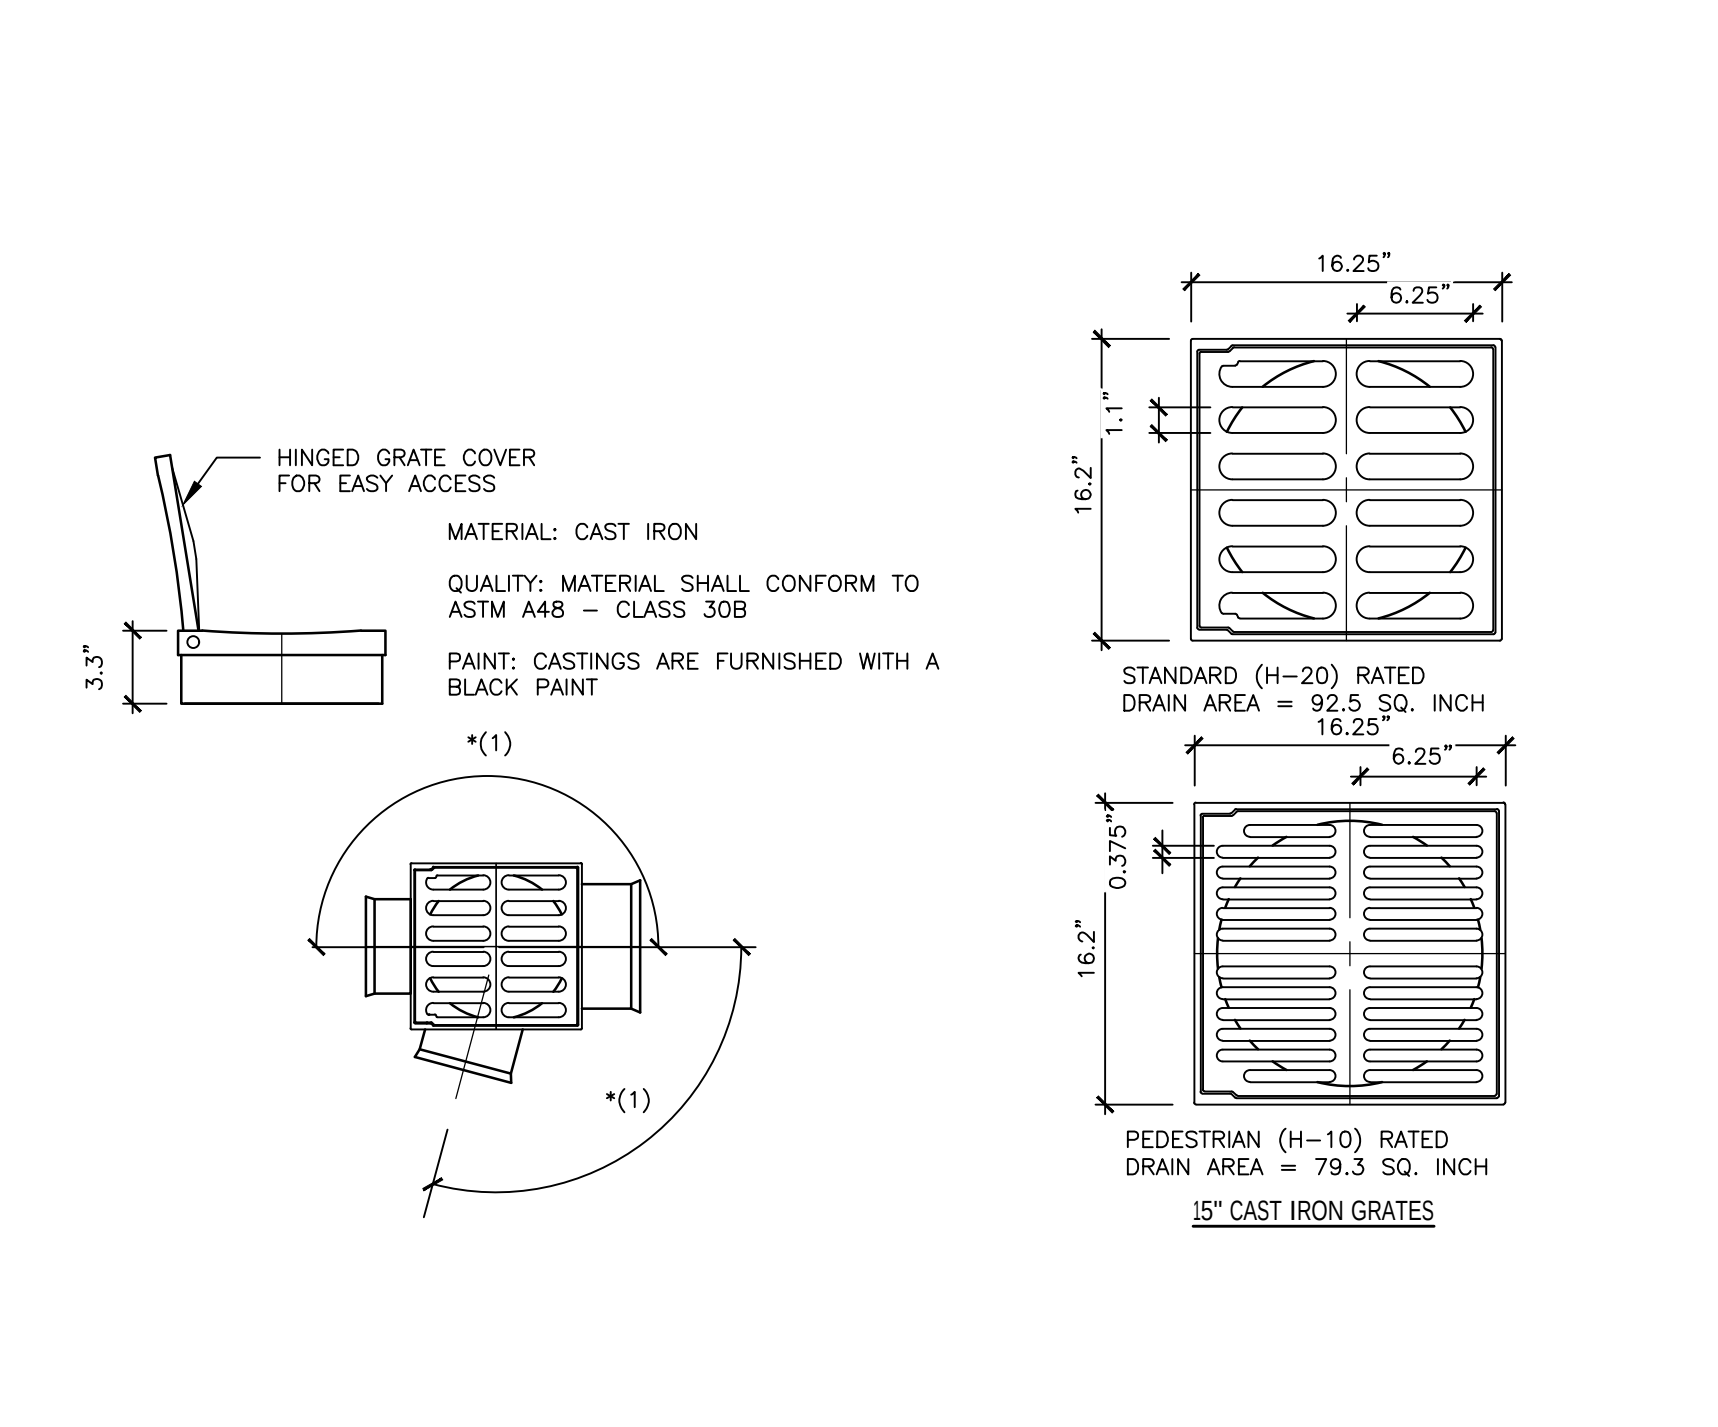


4 FLARED END SECTION

N.T.S.

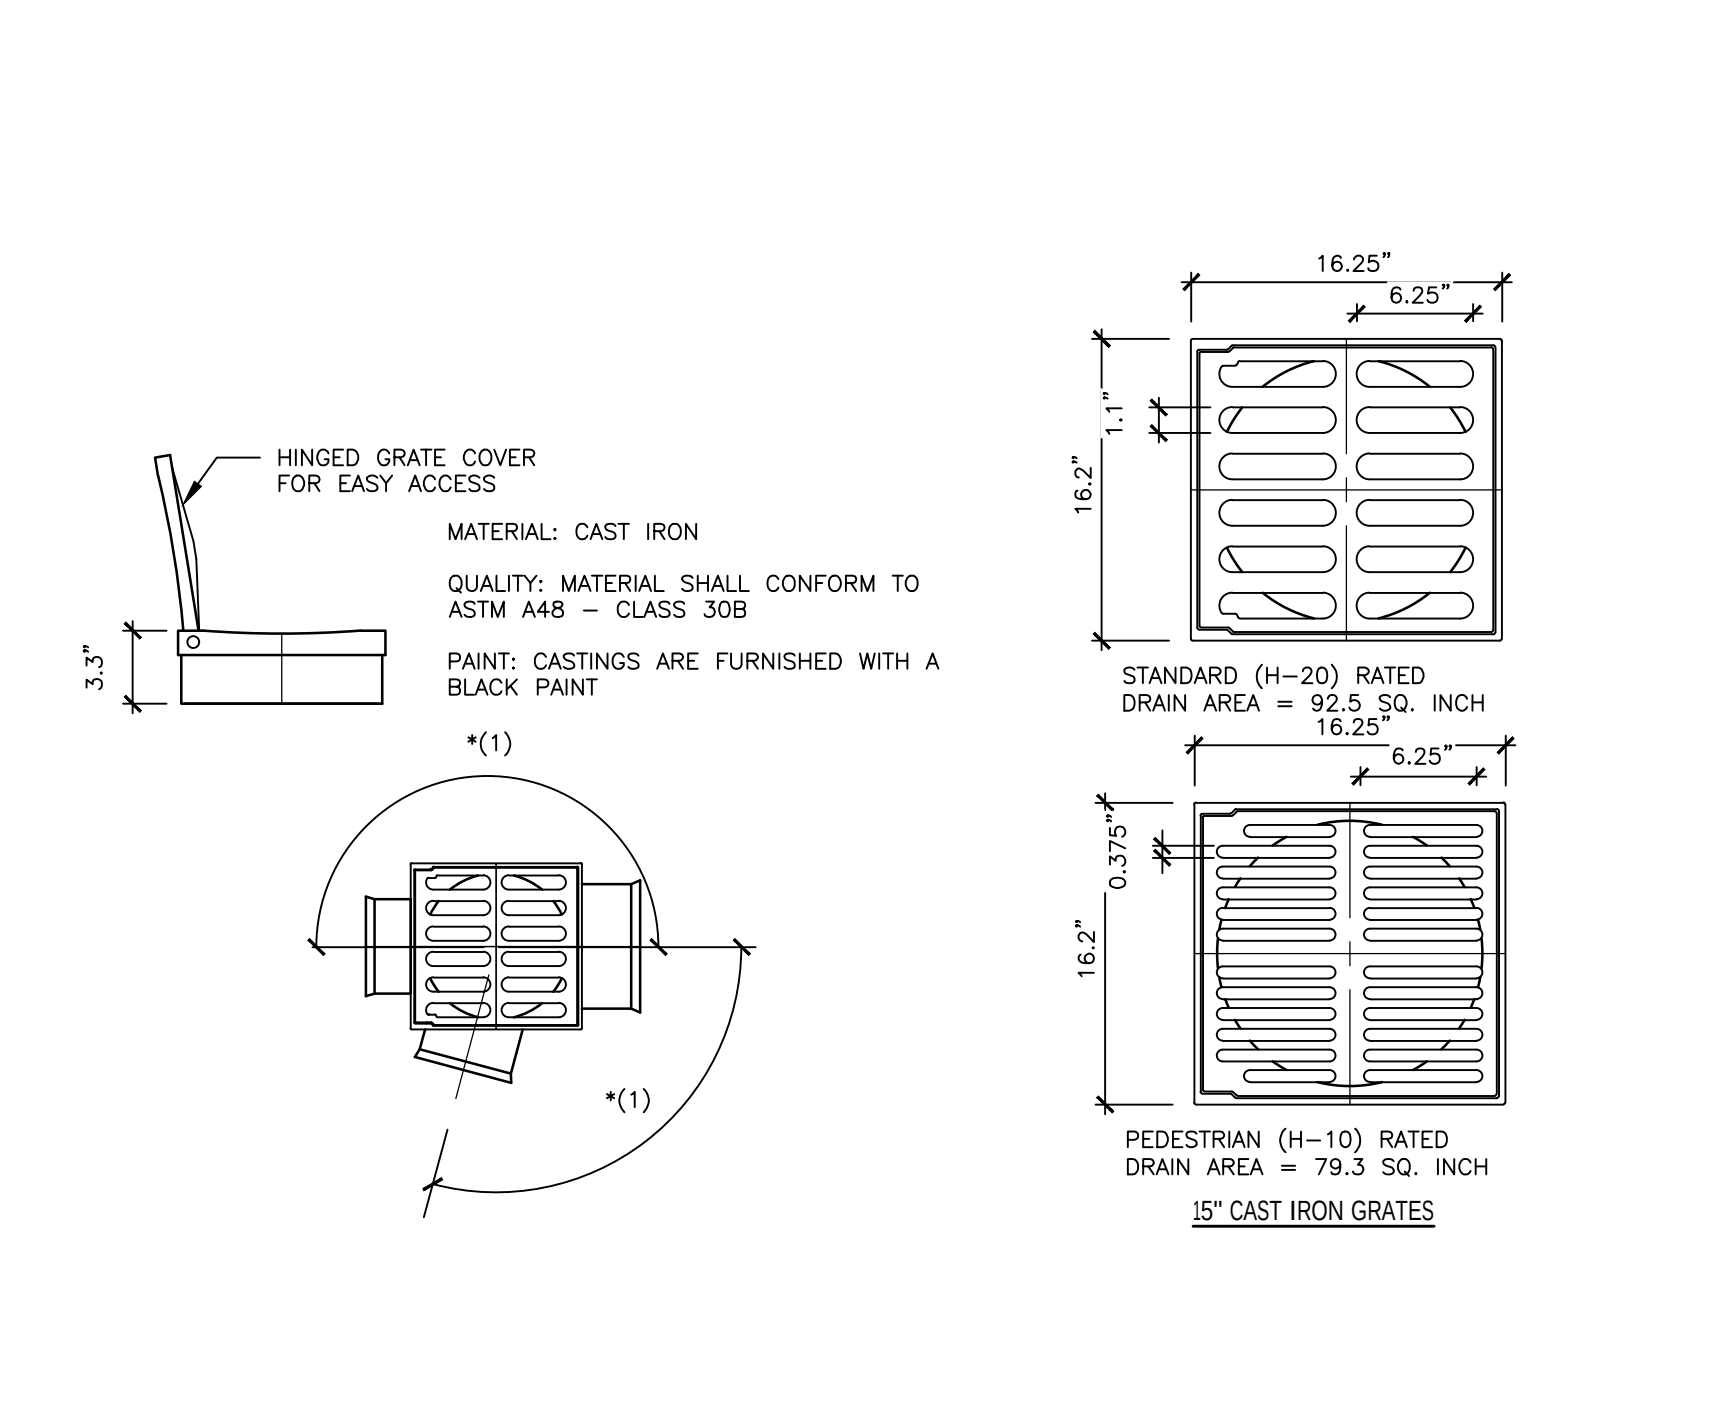


4 FLARED END SECTION

N.T.S.

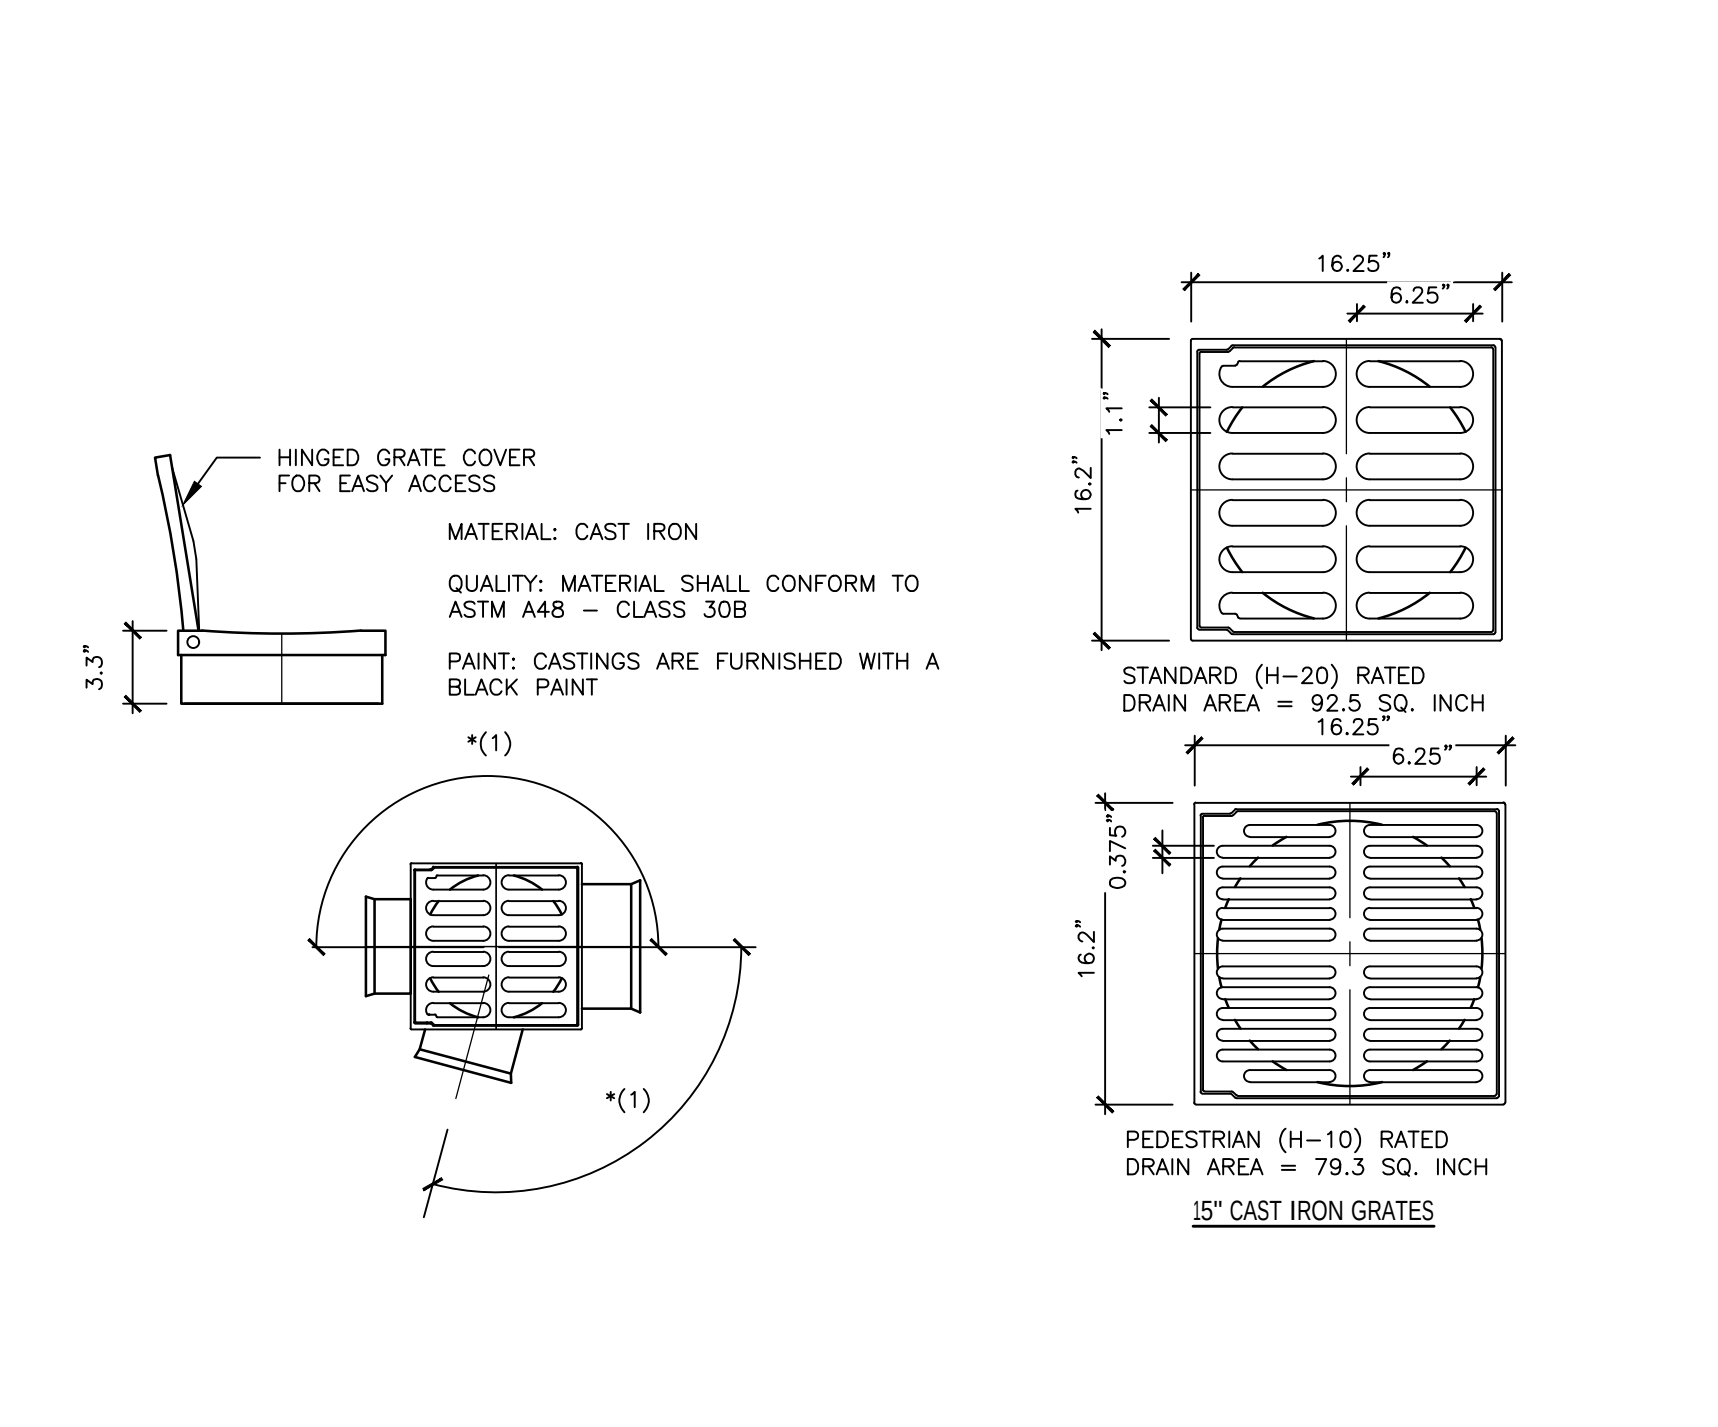


4 FLARED END SECTION

N.T.S.

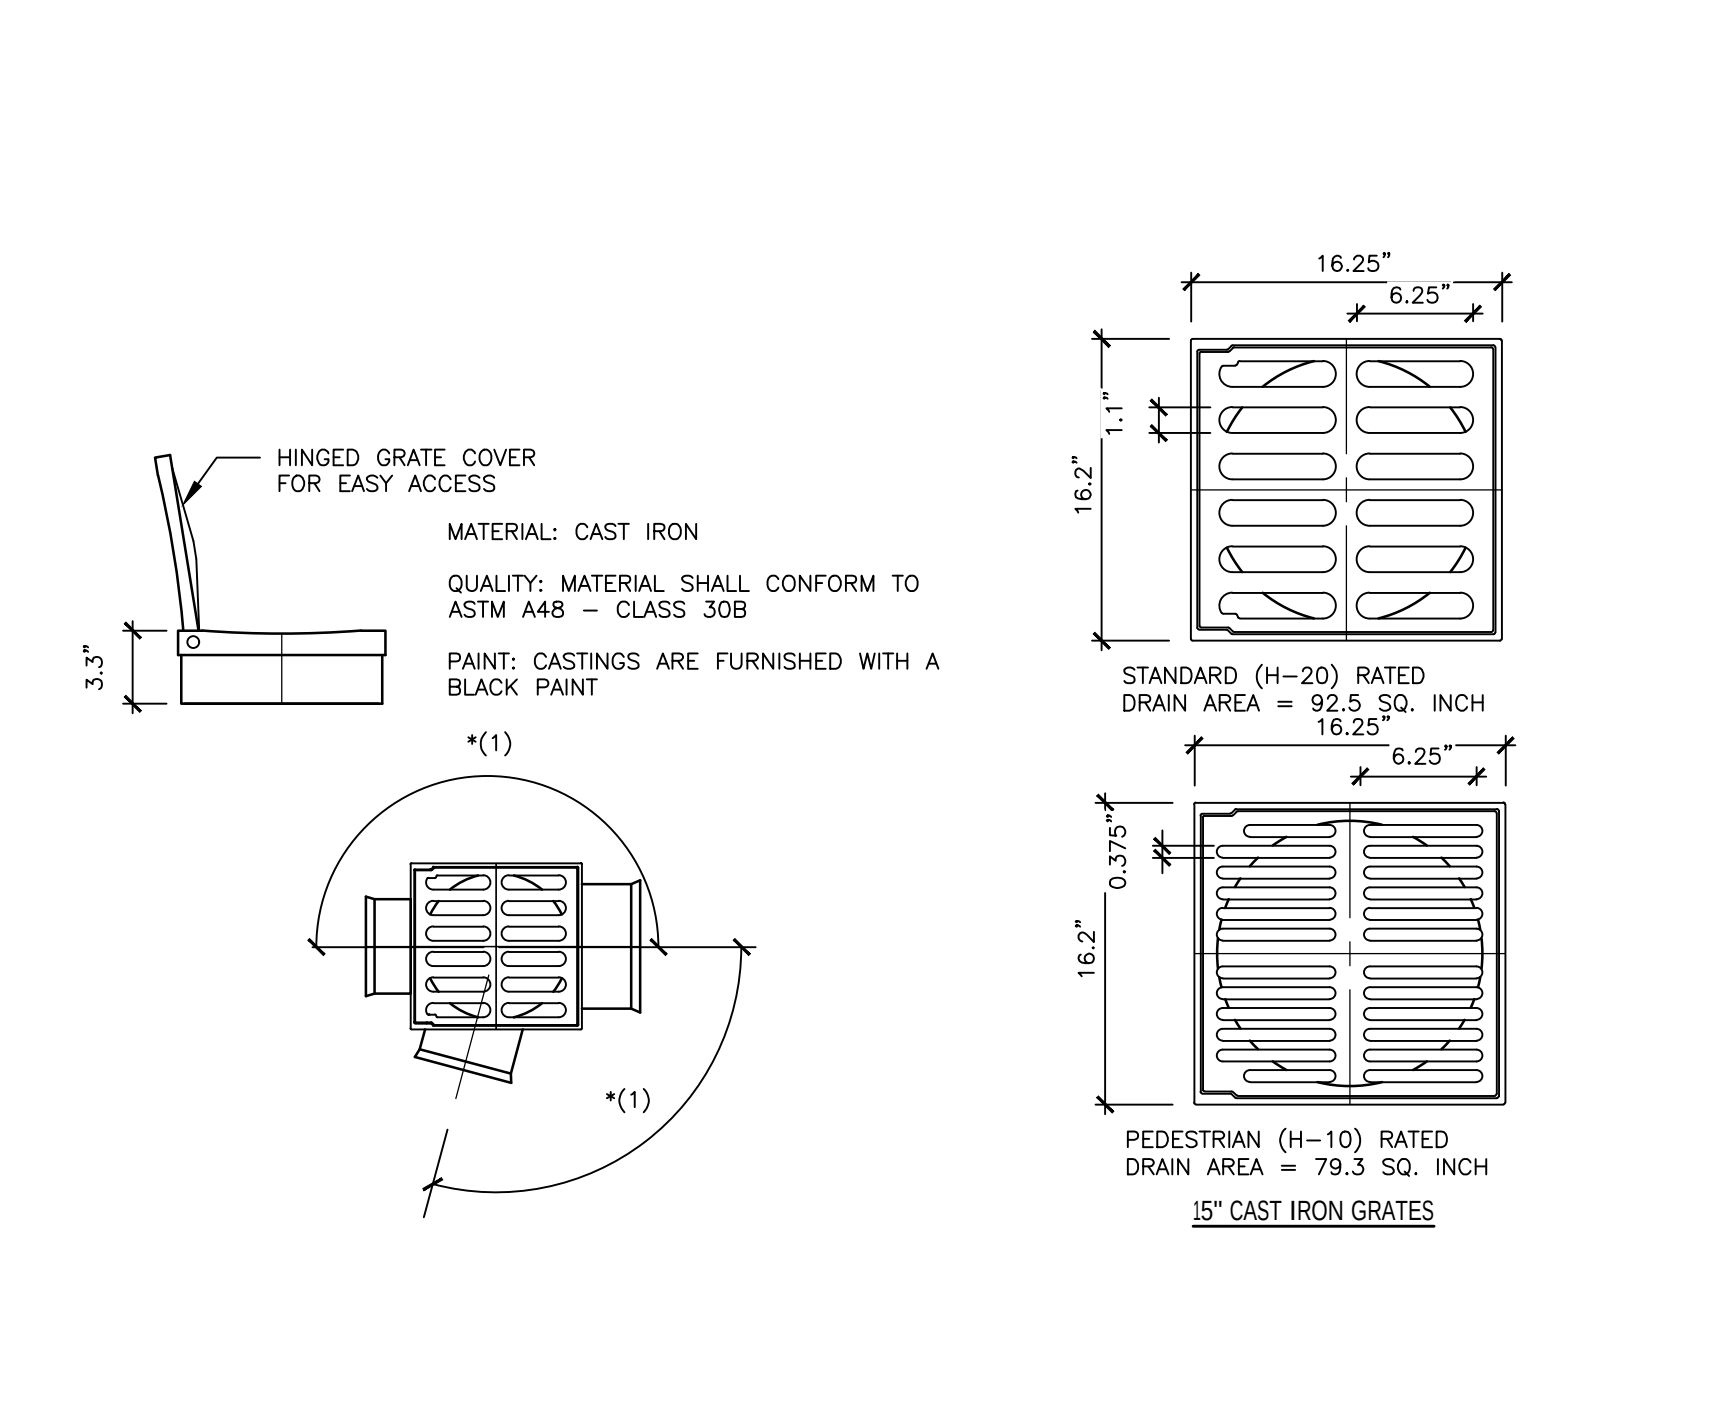


4 FLARED END SECTION

N.T.S.

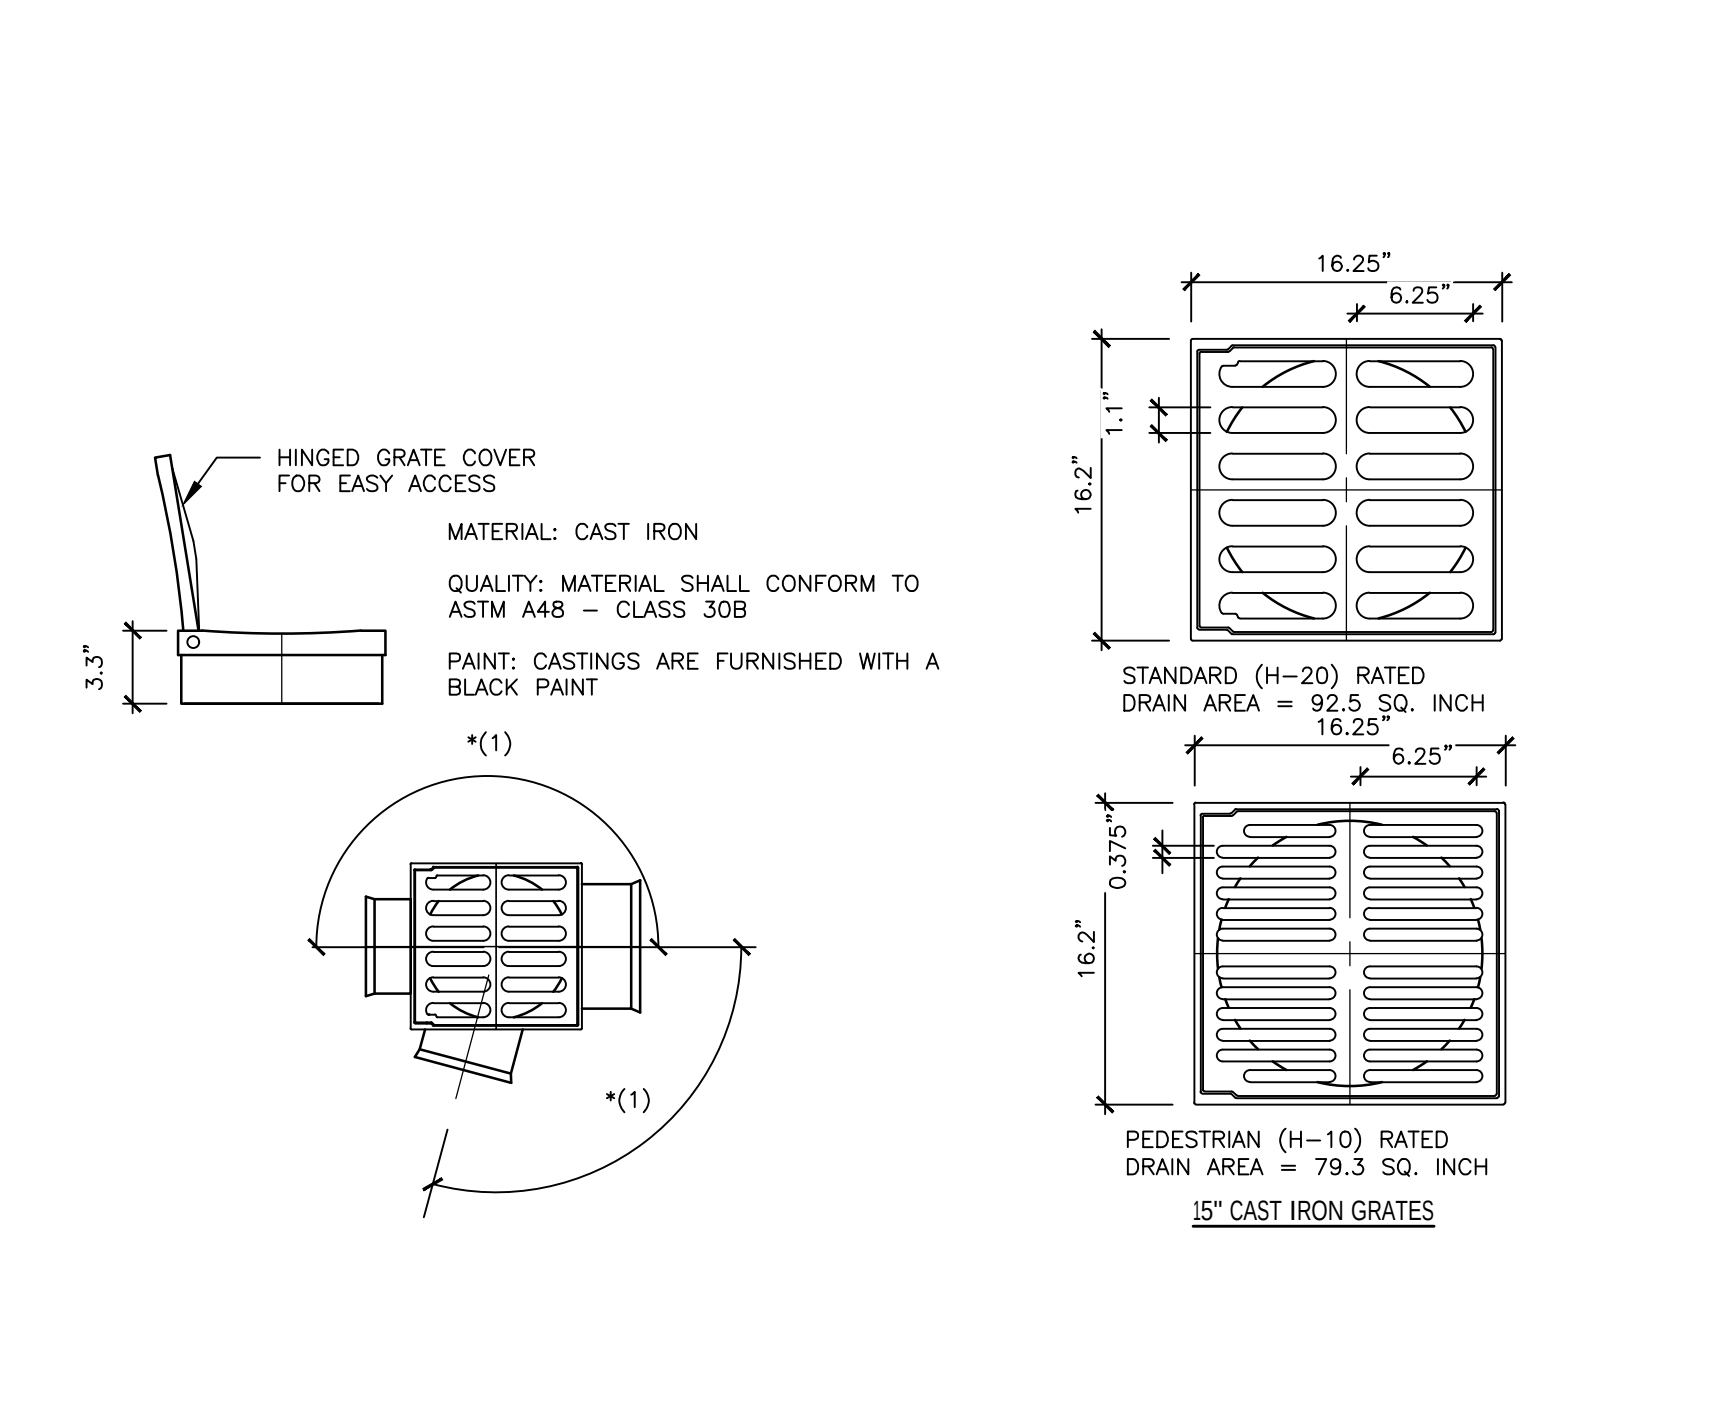


4 FLARED END SECTION

N.T.S.

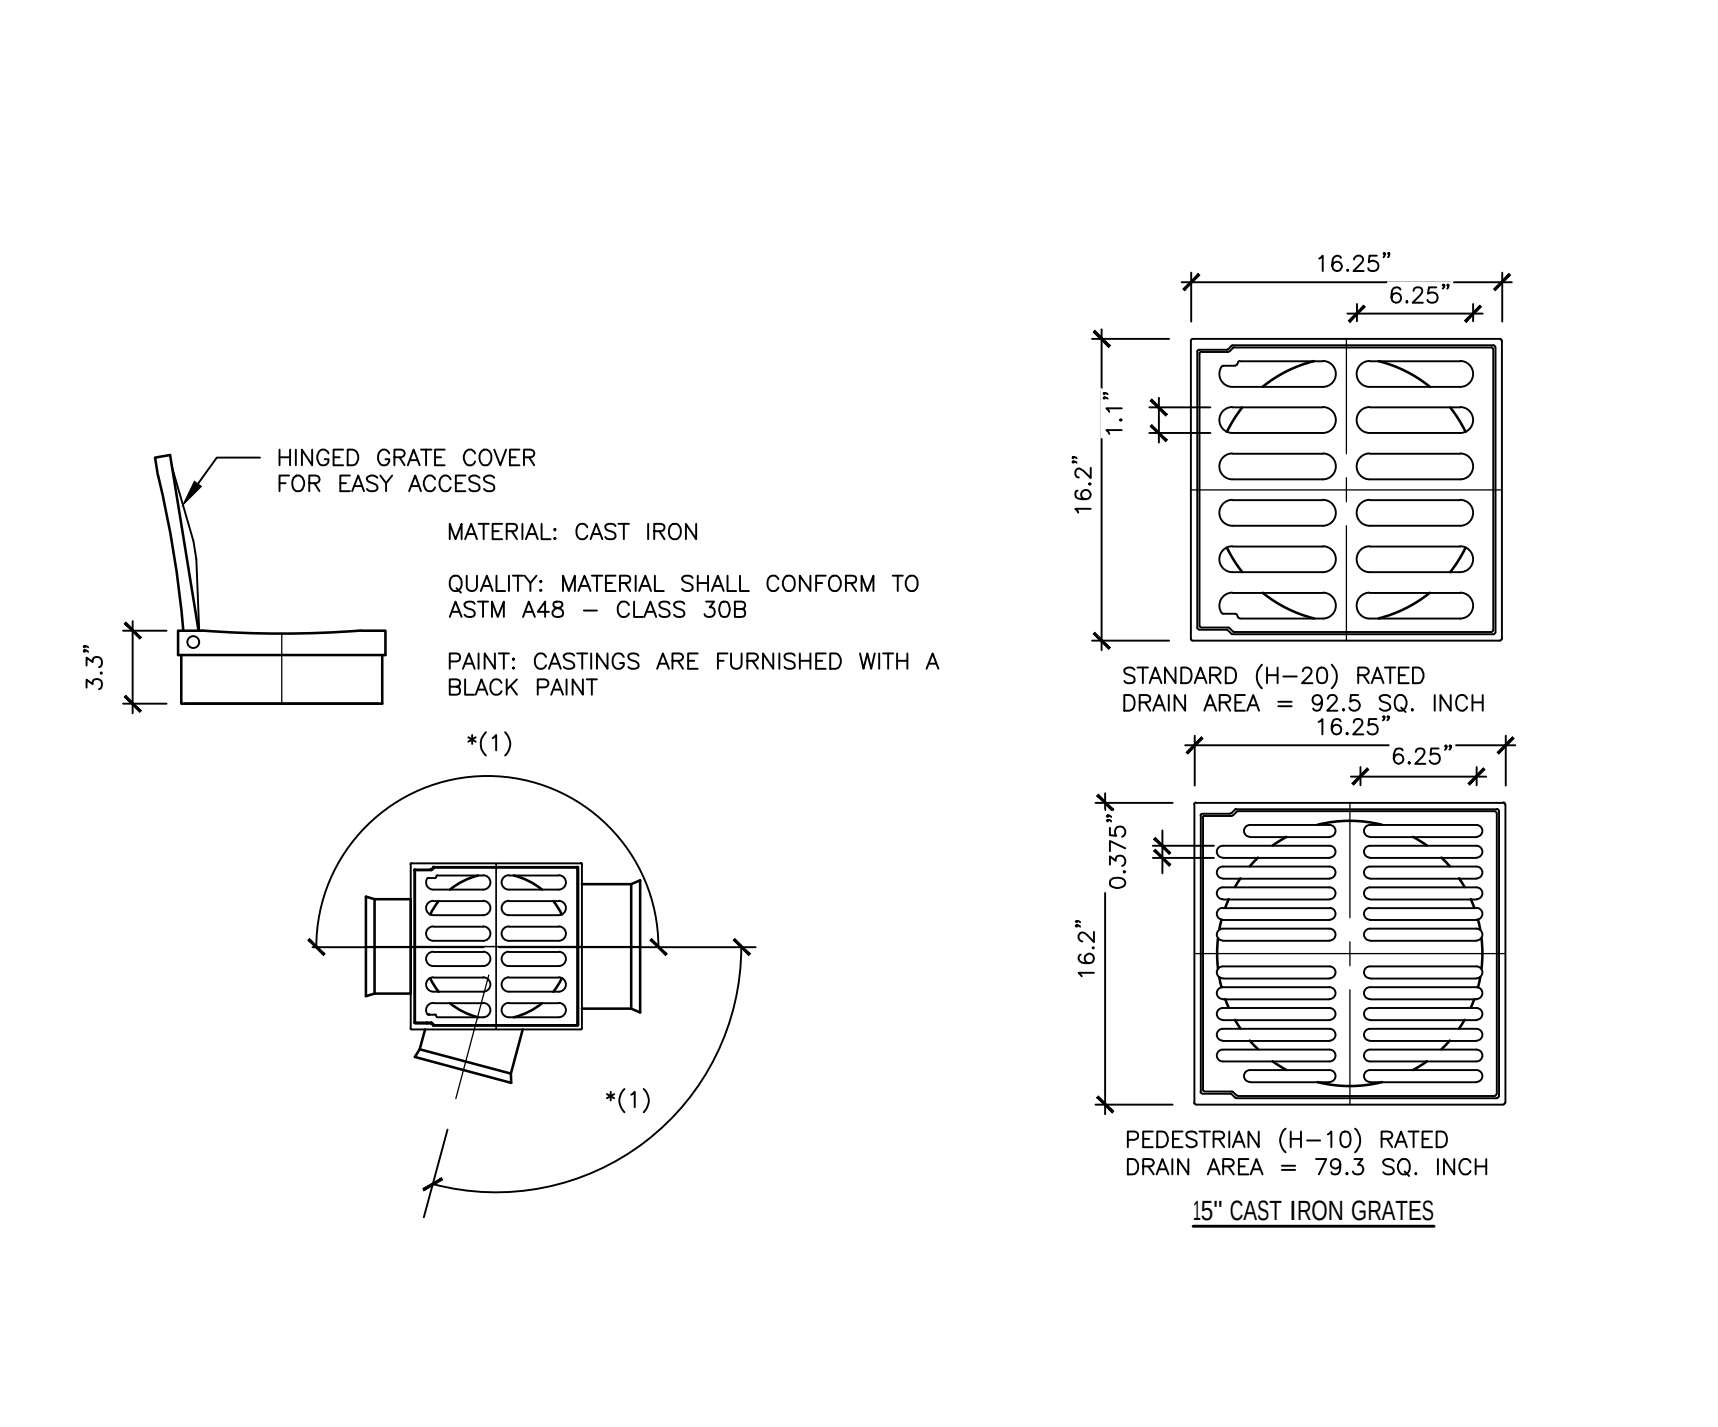


4 FLARED END SECTION

N.T.S.

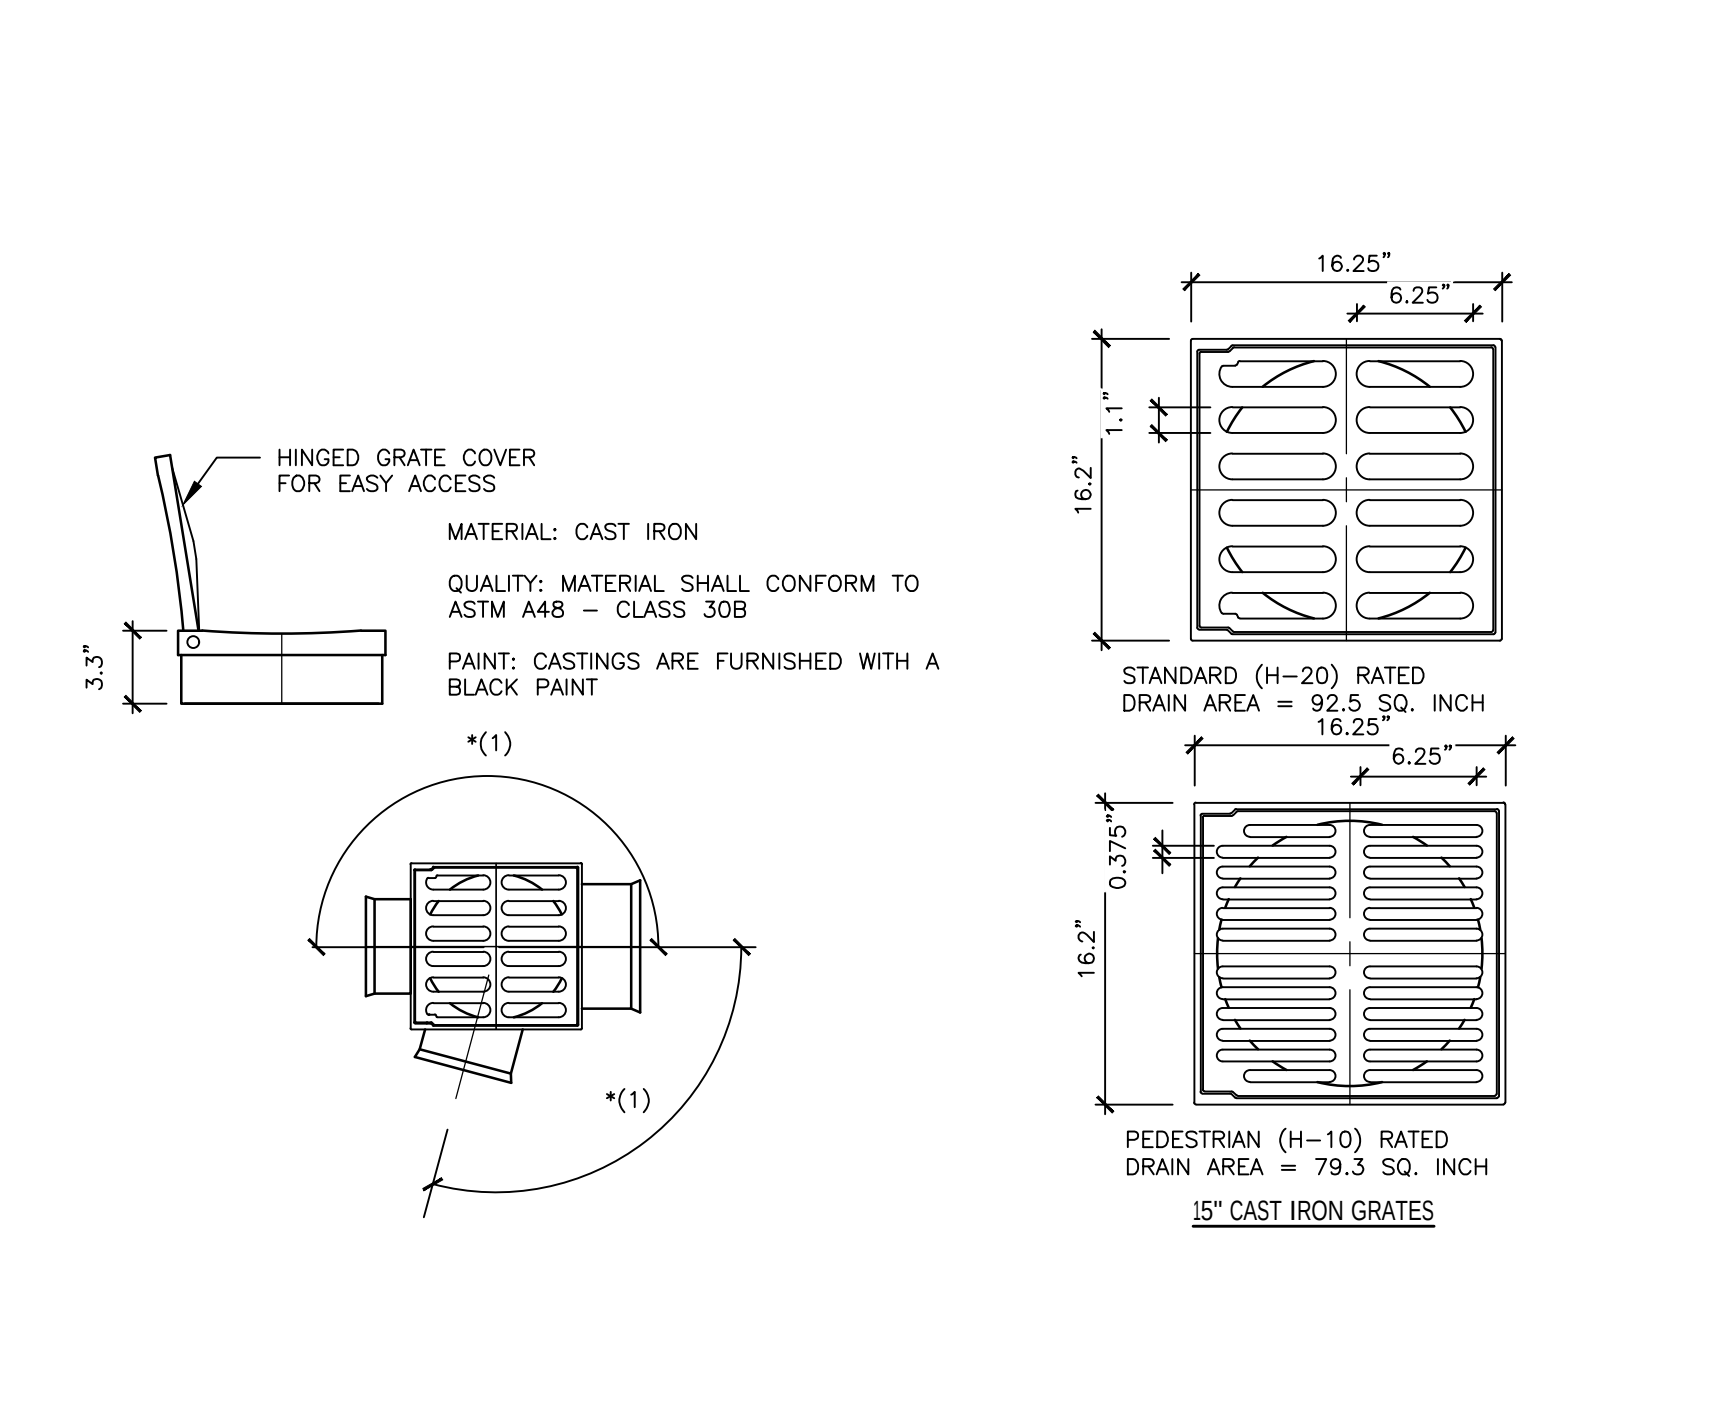


4 FLARED END SECTION

N.T.S.

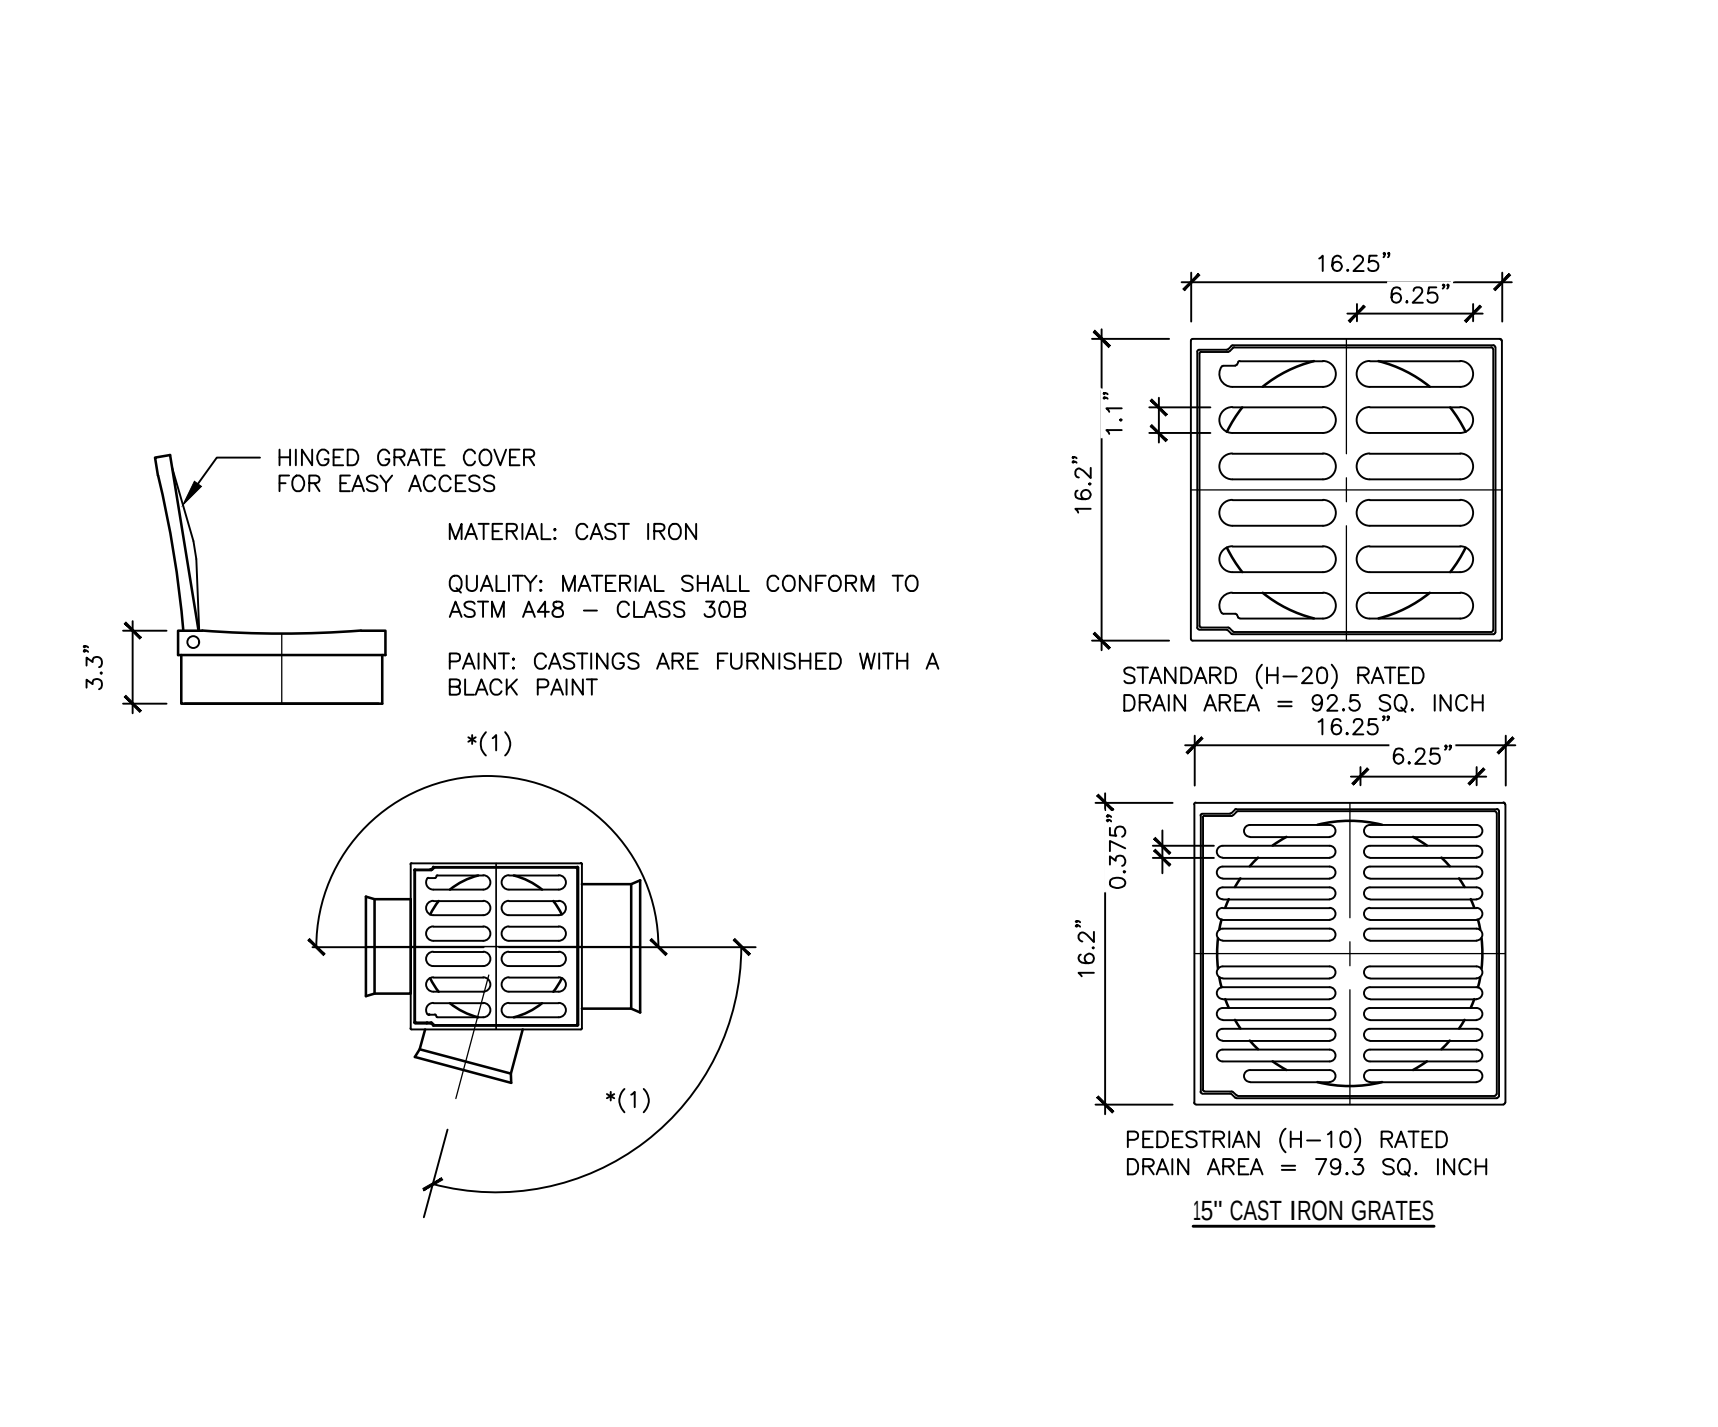


4 FLARED END SECTION

N.T.S.

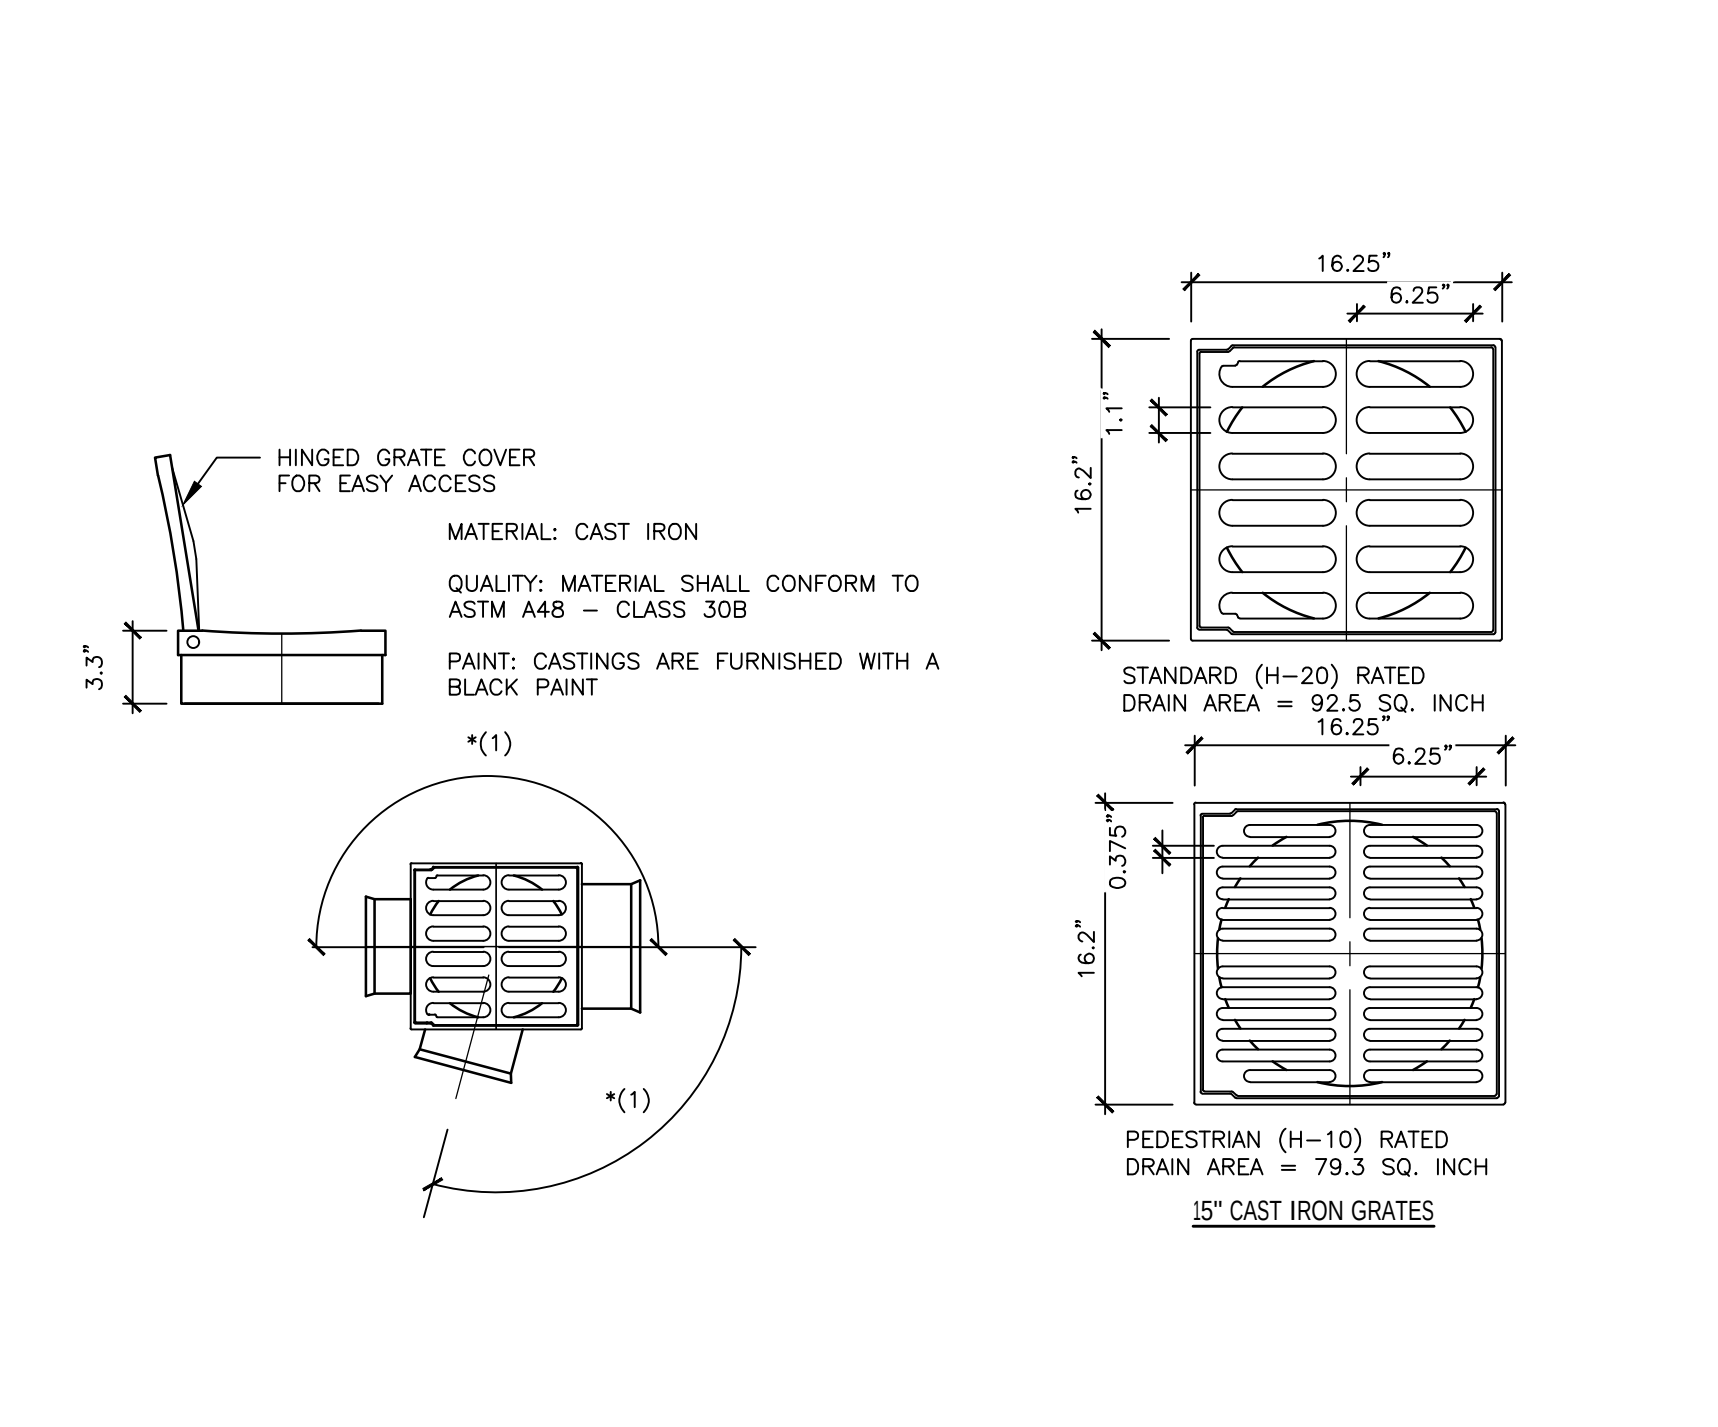


4 FLARED END SECTION

N.T.S.

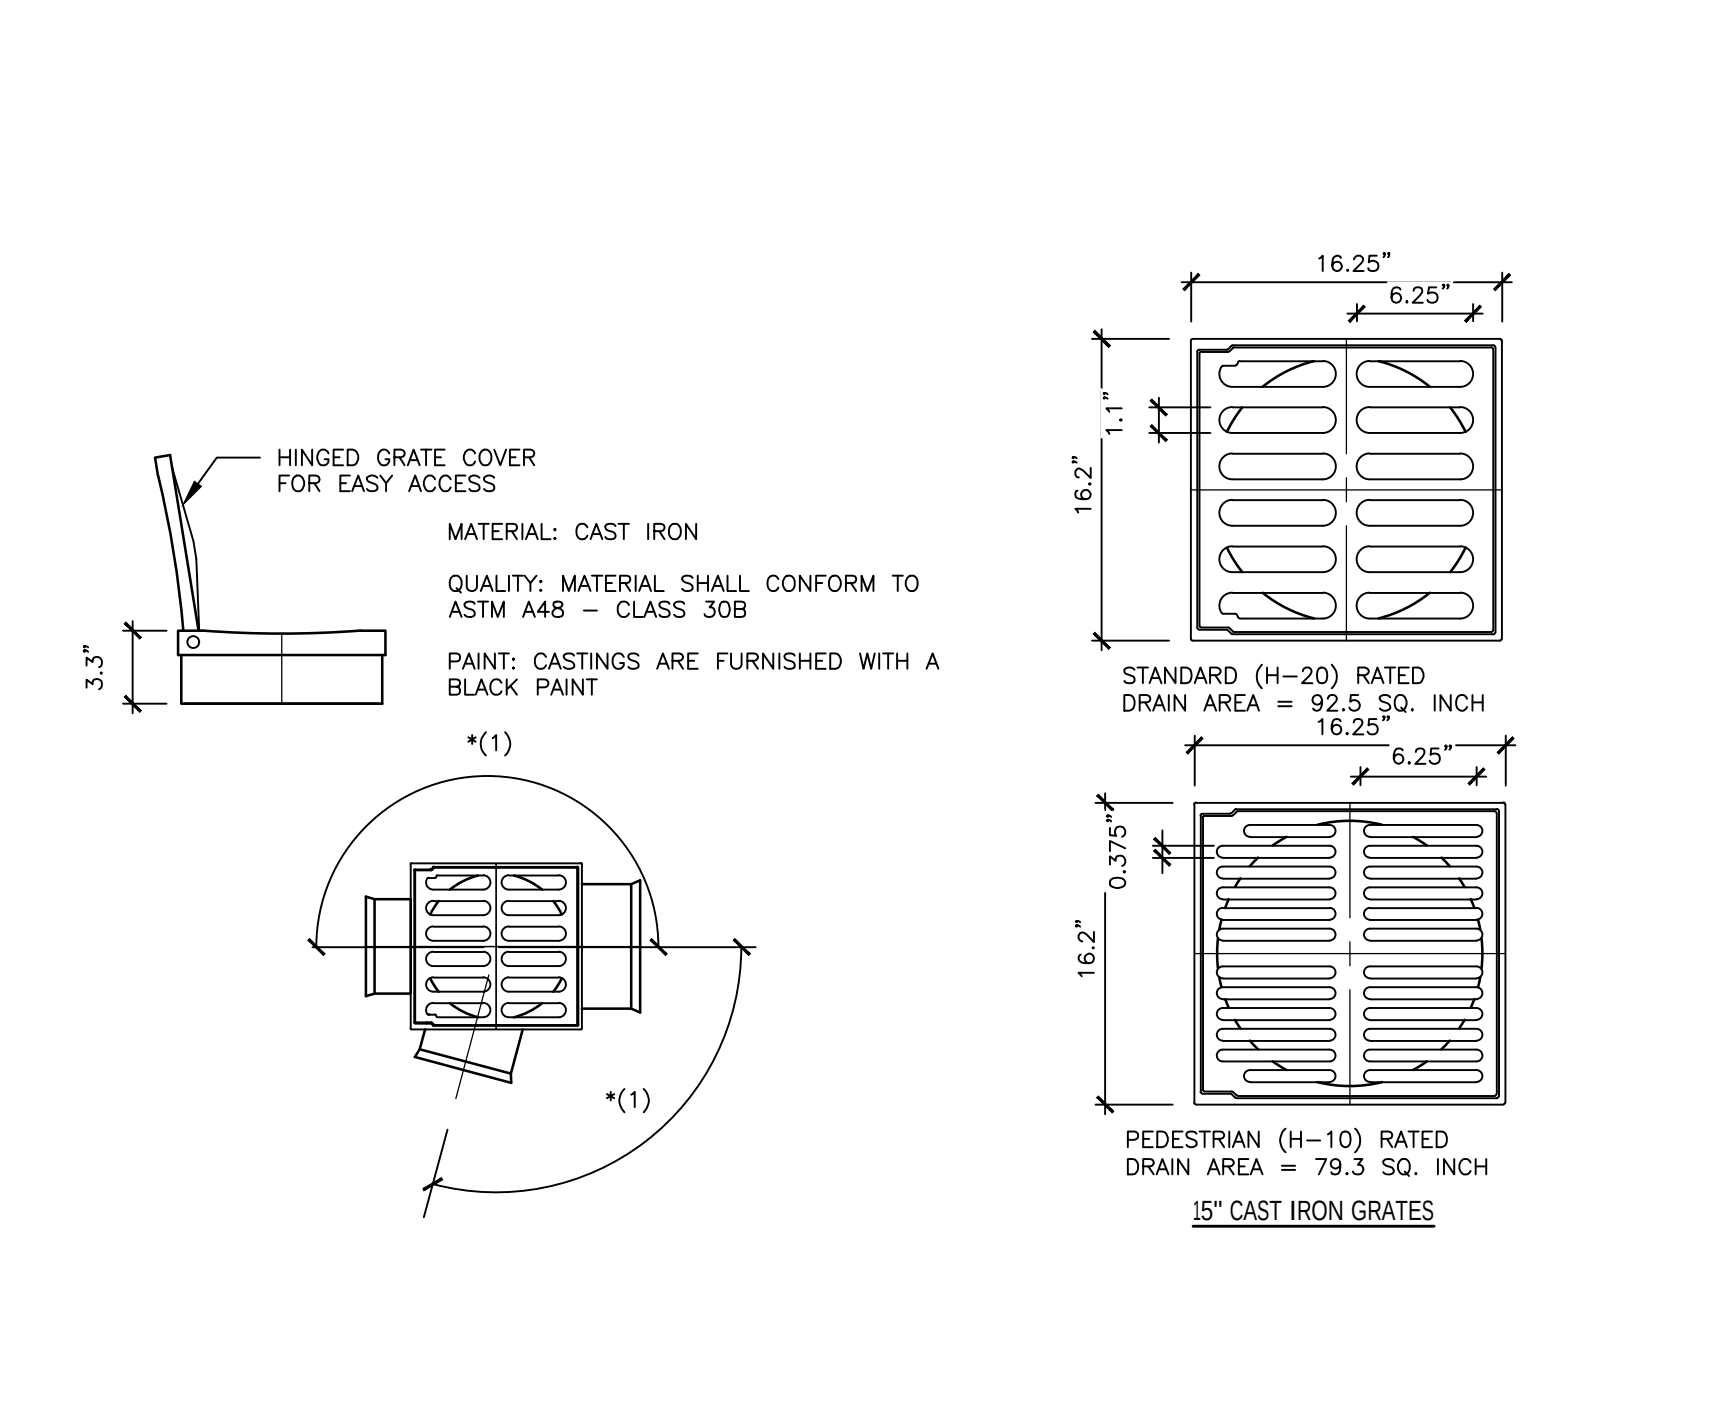


4 FLARED END SECTION

N.T.S.

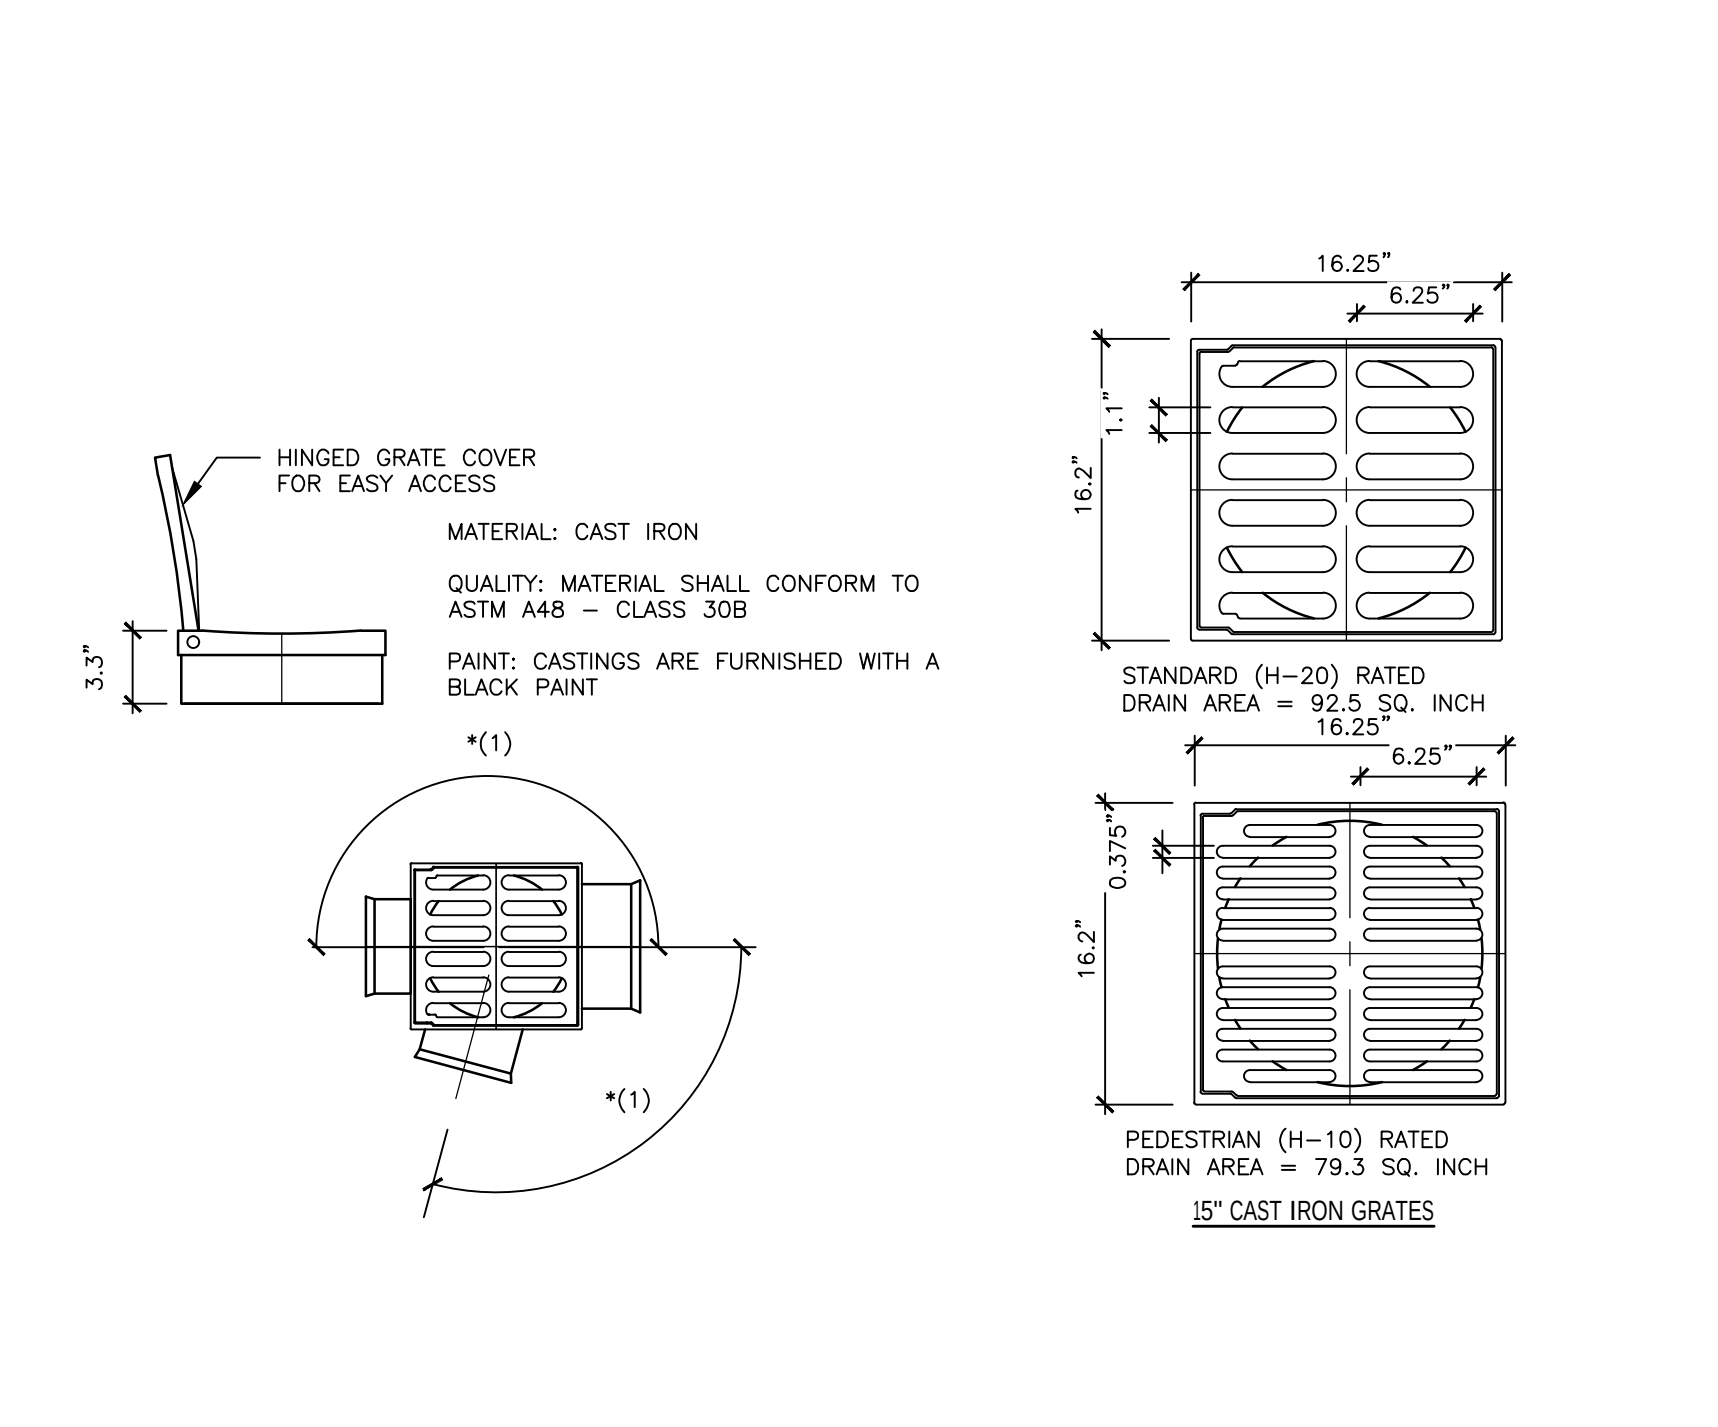


4 FLARED END SECTION

N.T.S.

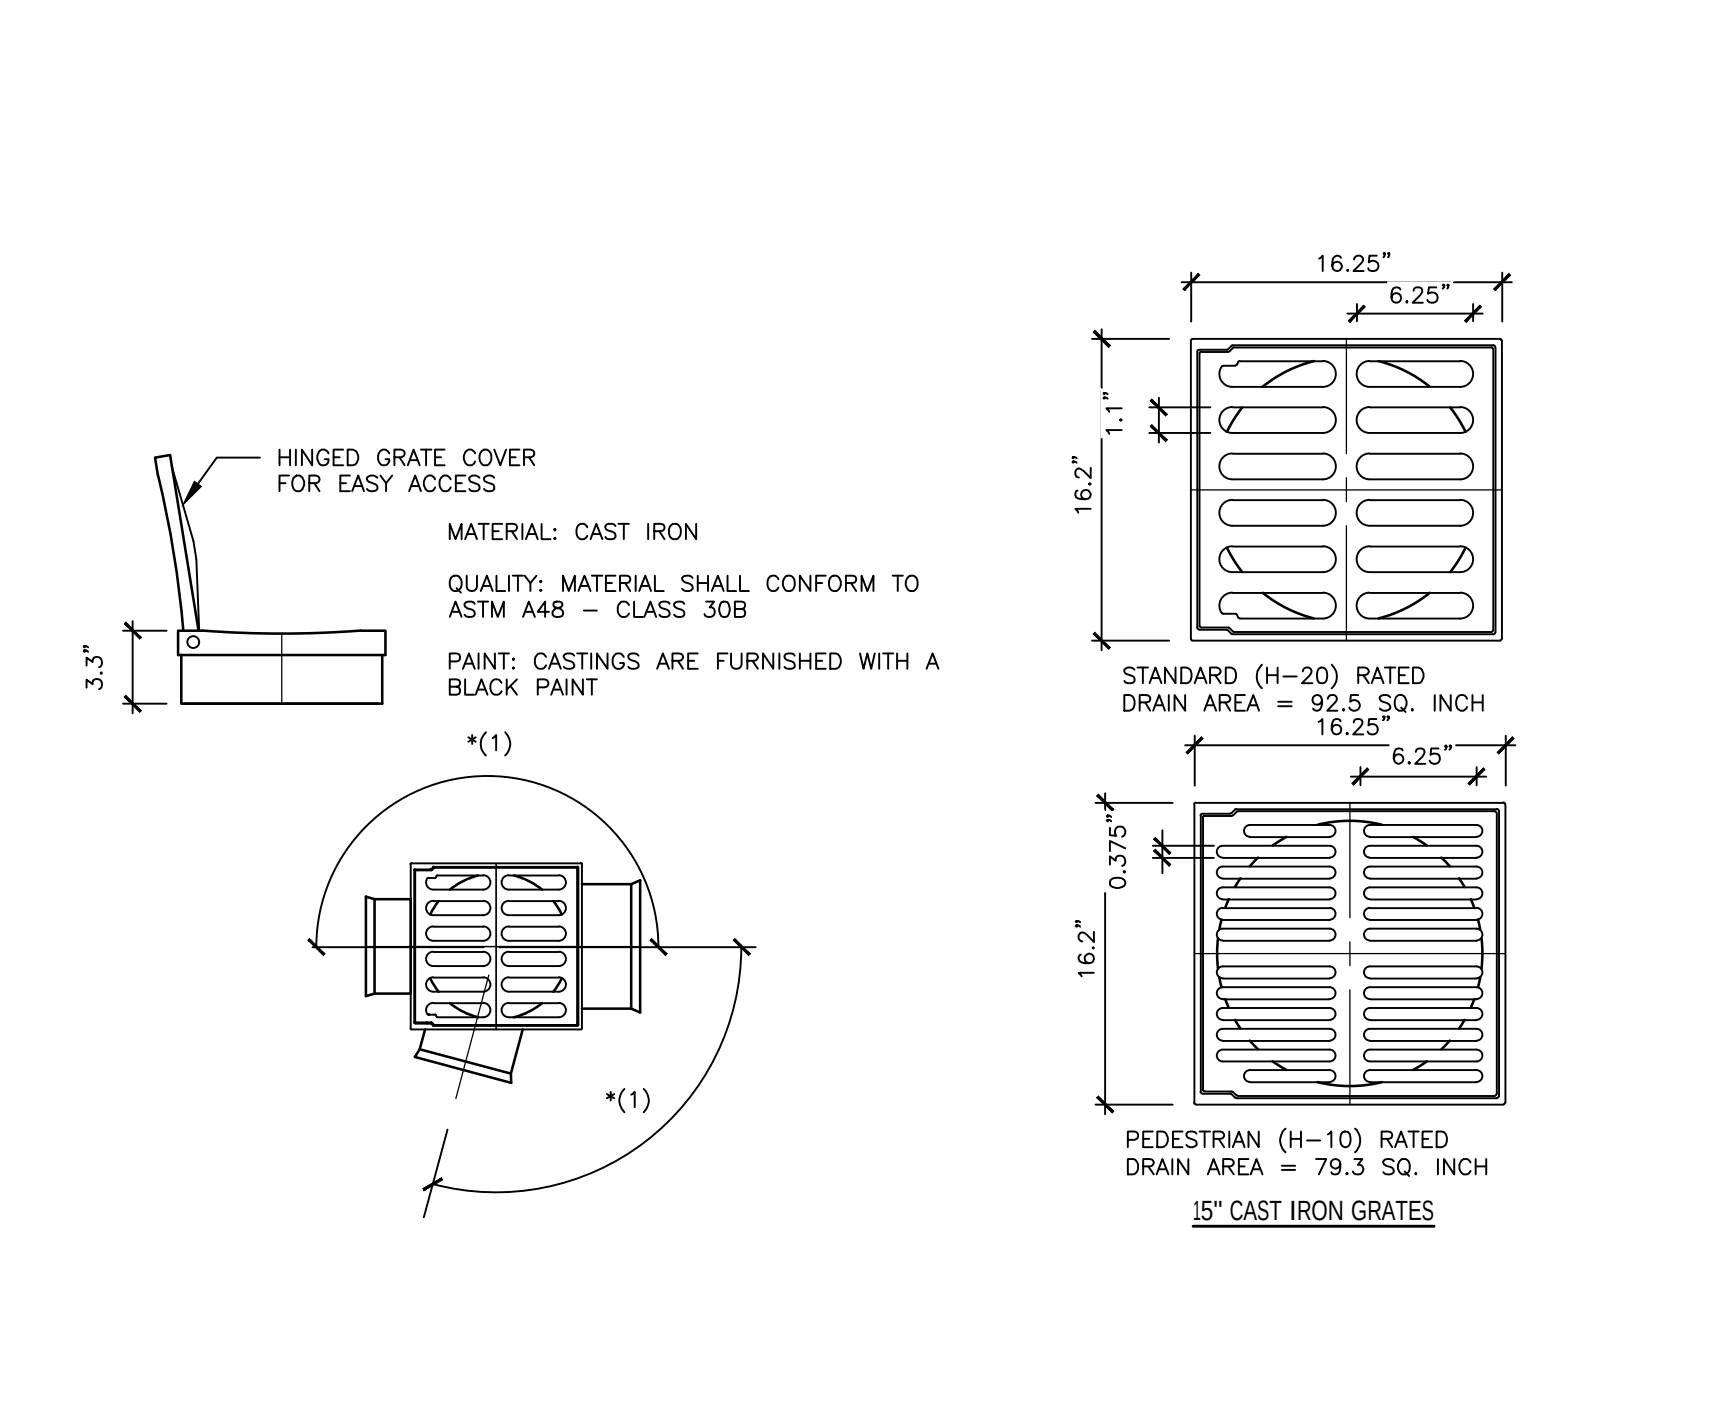


4 FLARED END SECTION

N.T.S.

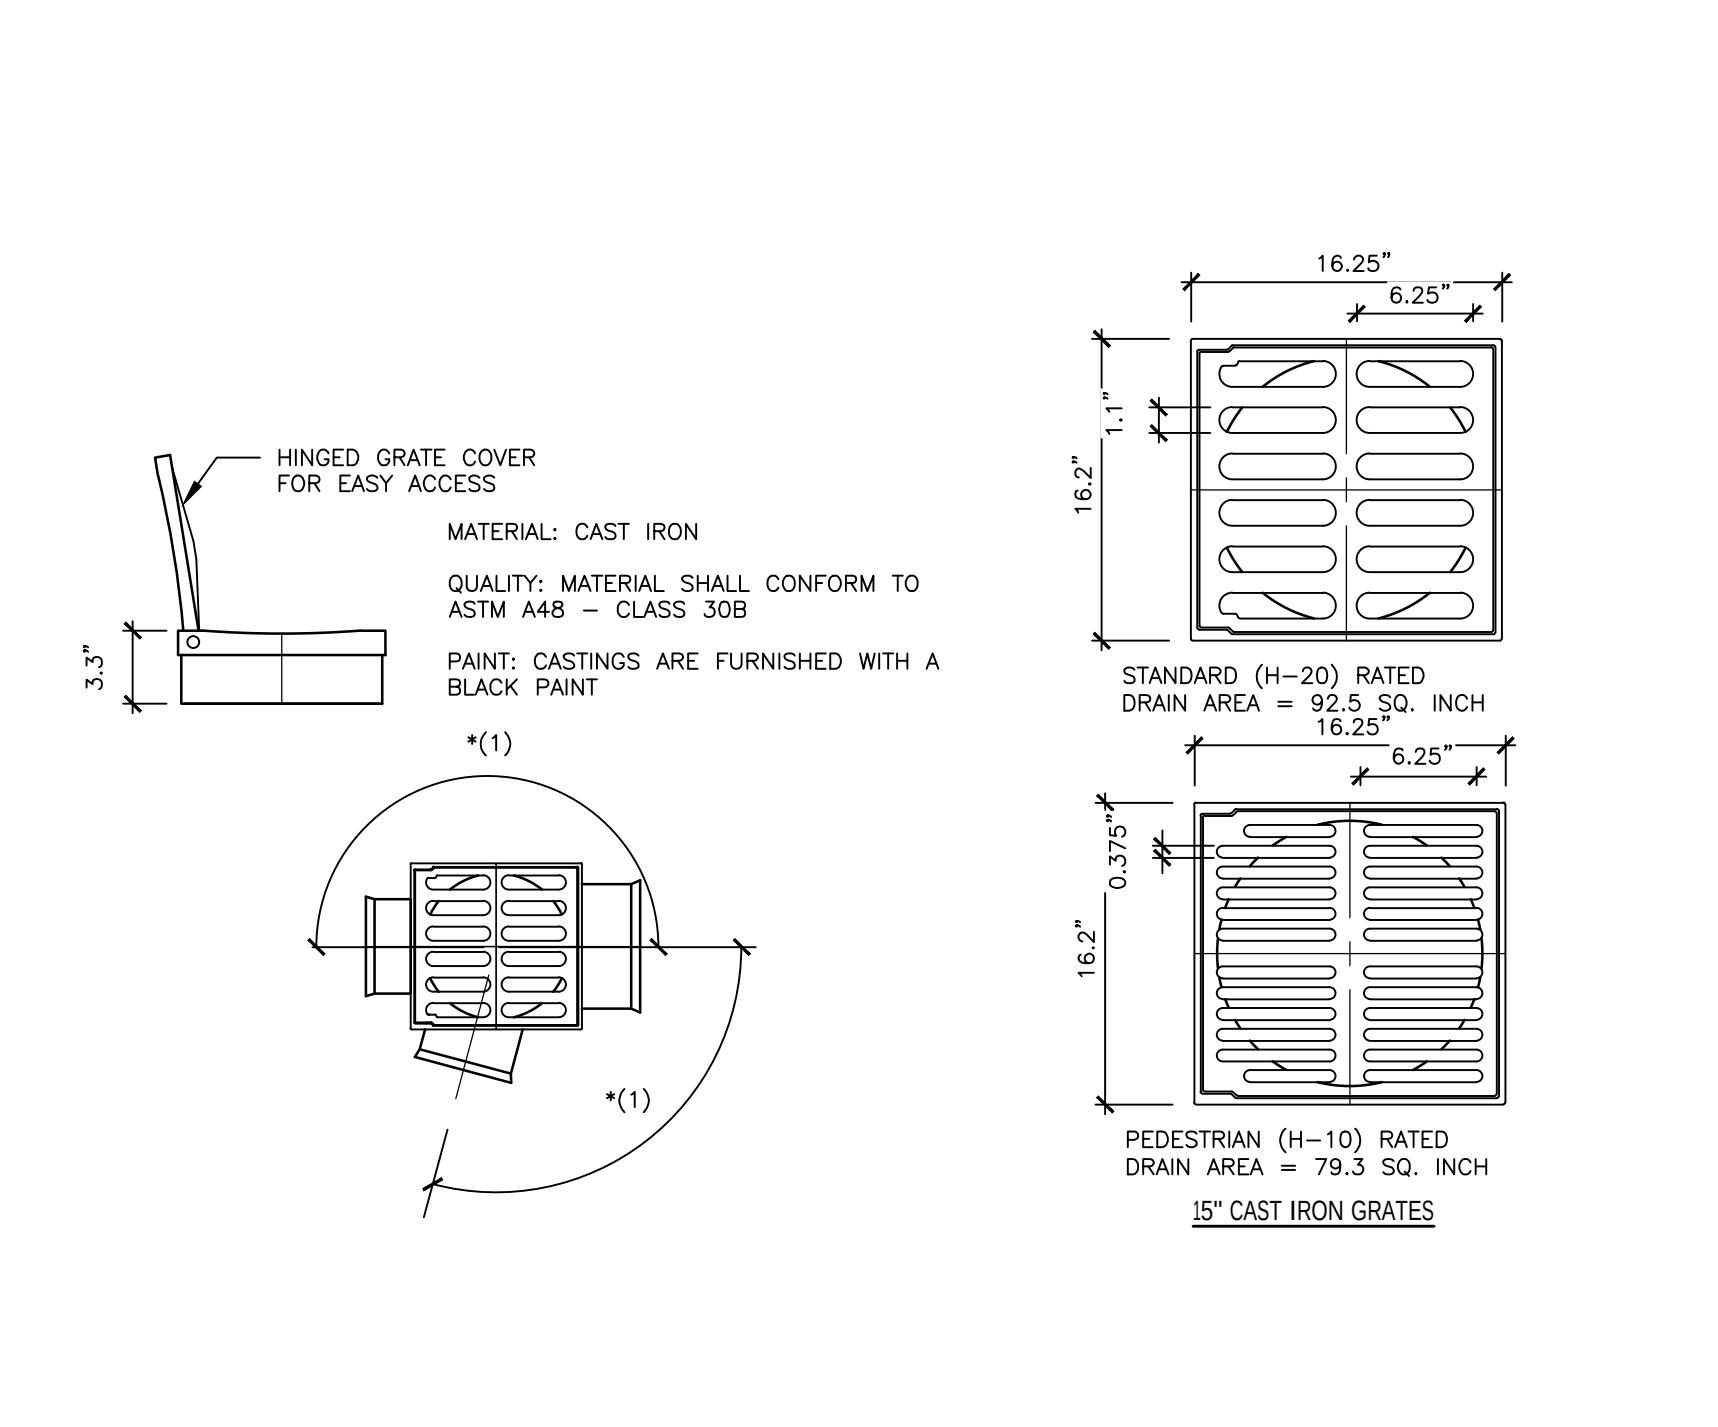


4 FLARED END SECTION

N.T.S.

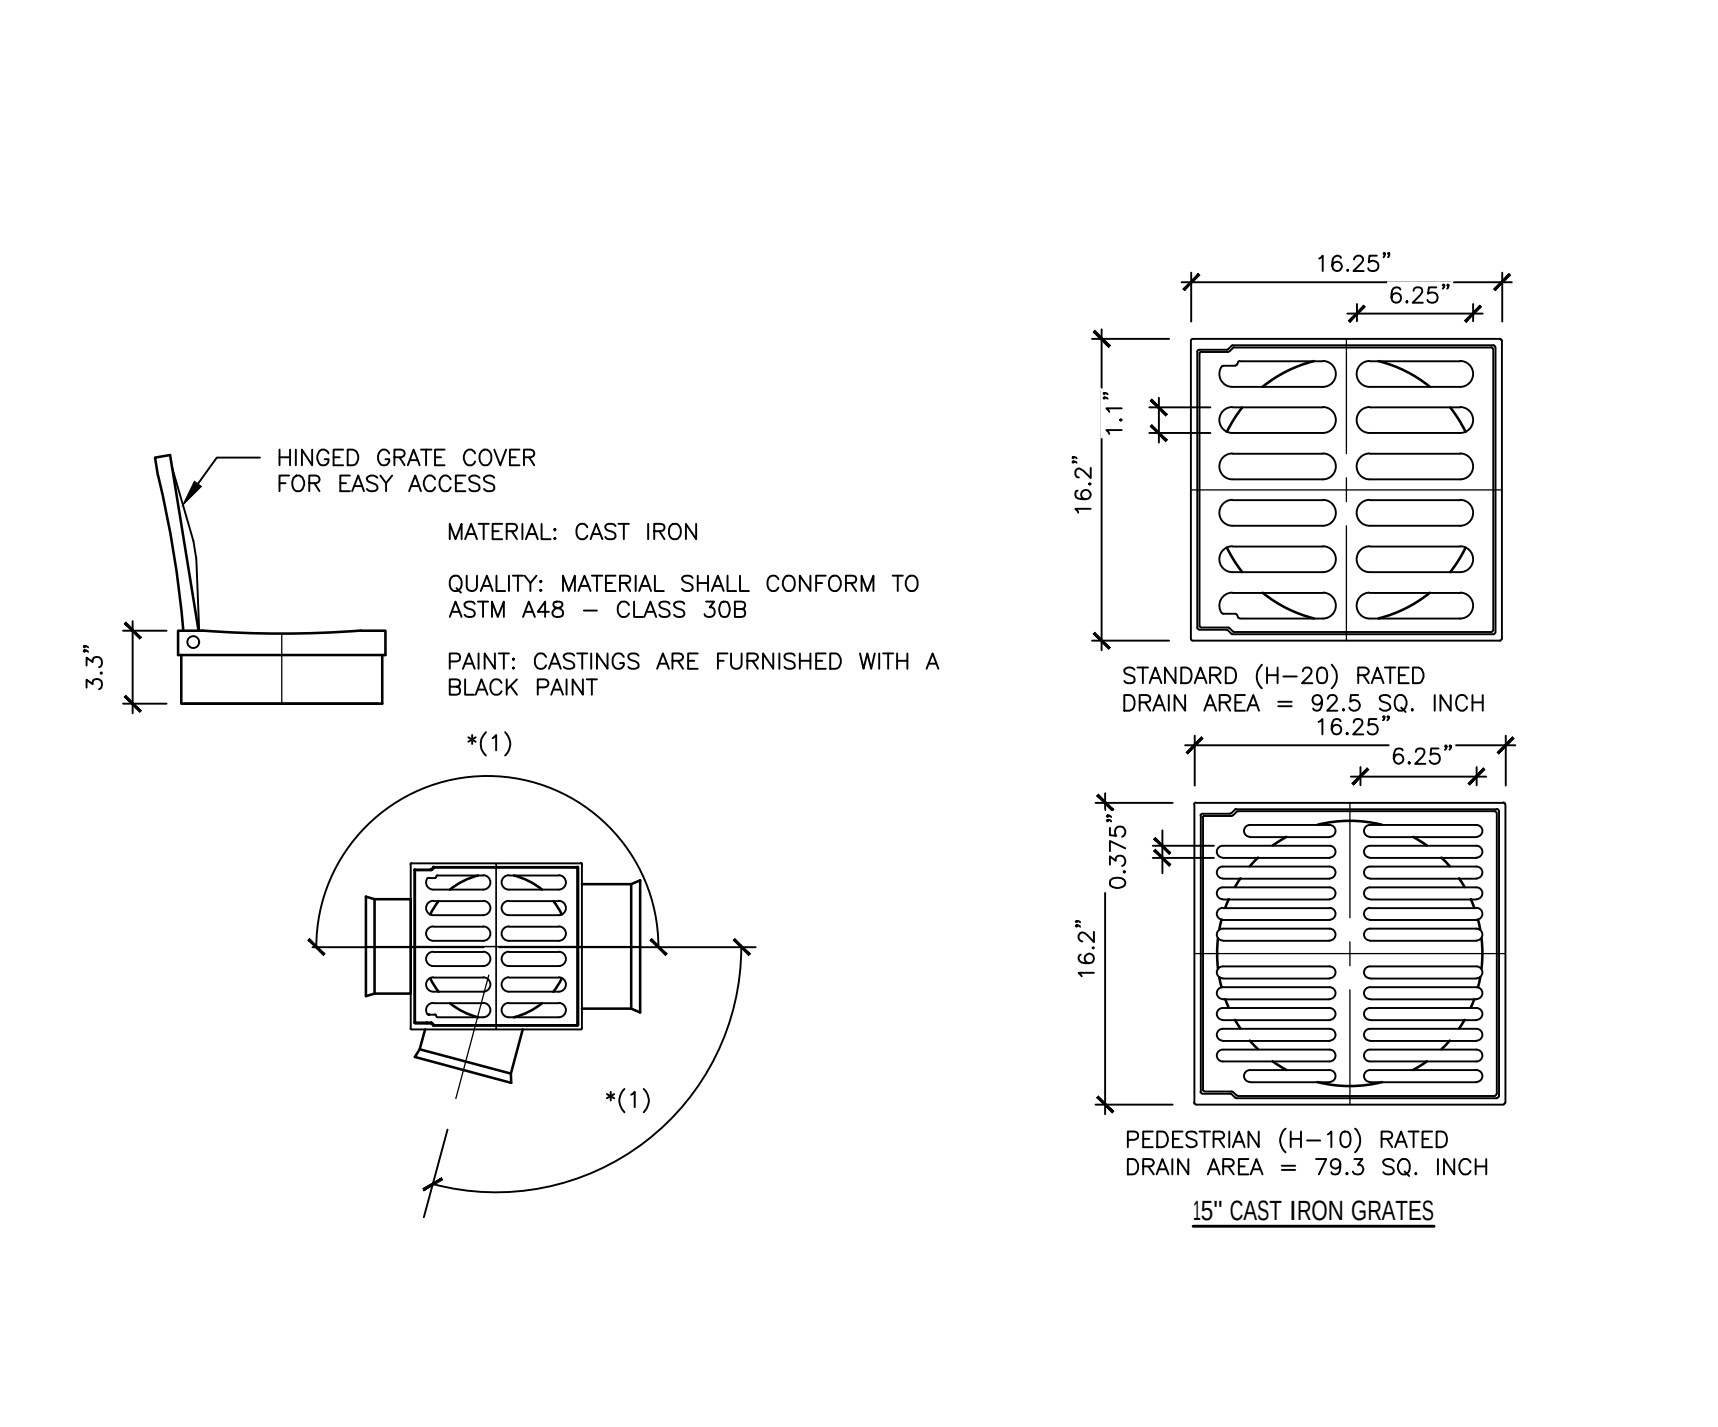


4 FLARED END SECTION

N.T.S.

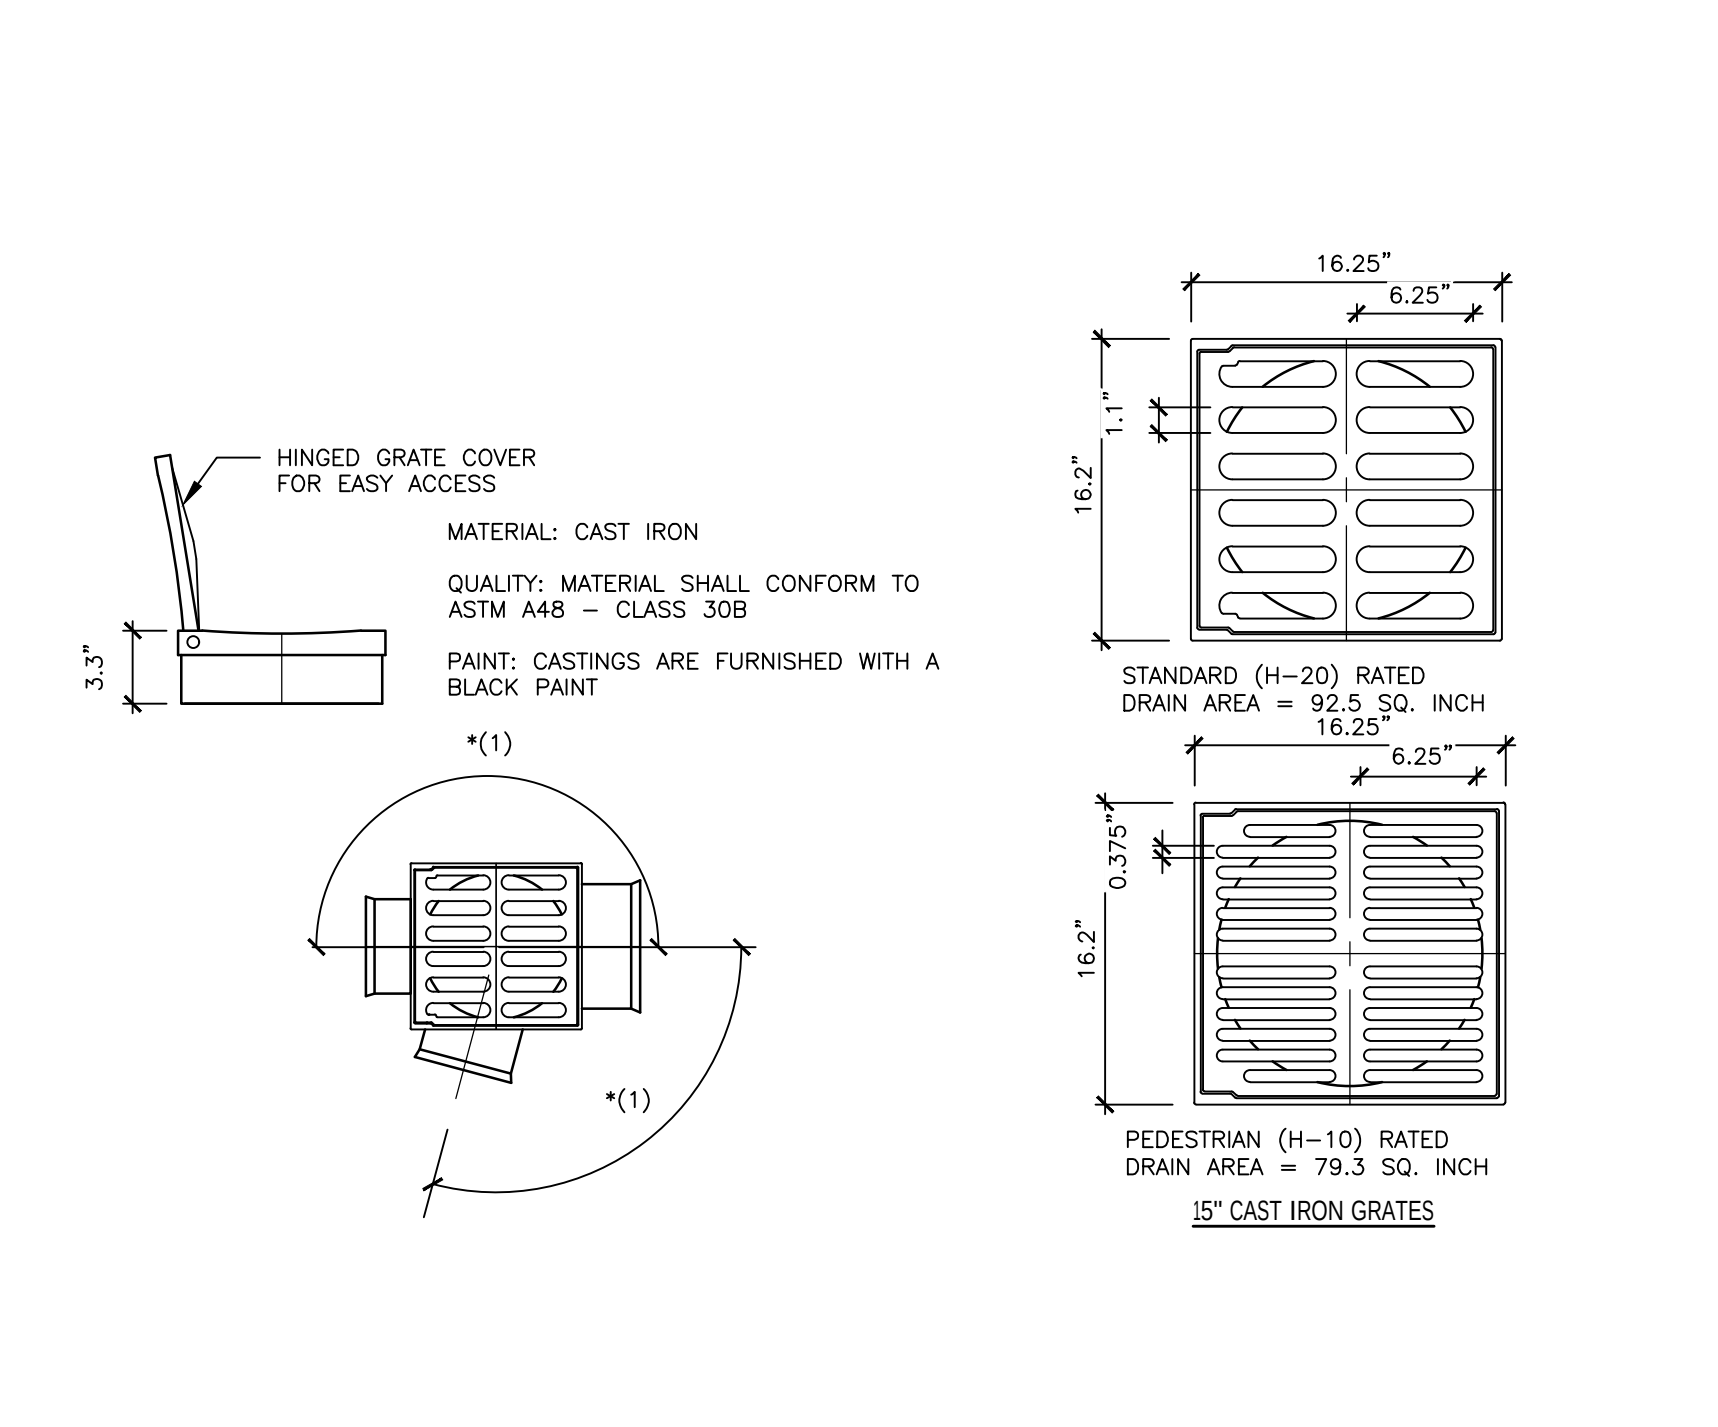


4 FLARED END SECTION

N.T.S.

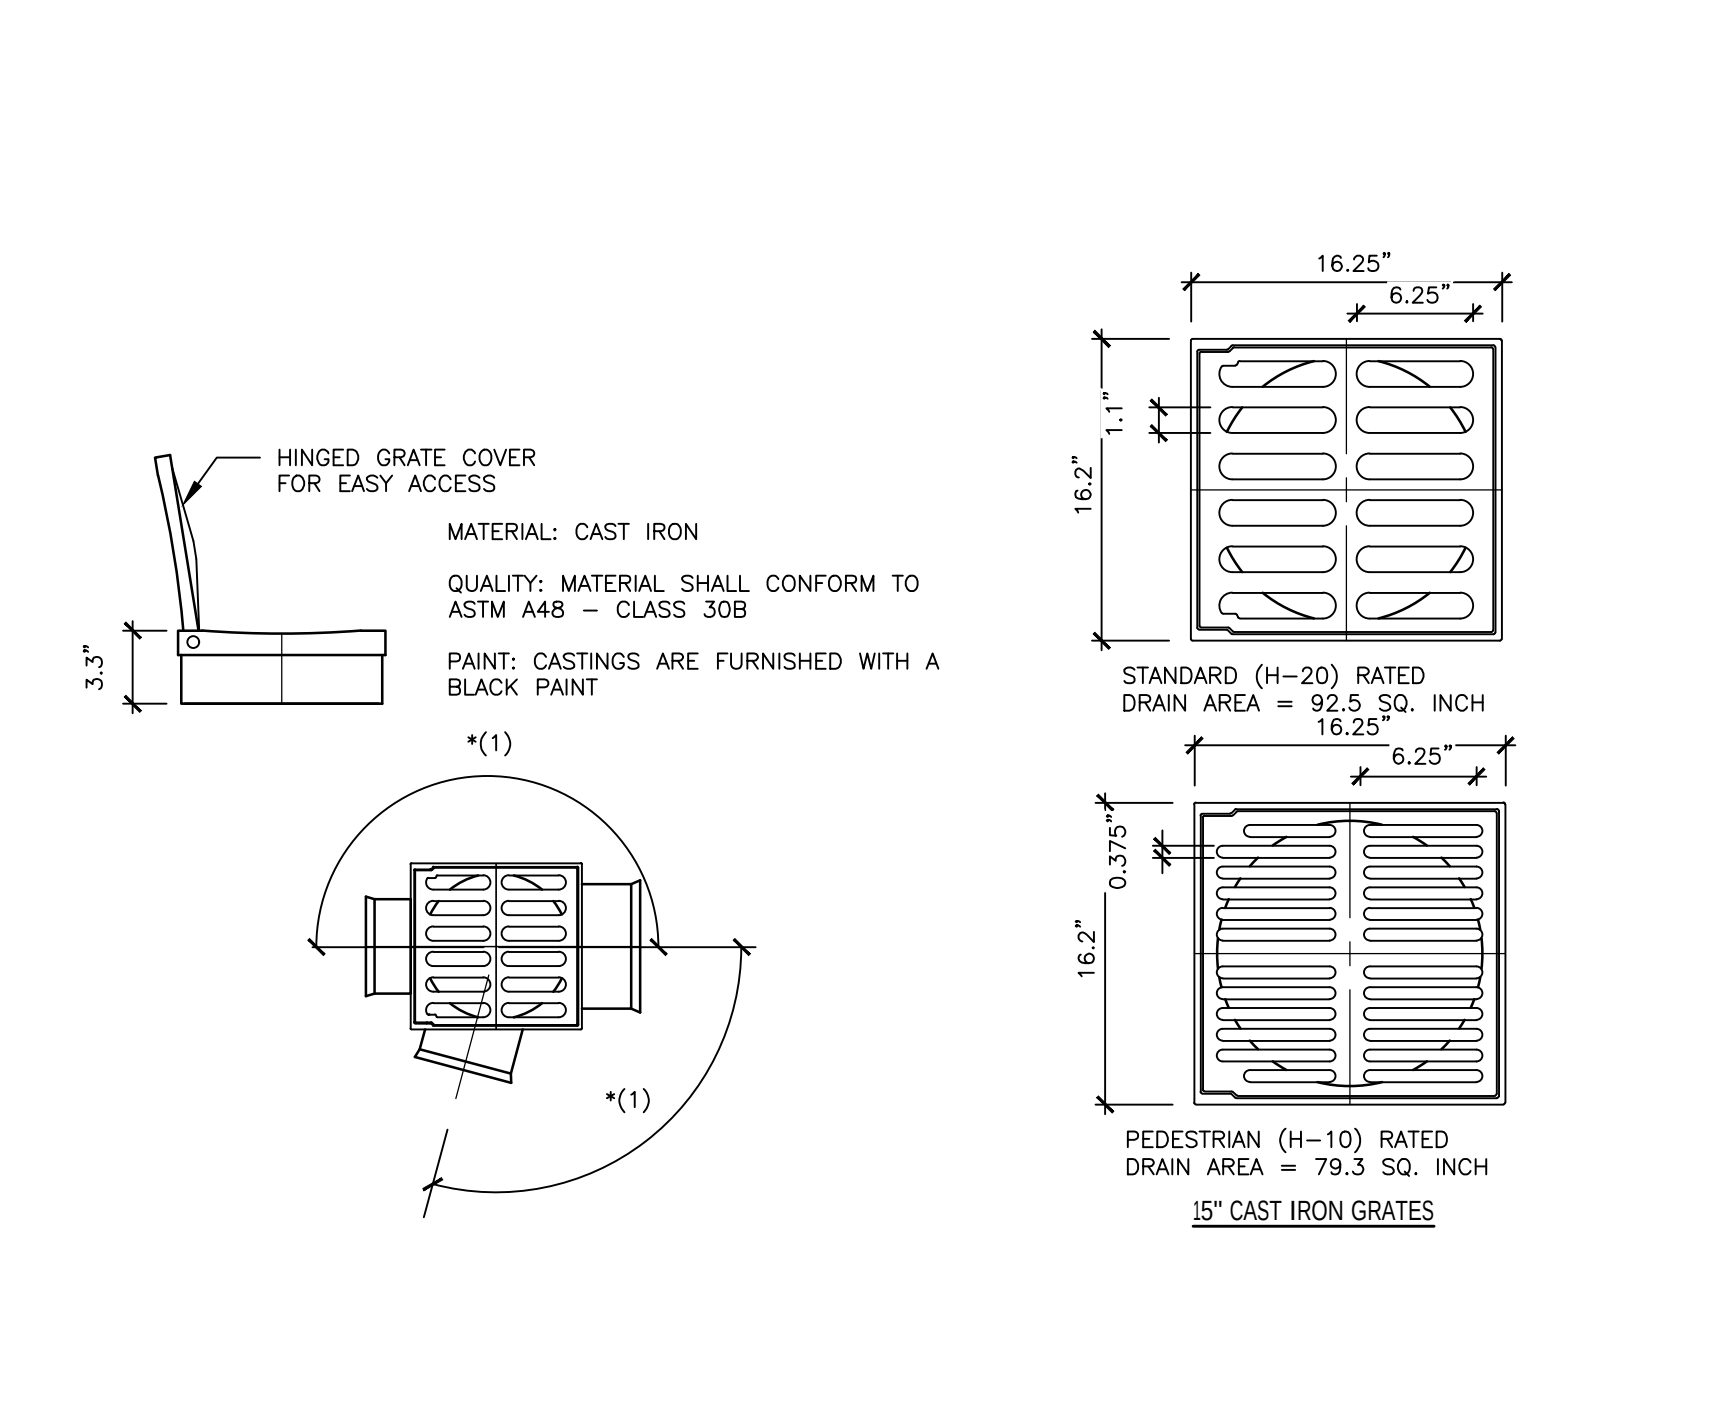


4 FLARED END SECTION

N.T.S.

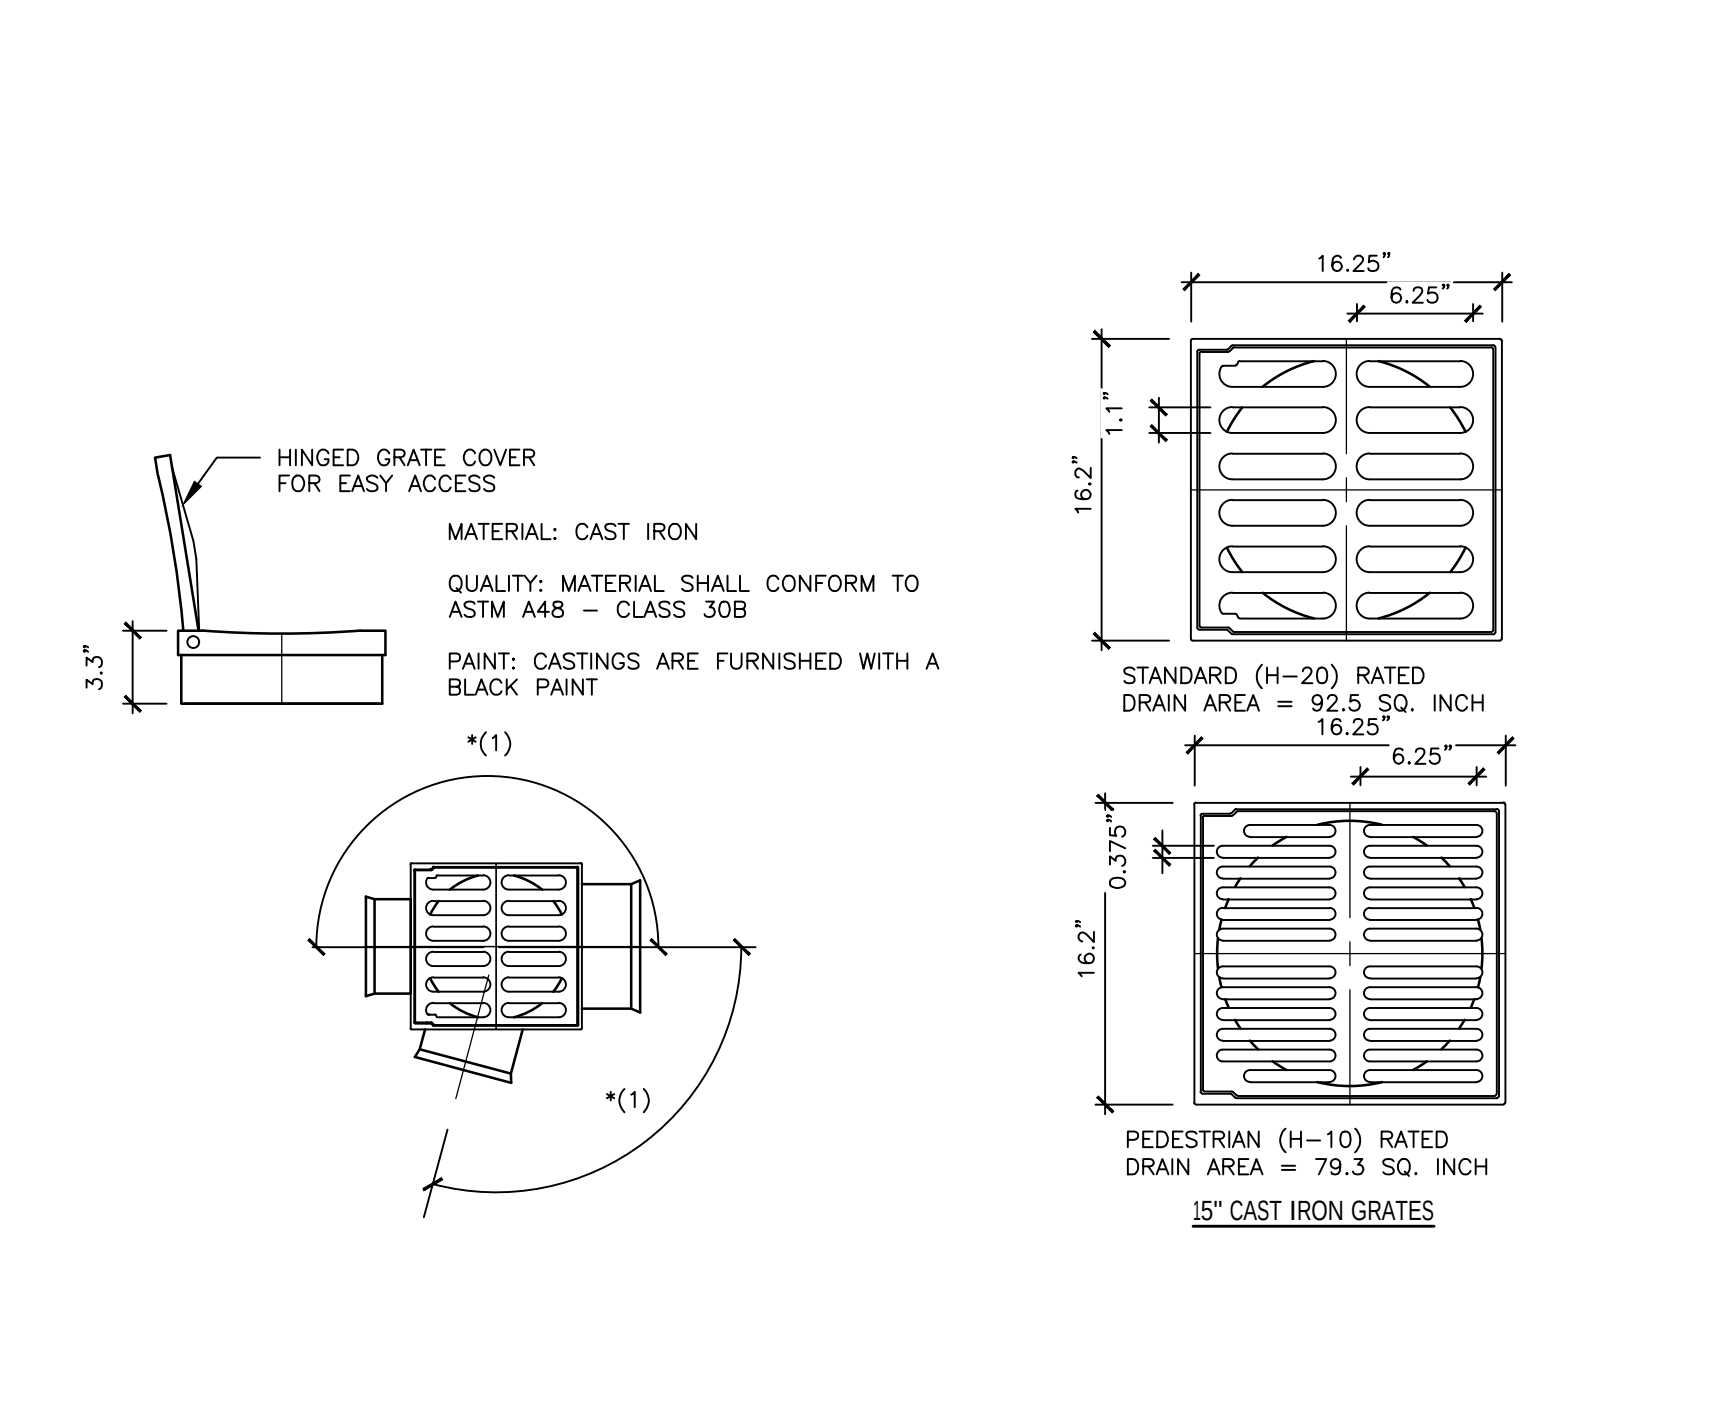


4 FLARED END SECTION

N.T.S.

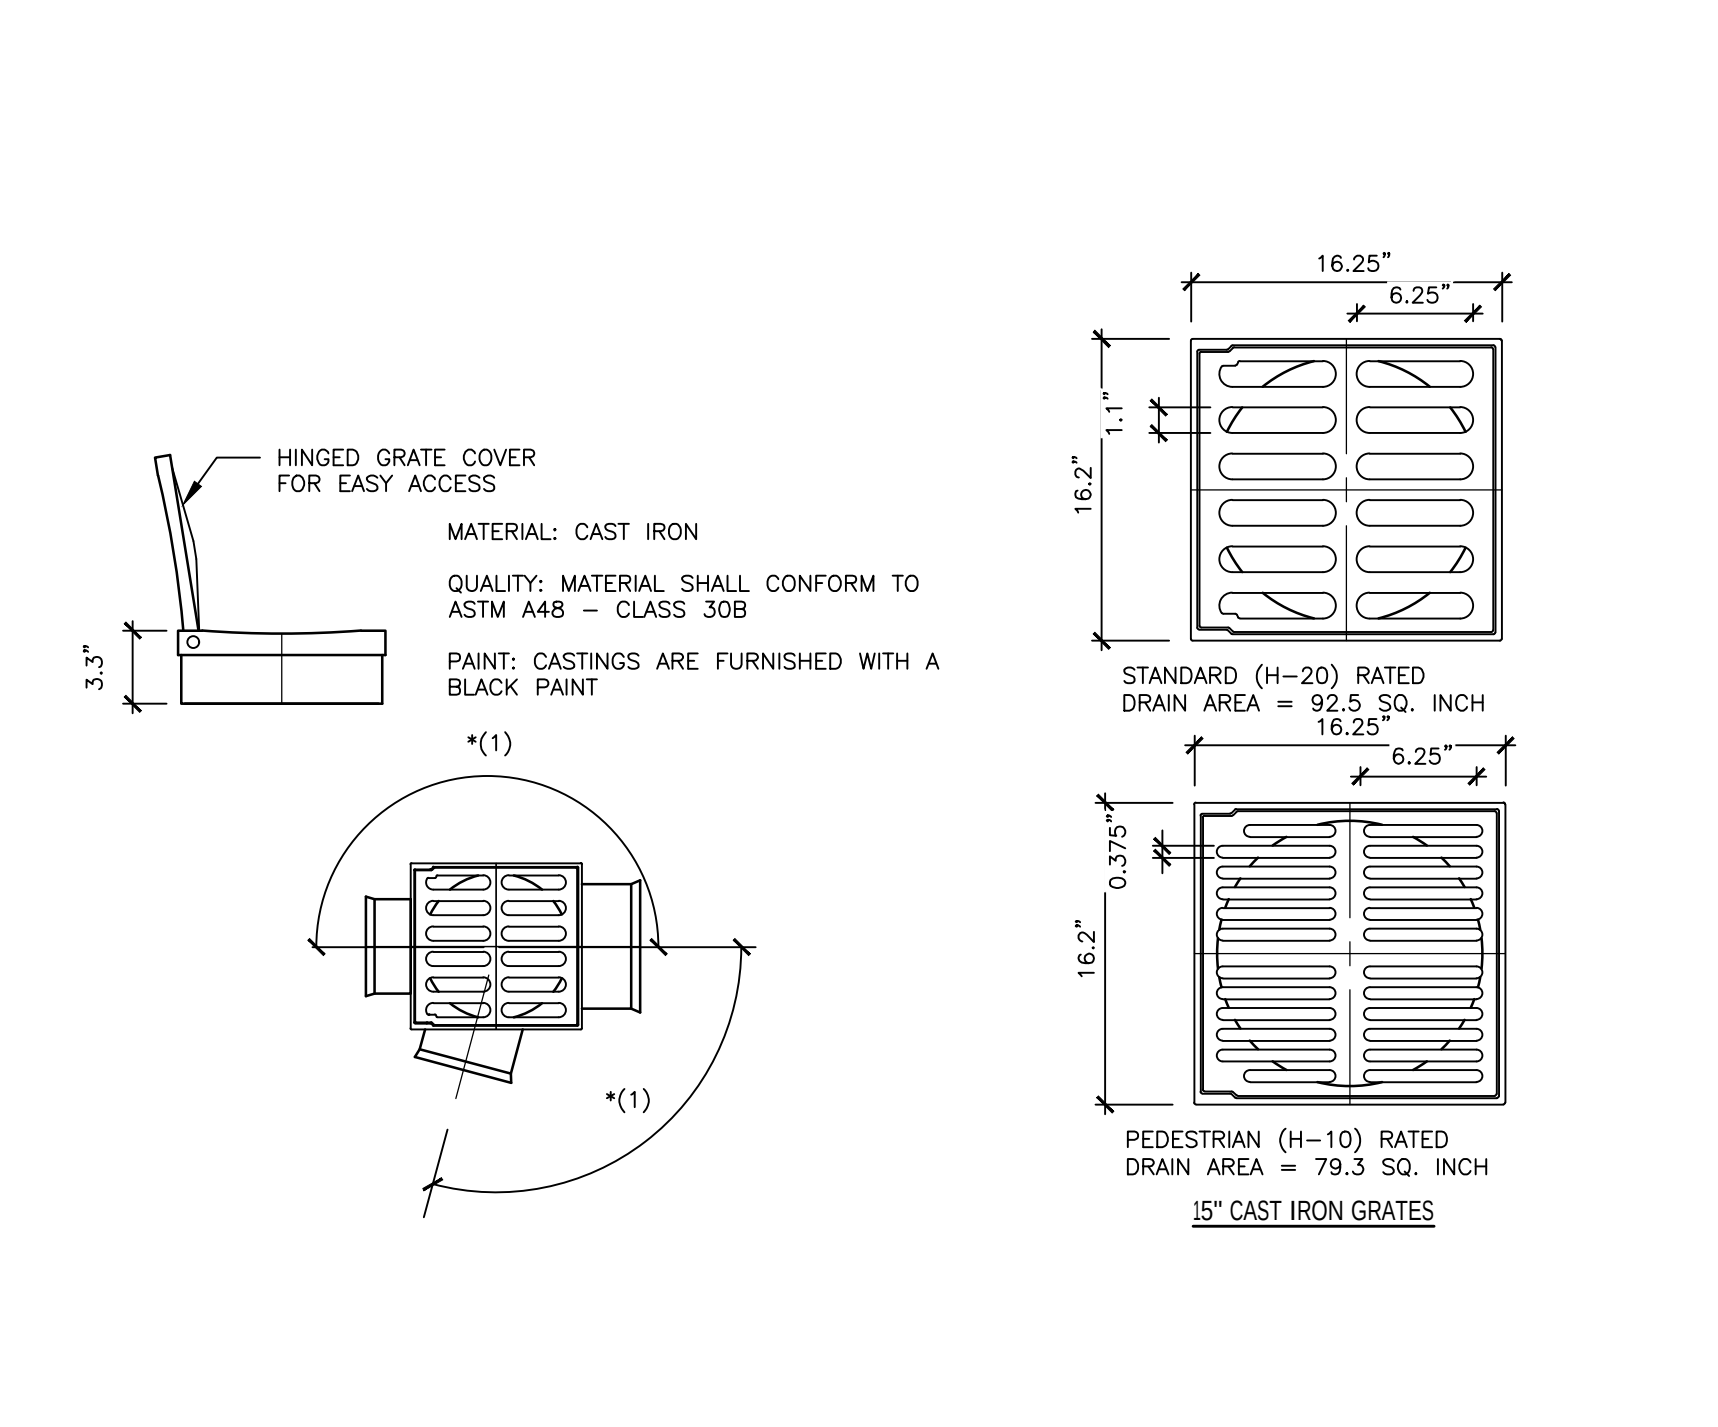


4 FLARED END SECTION

N.T.S.

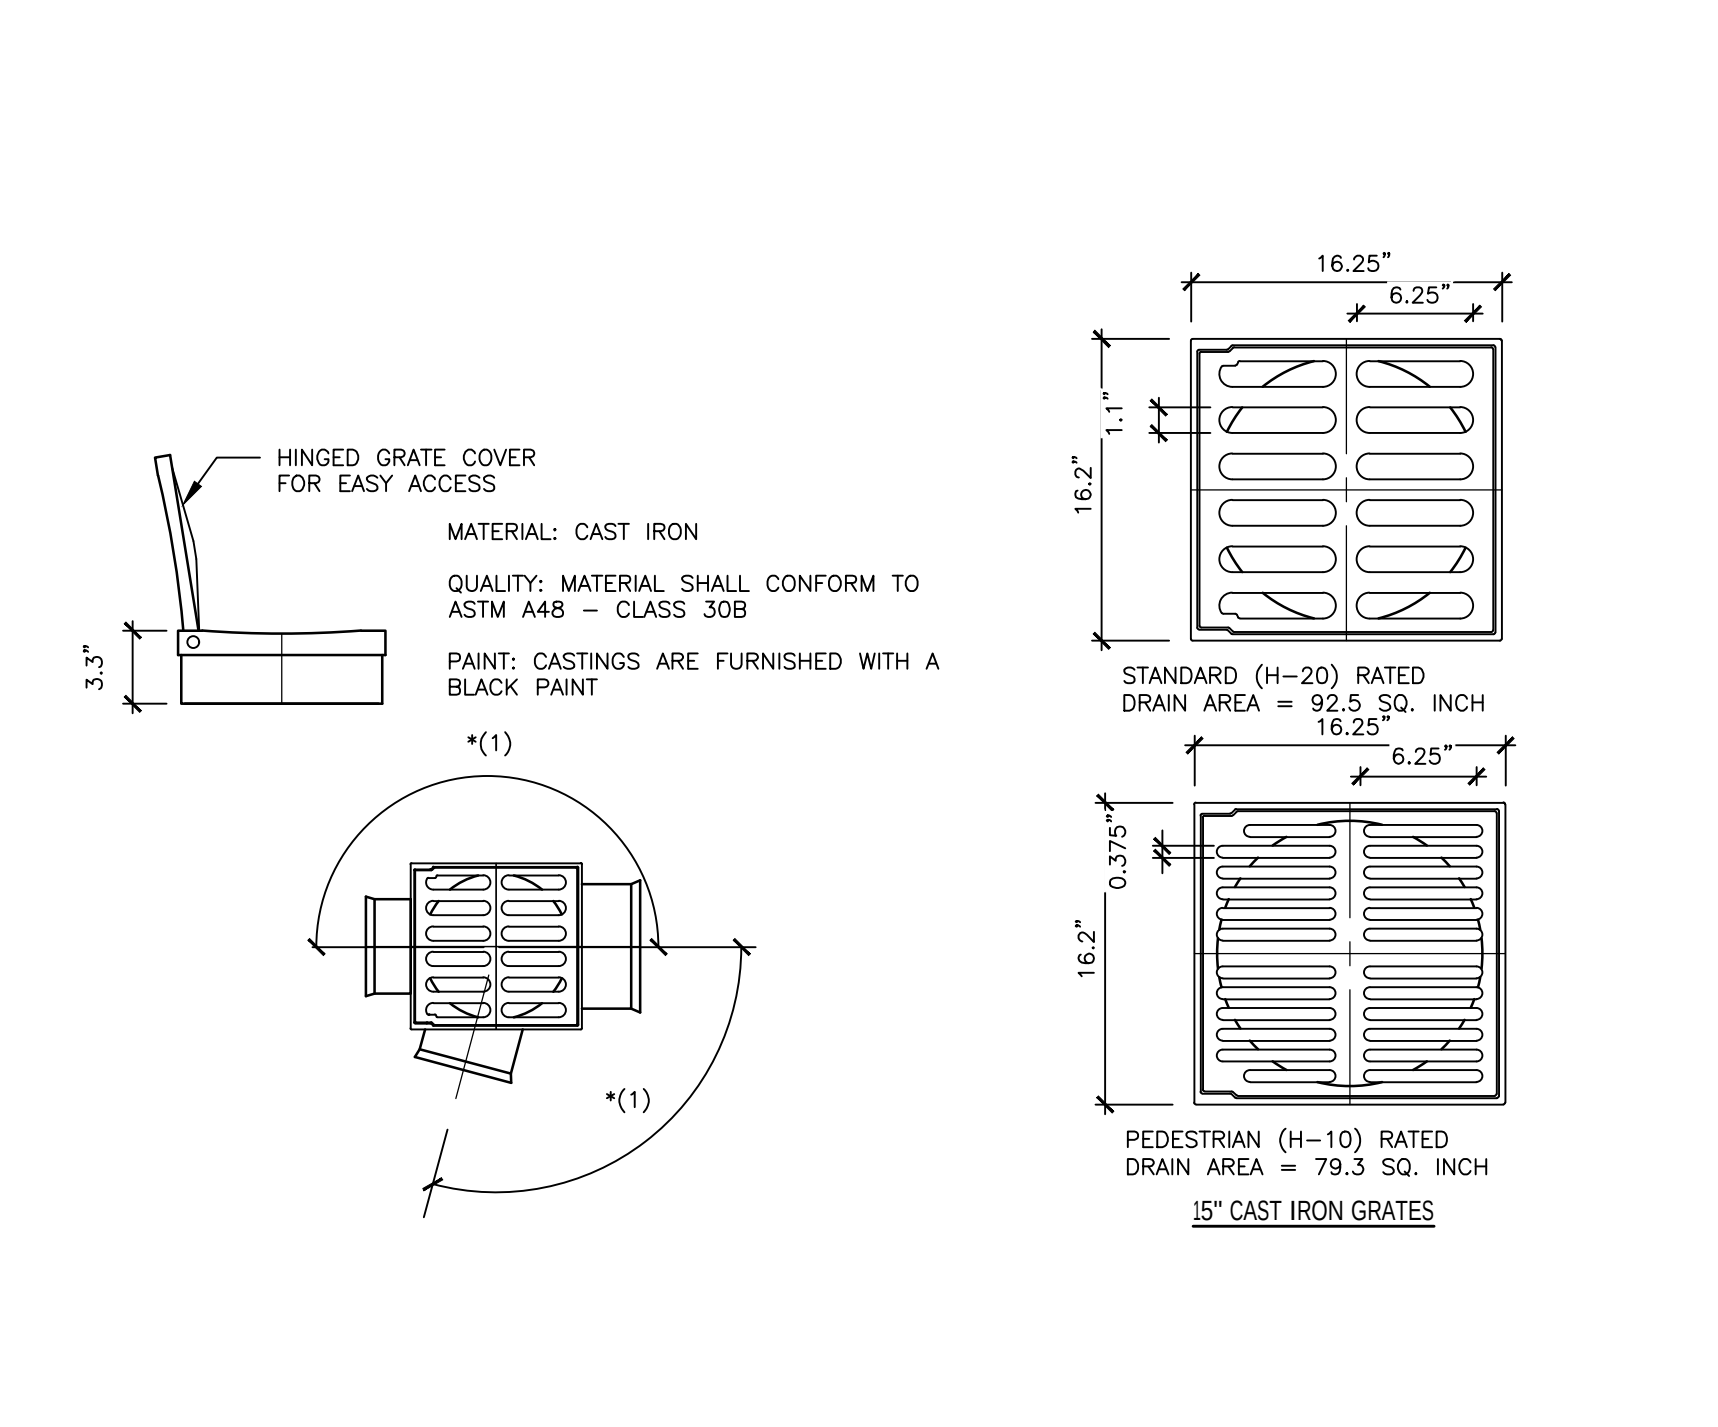


4 FLARED END SECTION

N.T.S.

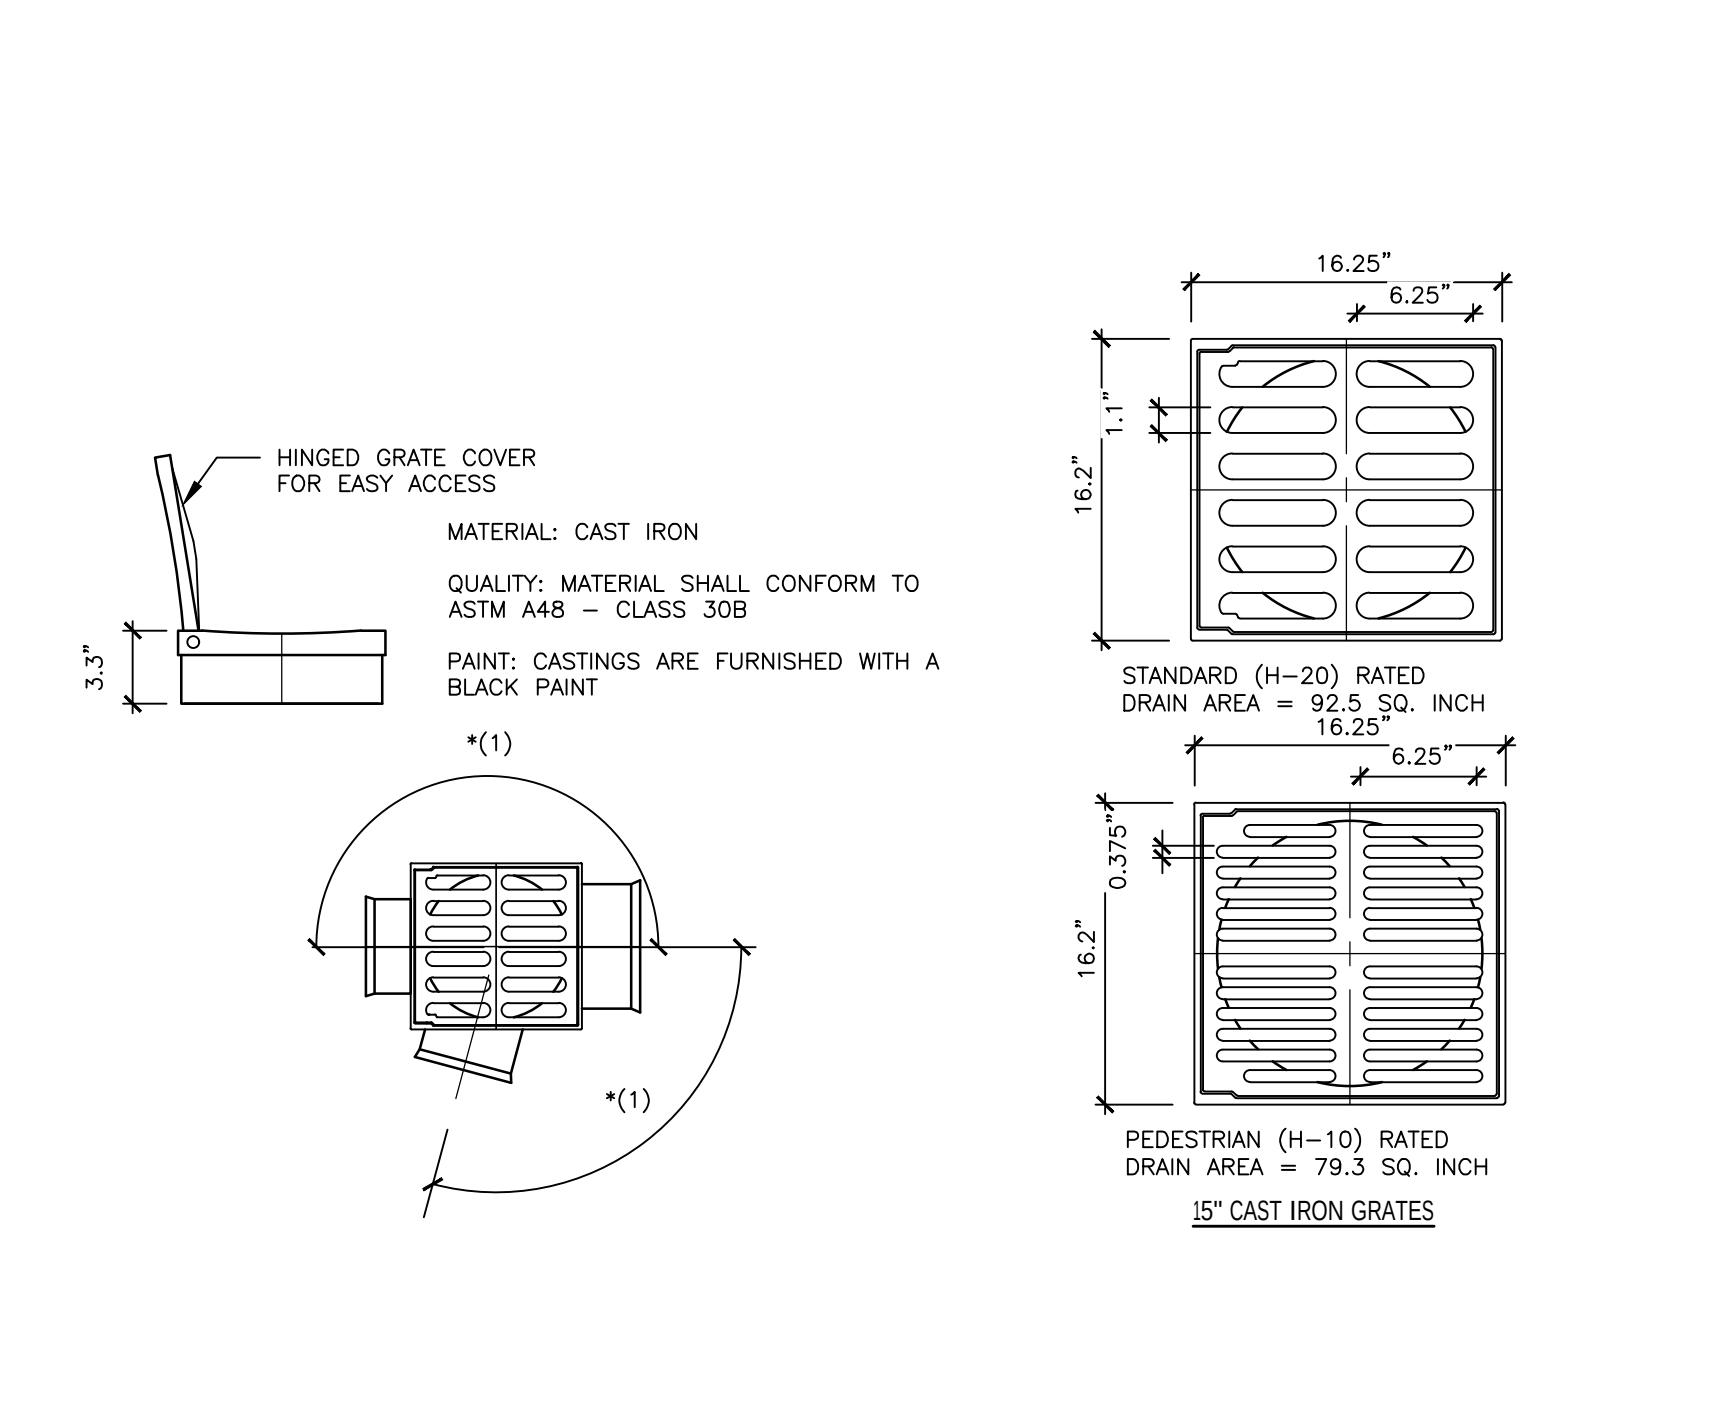


4 FLARED END SECTION

N.T.S.

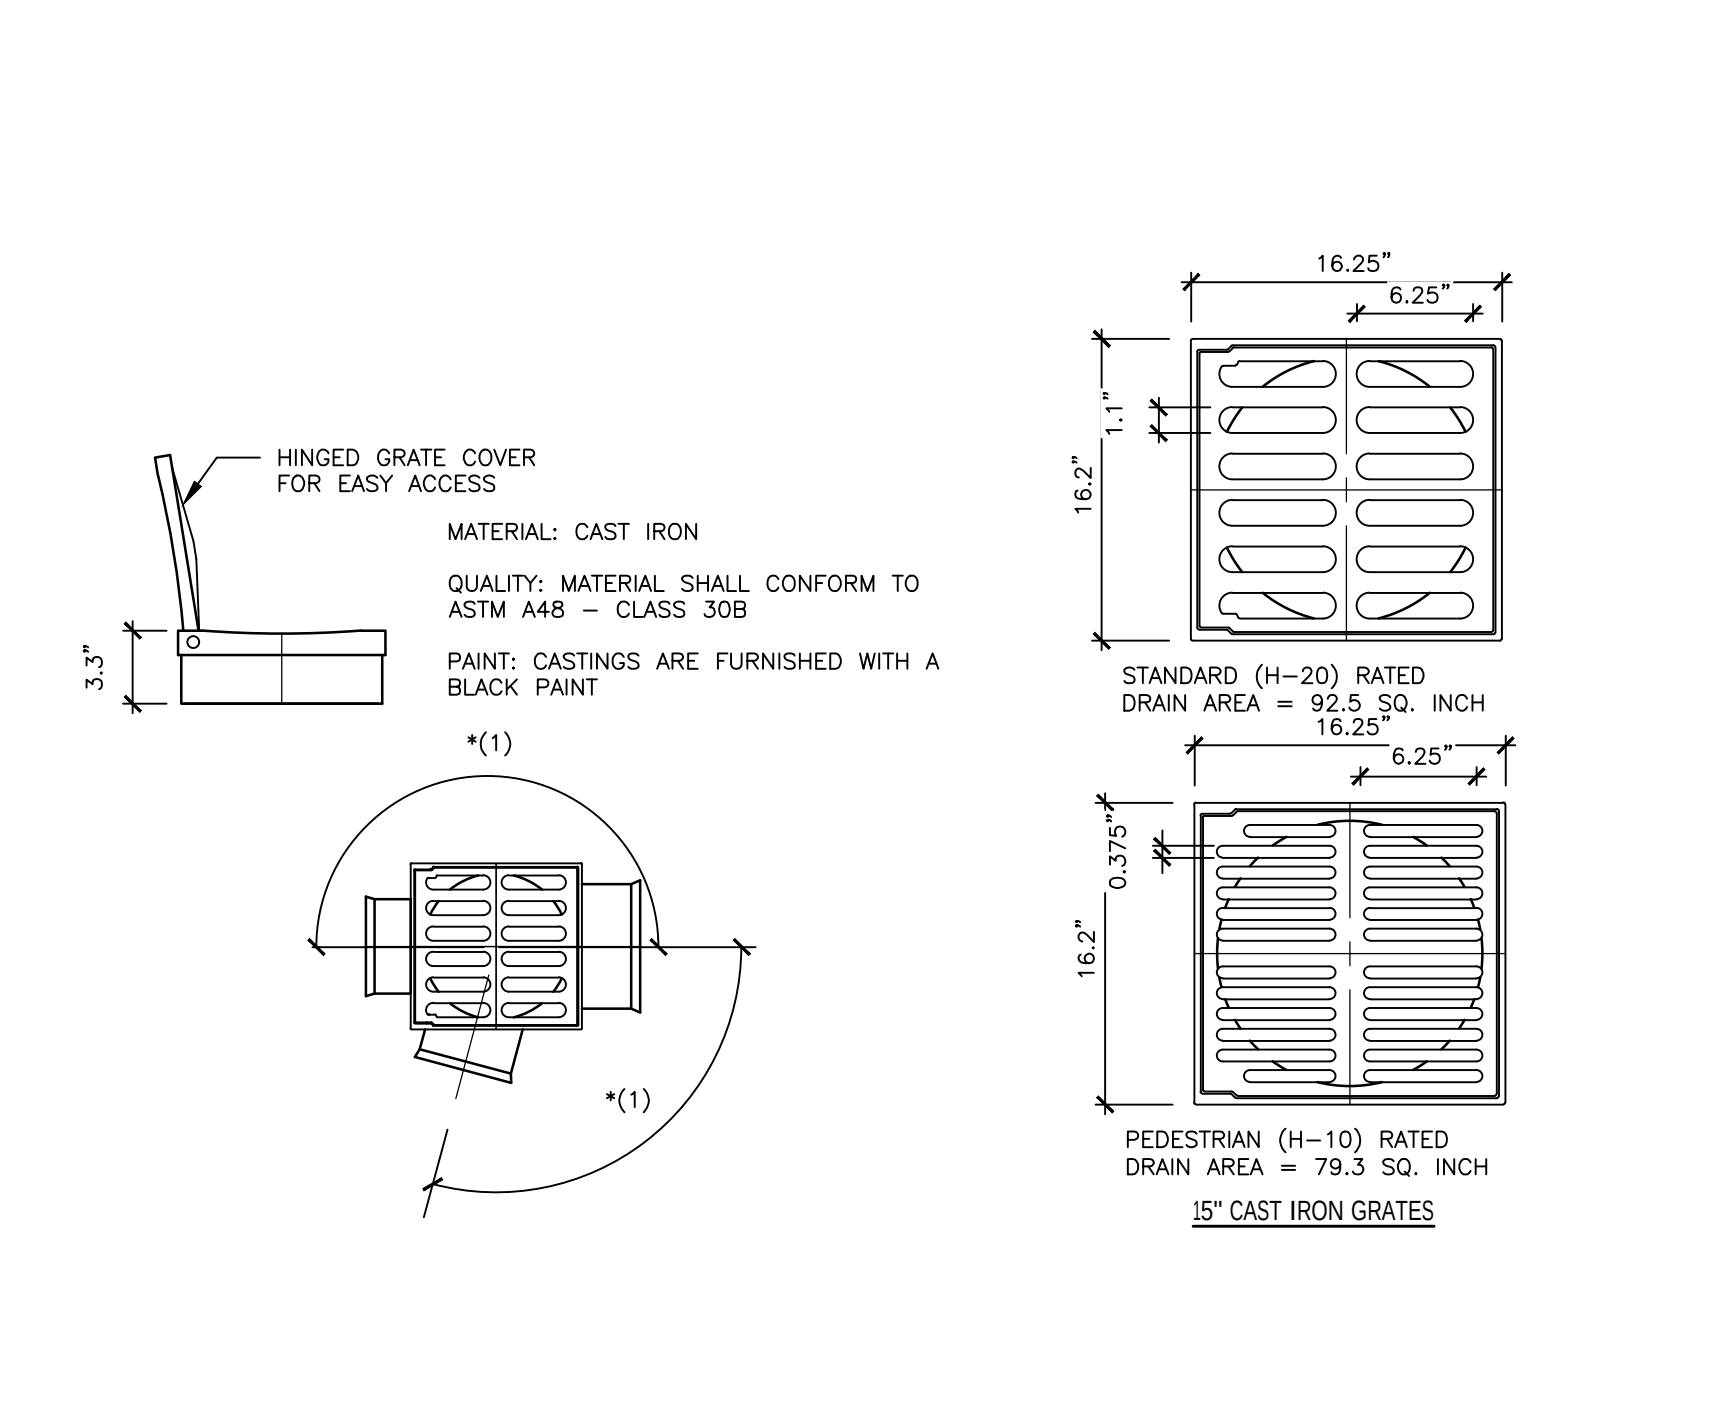


4 FLARED END SECTION

N.T.S.

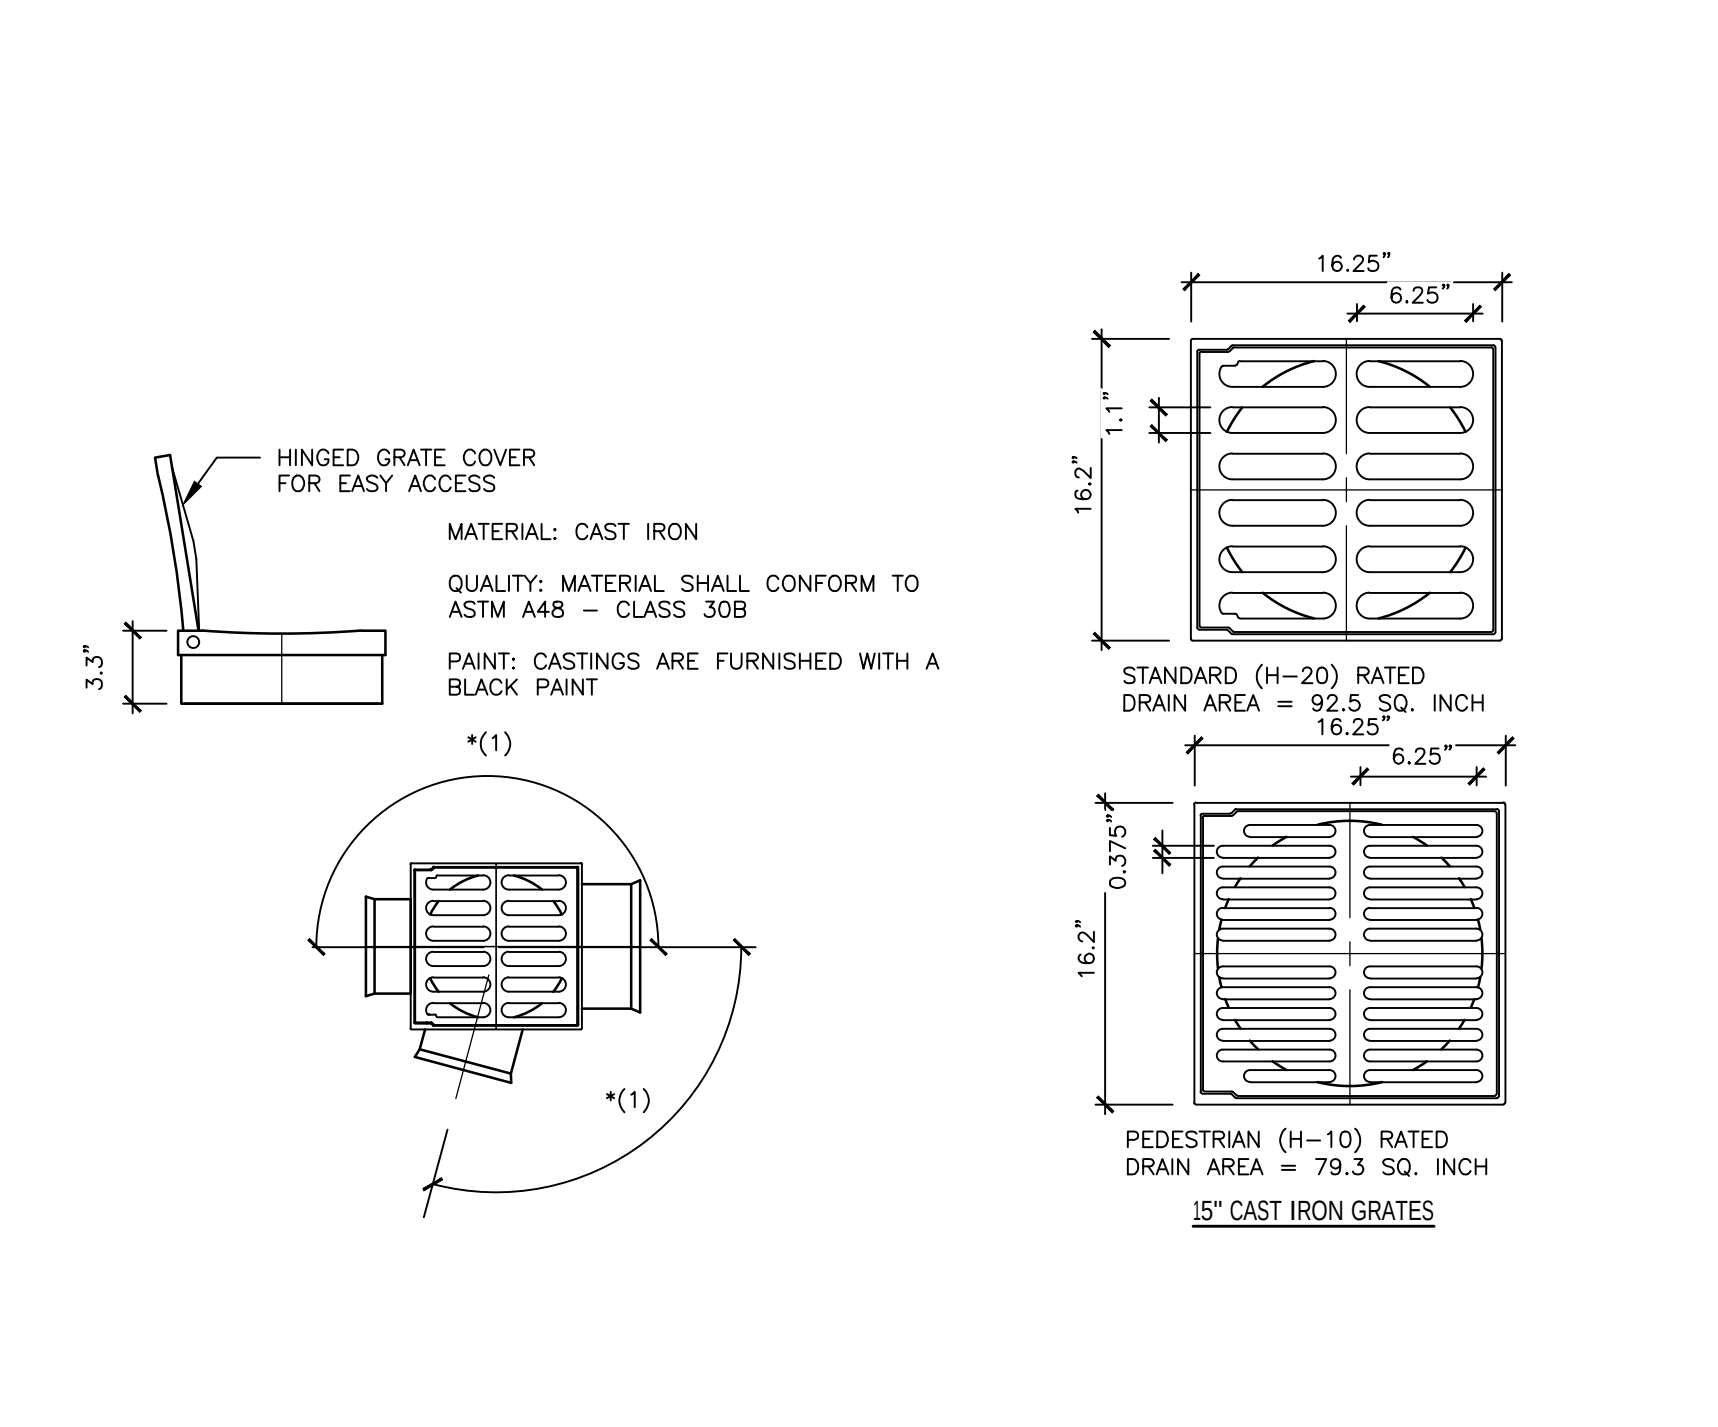


4 FLARED END SECTION

N.T.S.

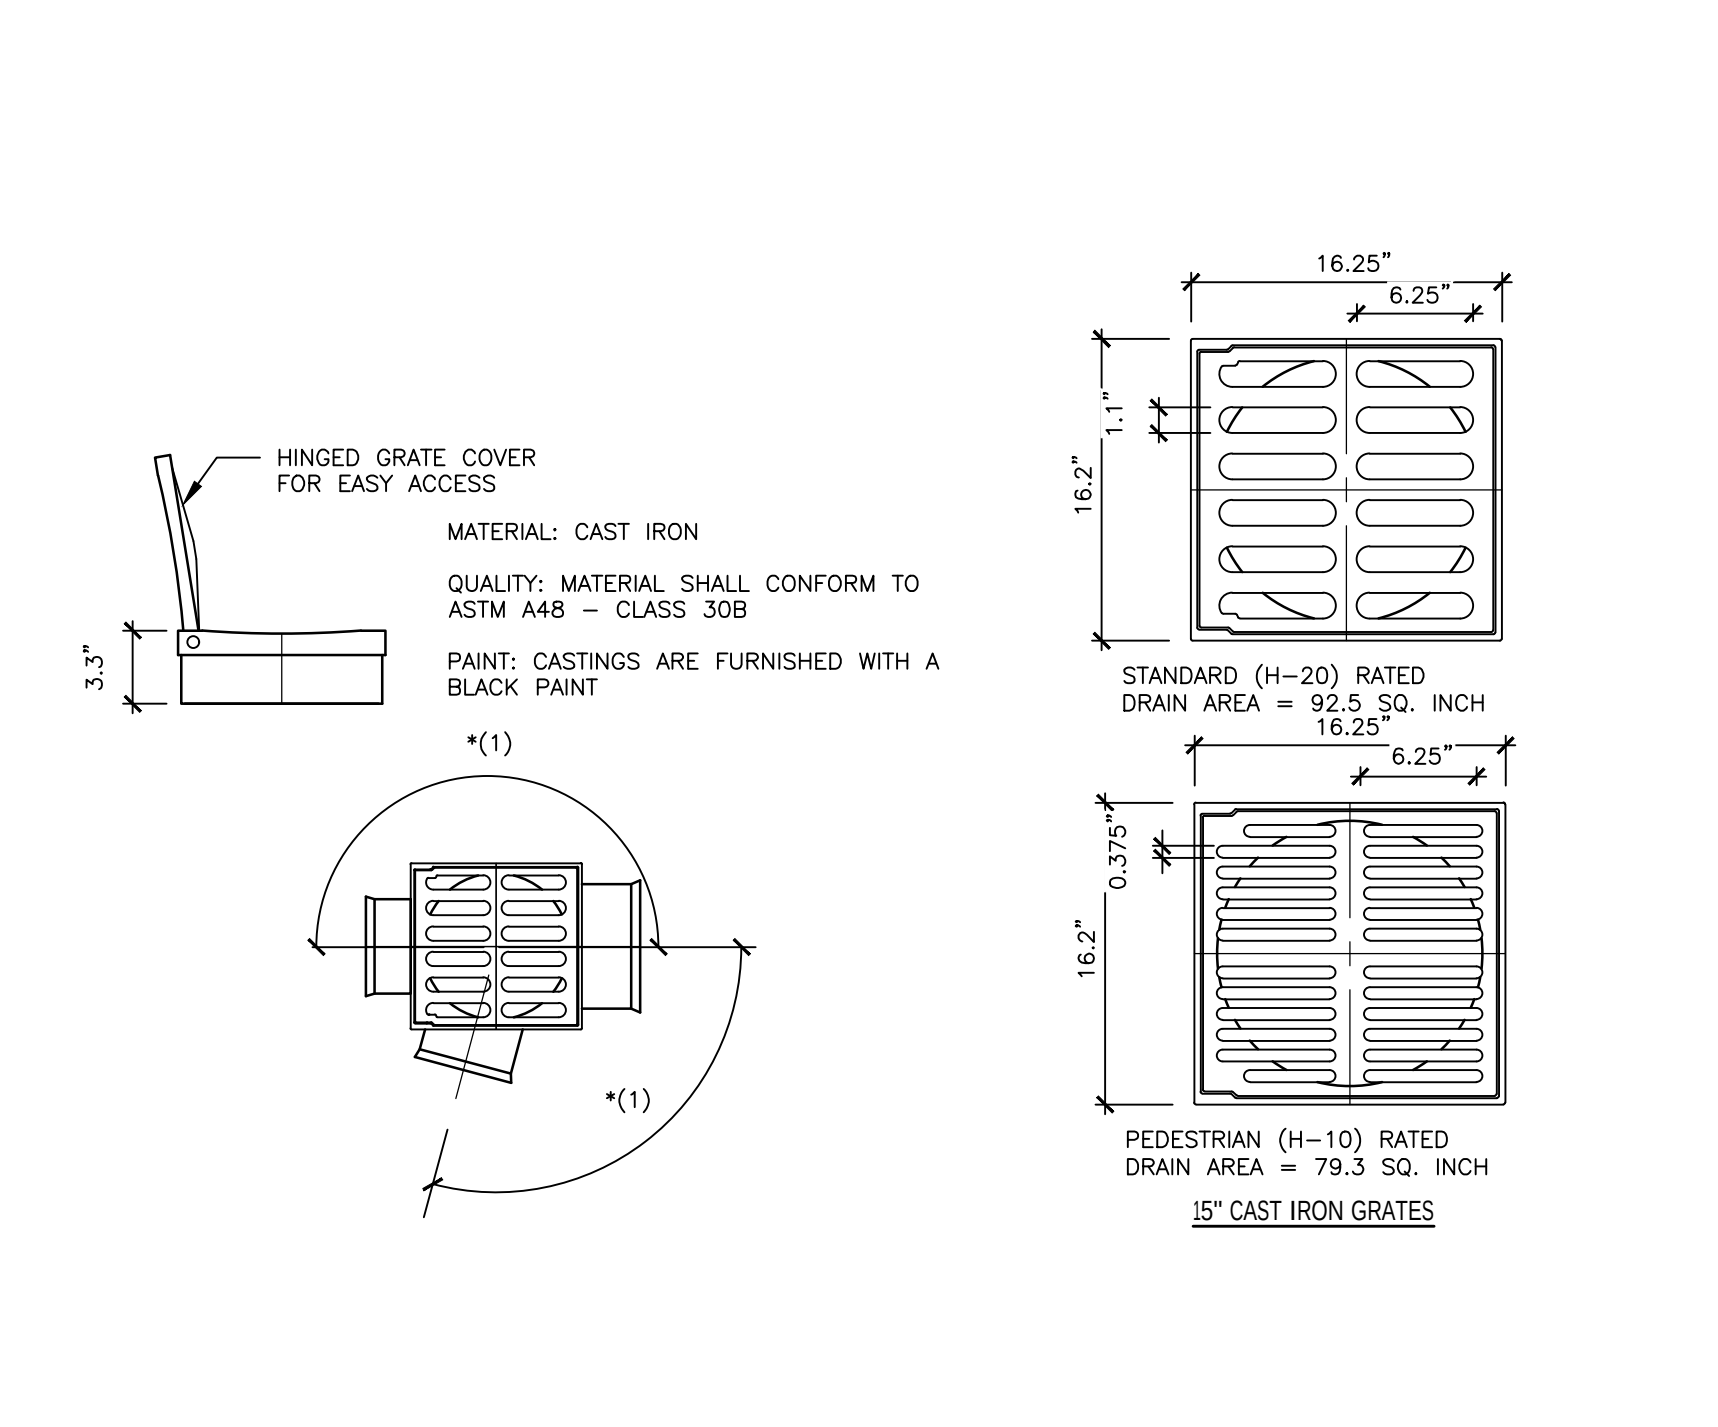


4 FLARED END SECTION

N.T.S.

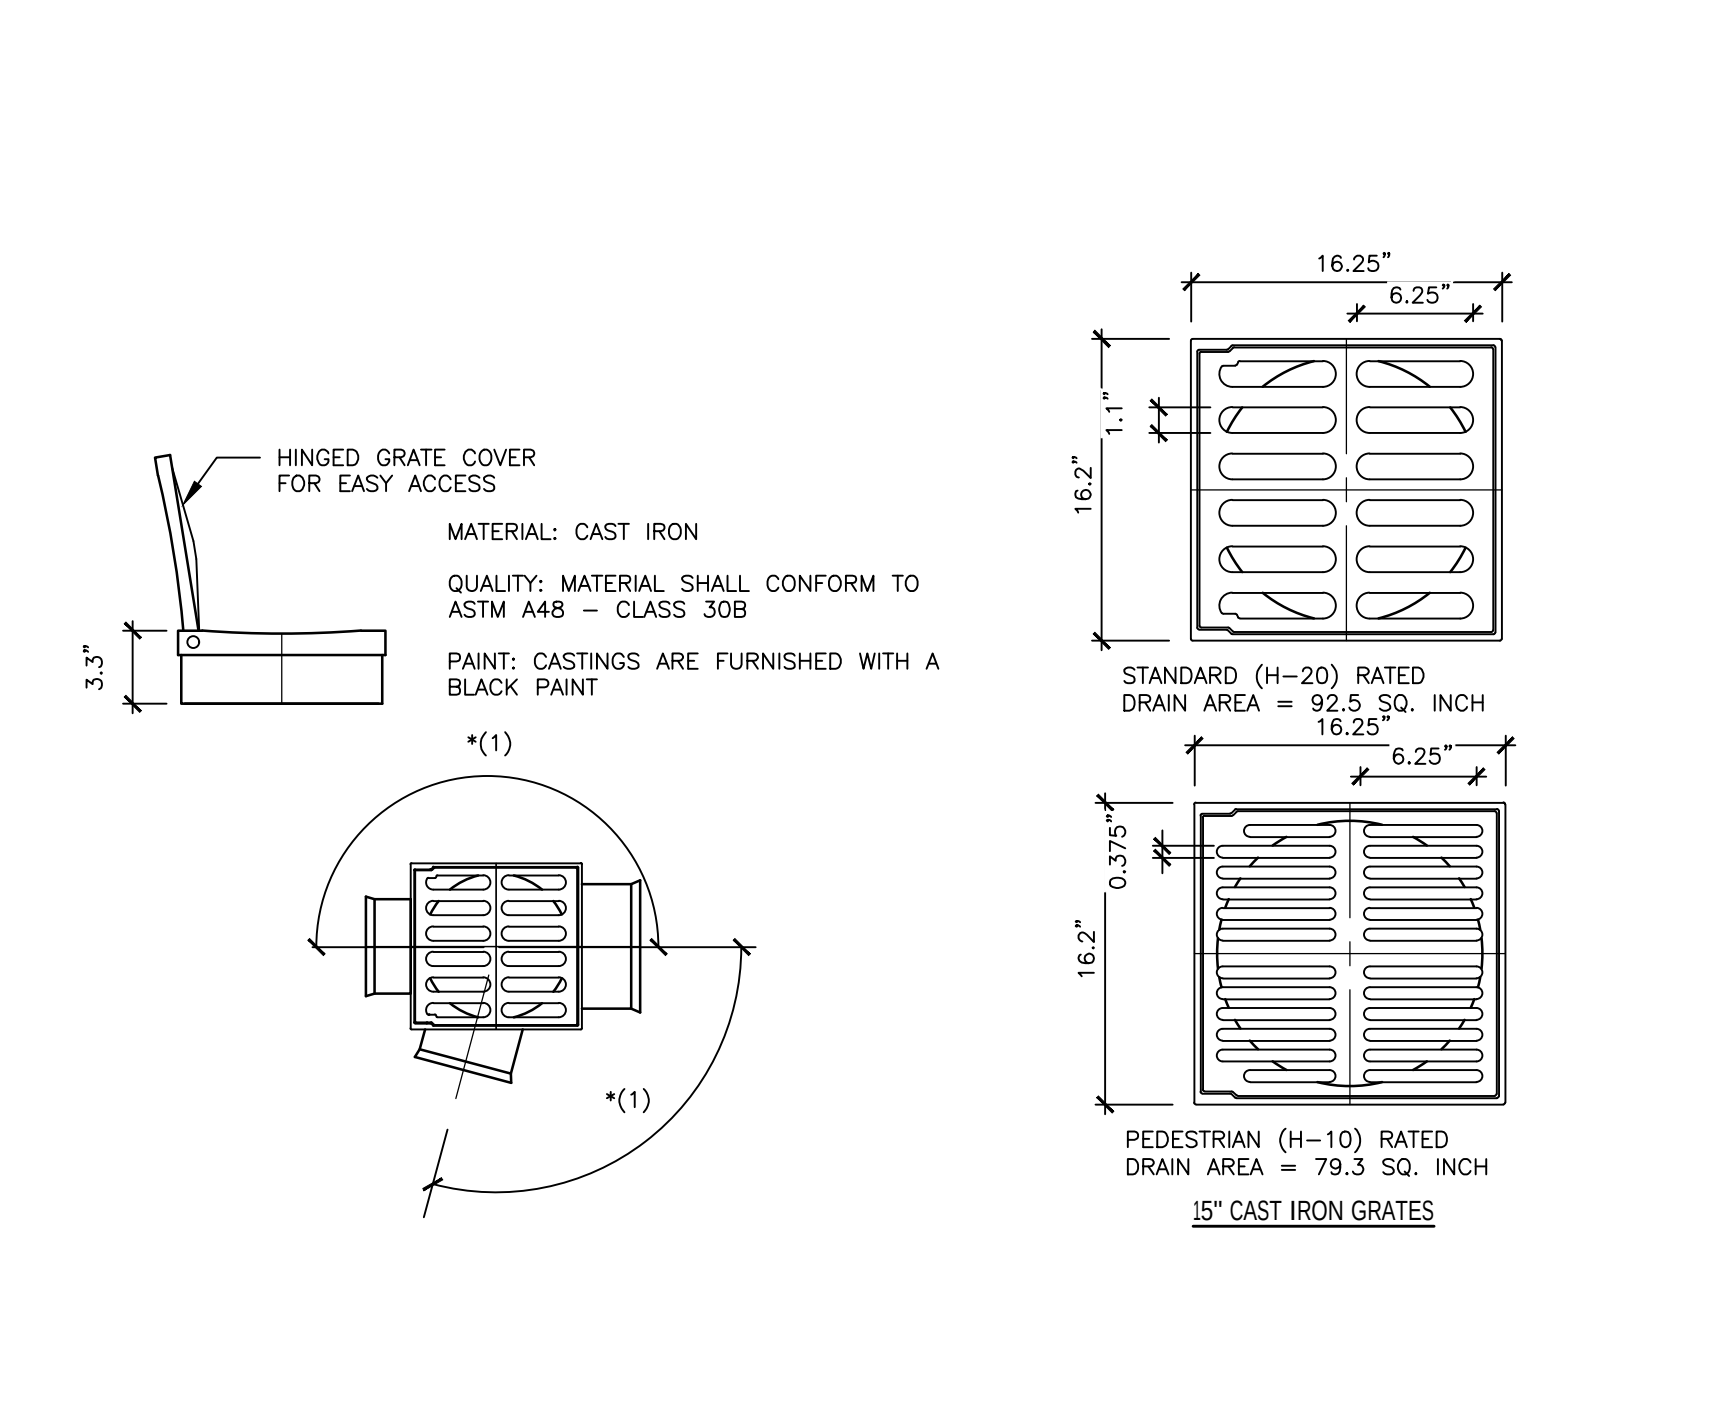


4 FLARED END SECTION


N.T.S.

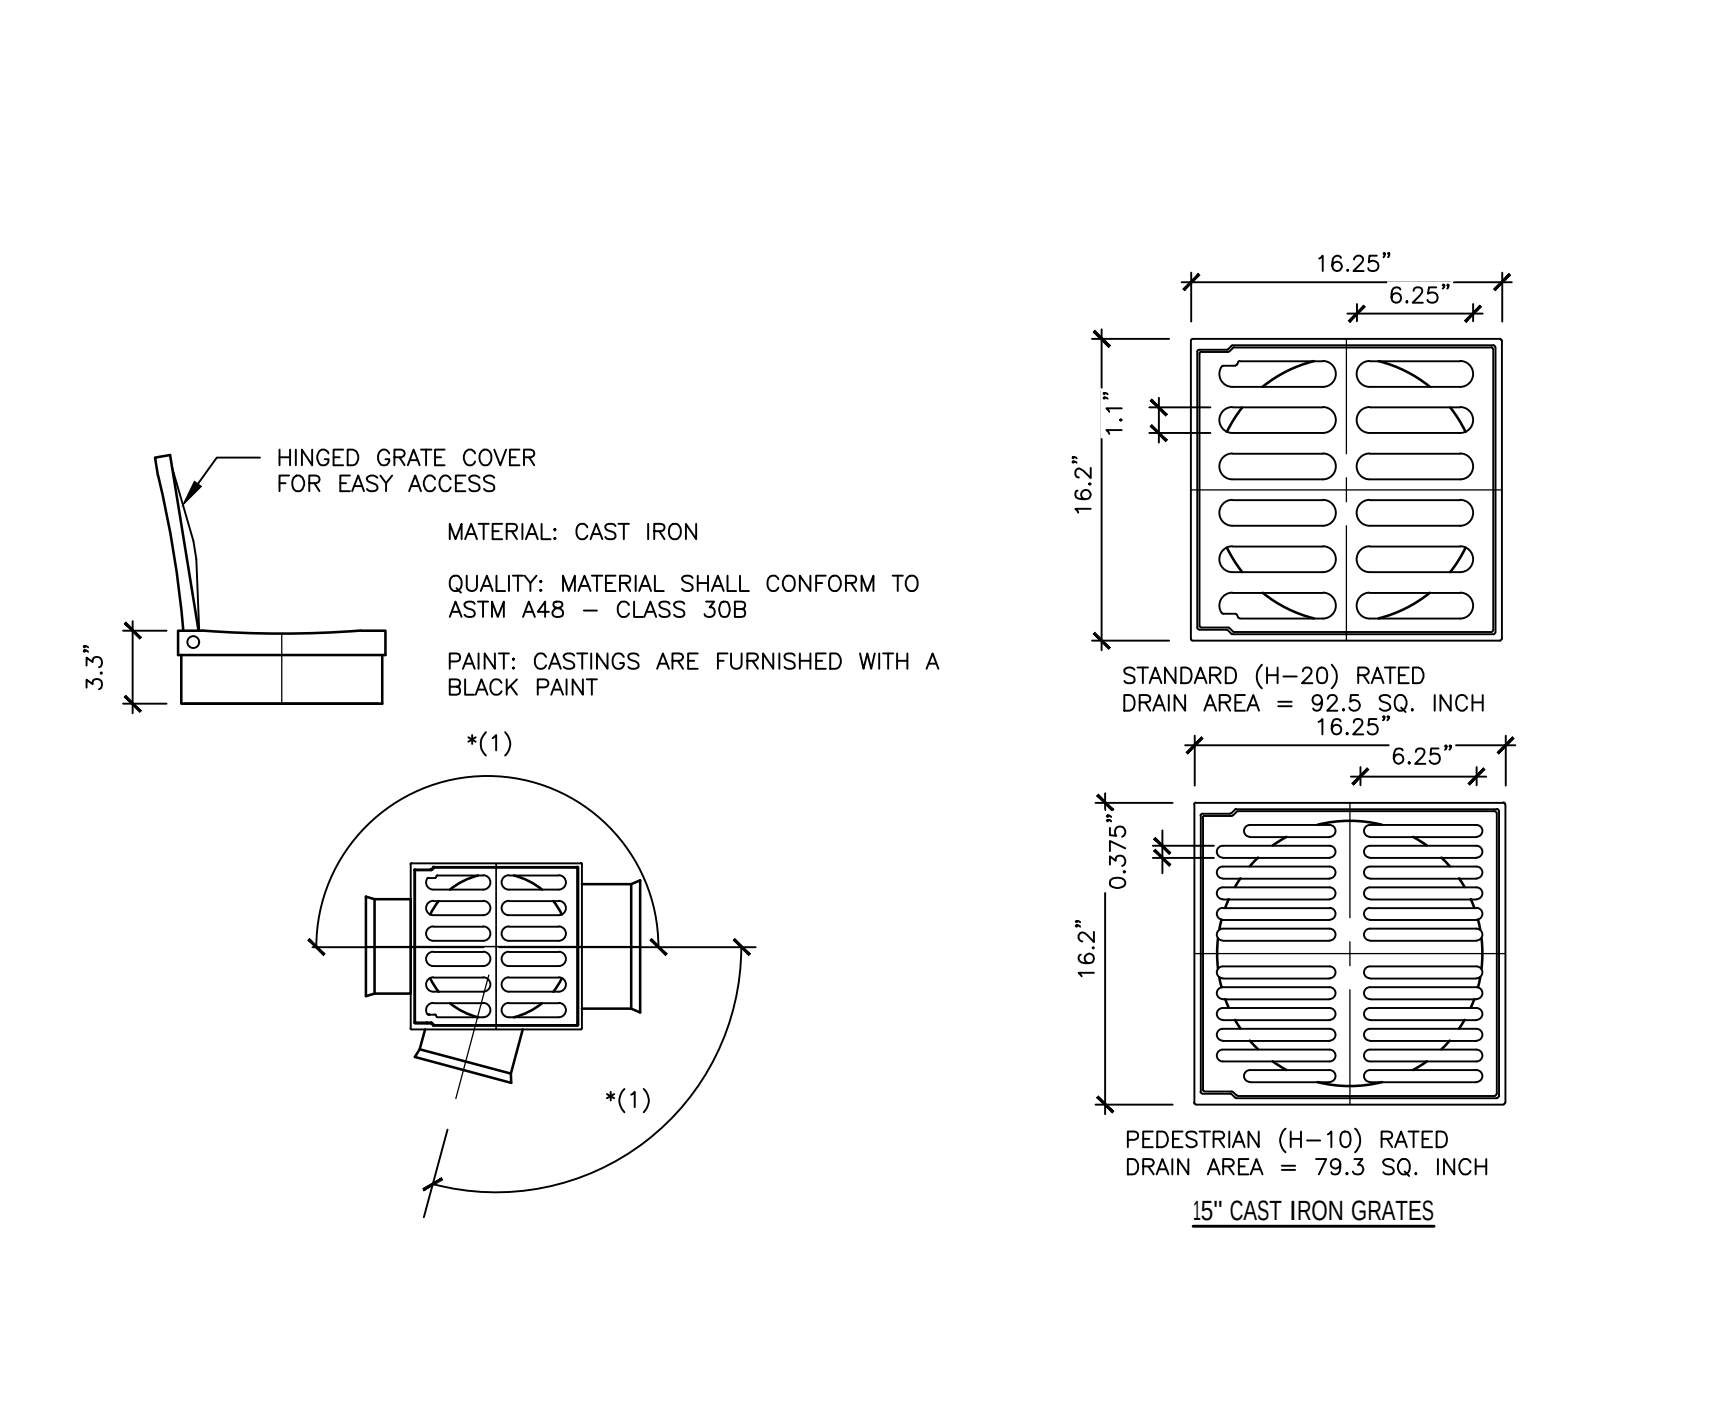


4 FLARED END SECTION


N.T.S.

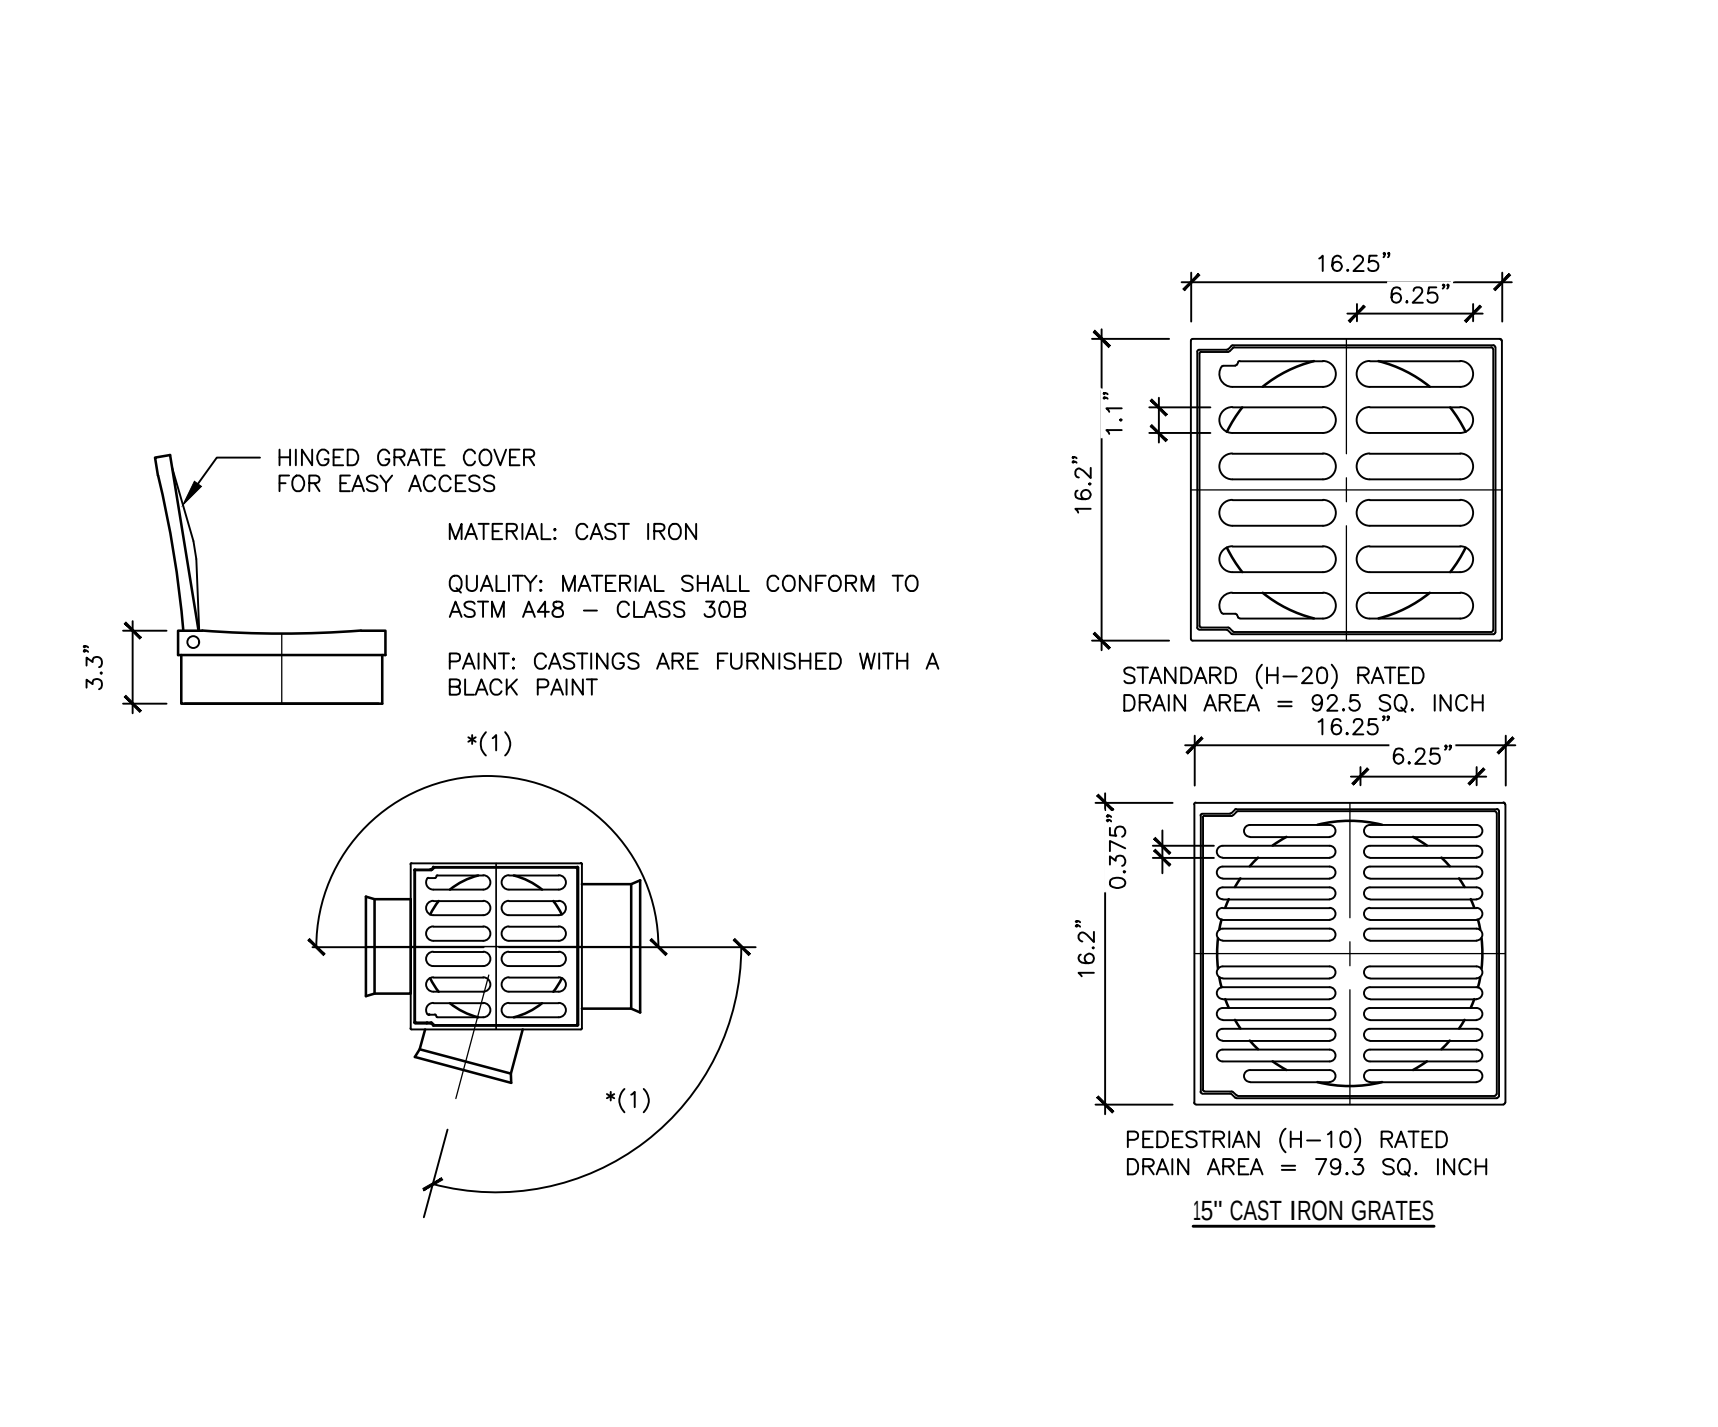

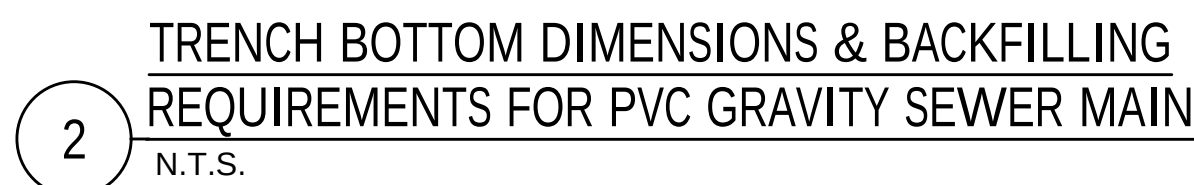


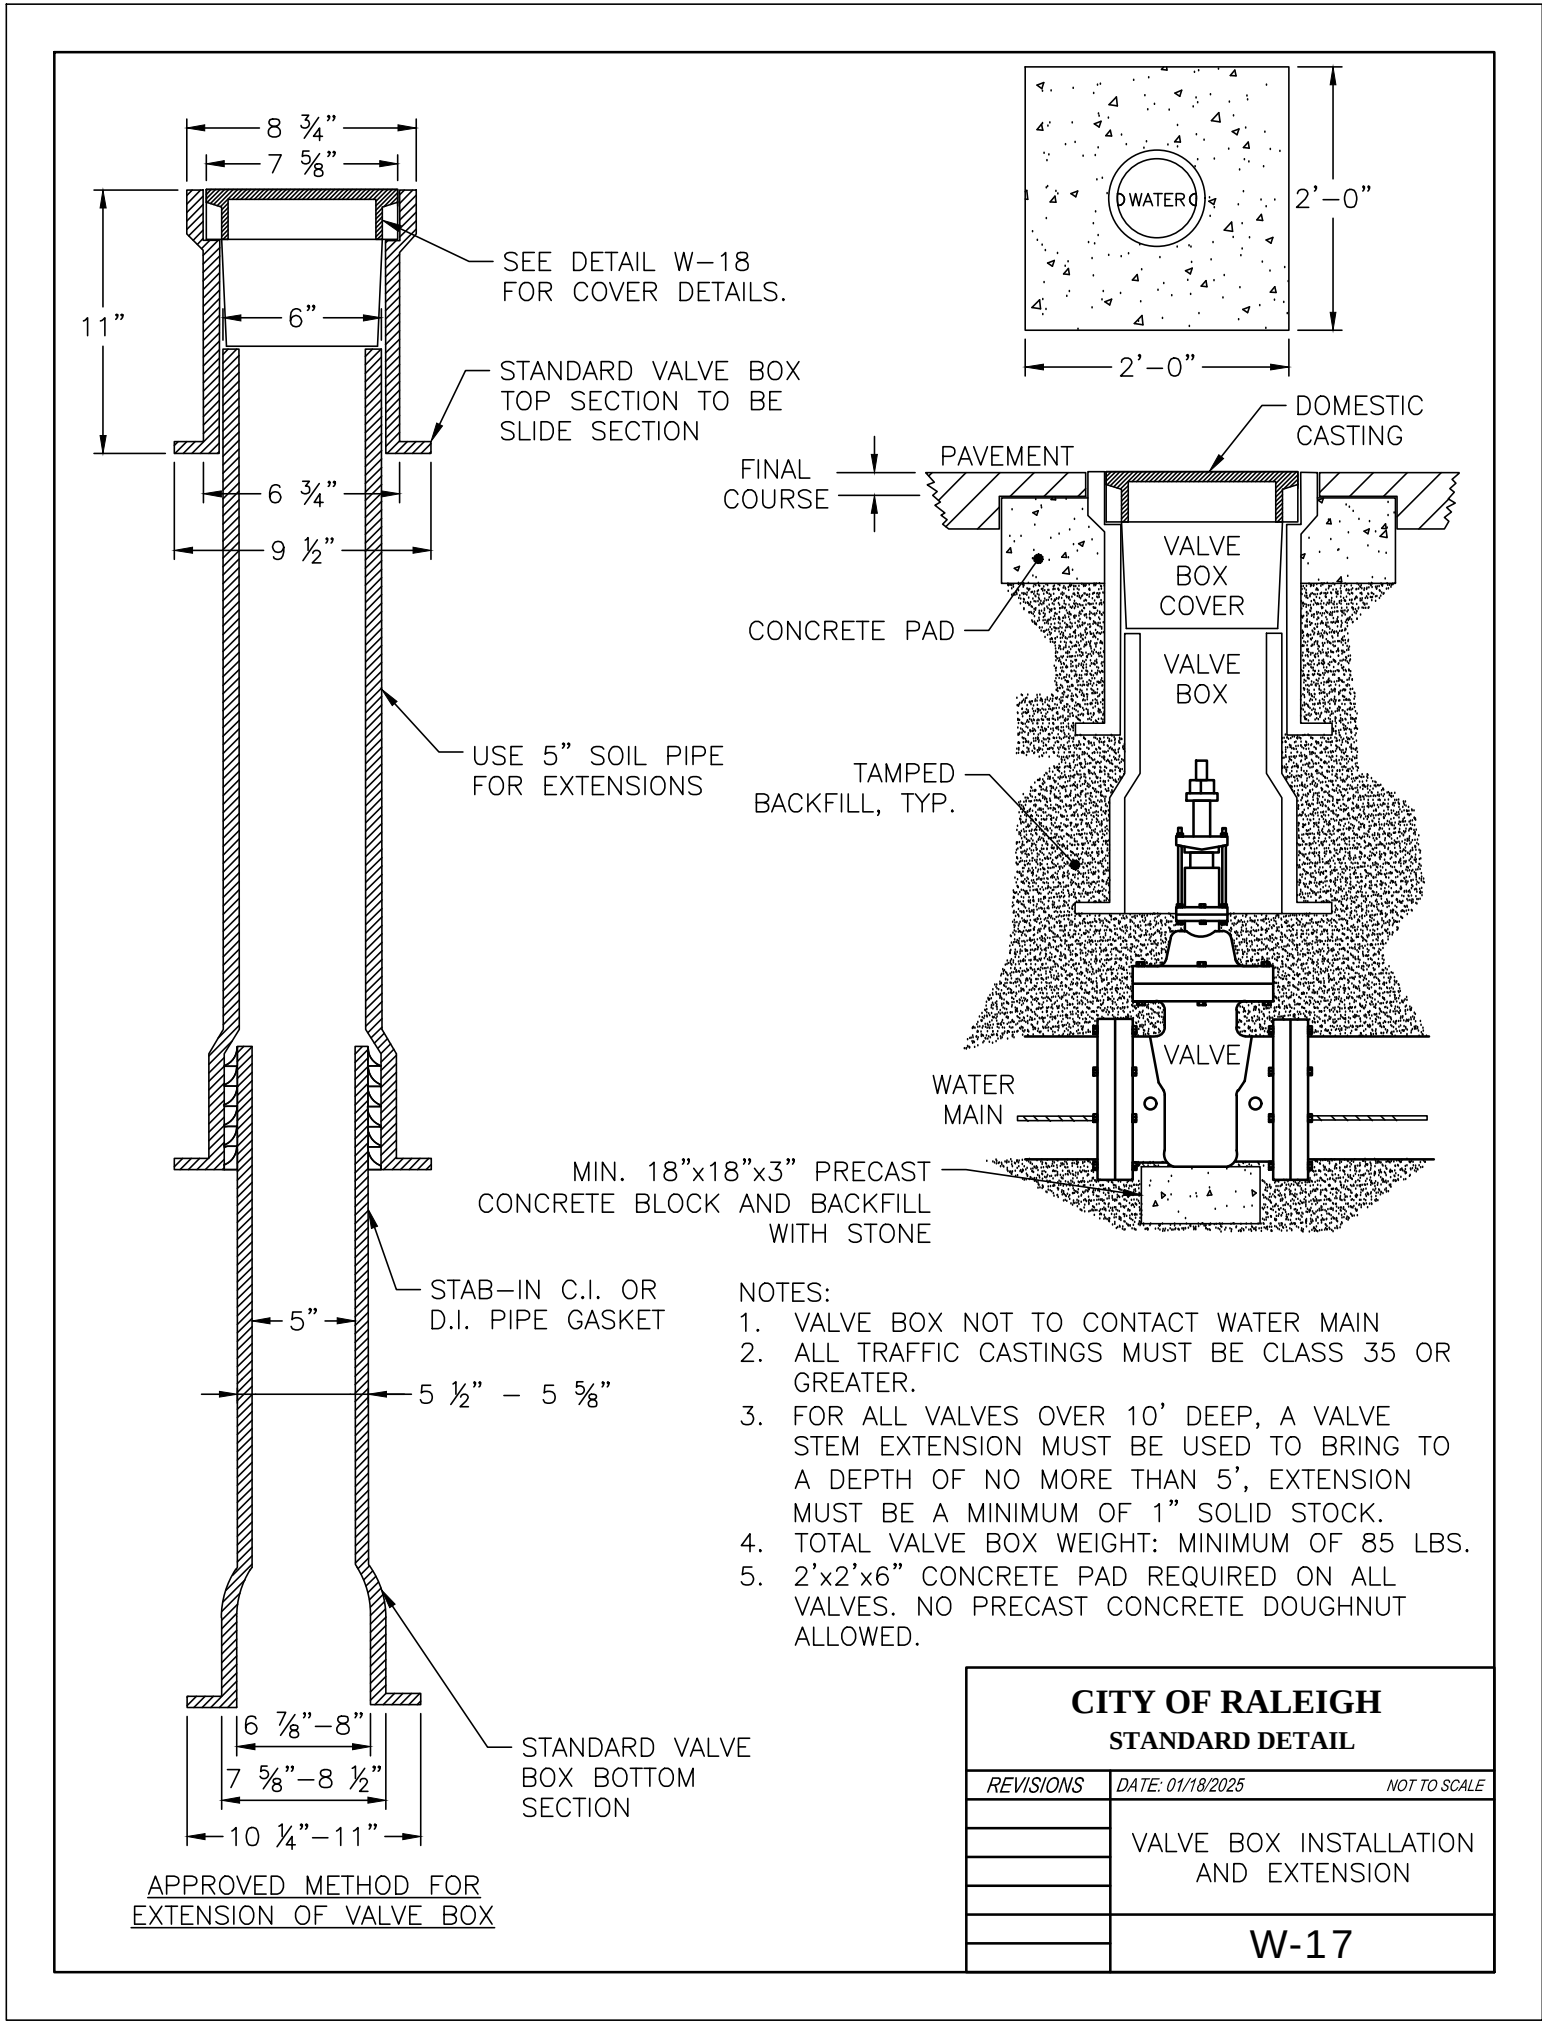


1 VALVE BOX INSTALLATION AND EXTENSION
N.T.S.

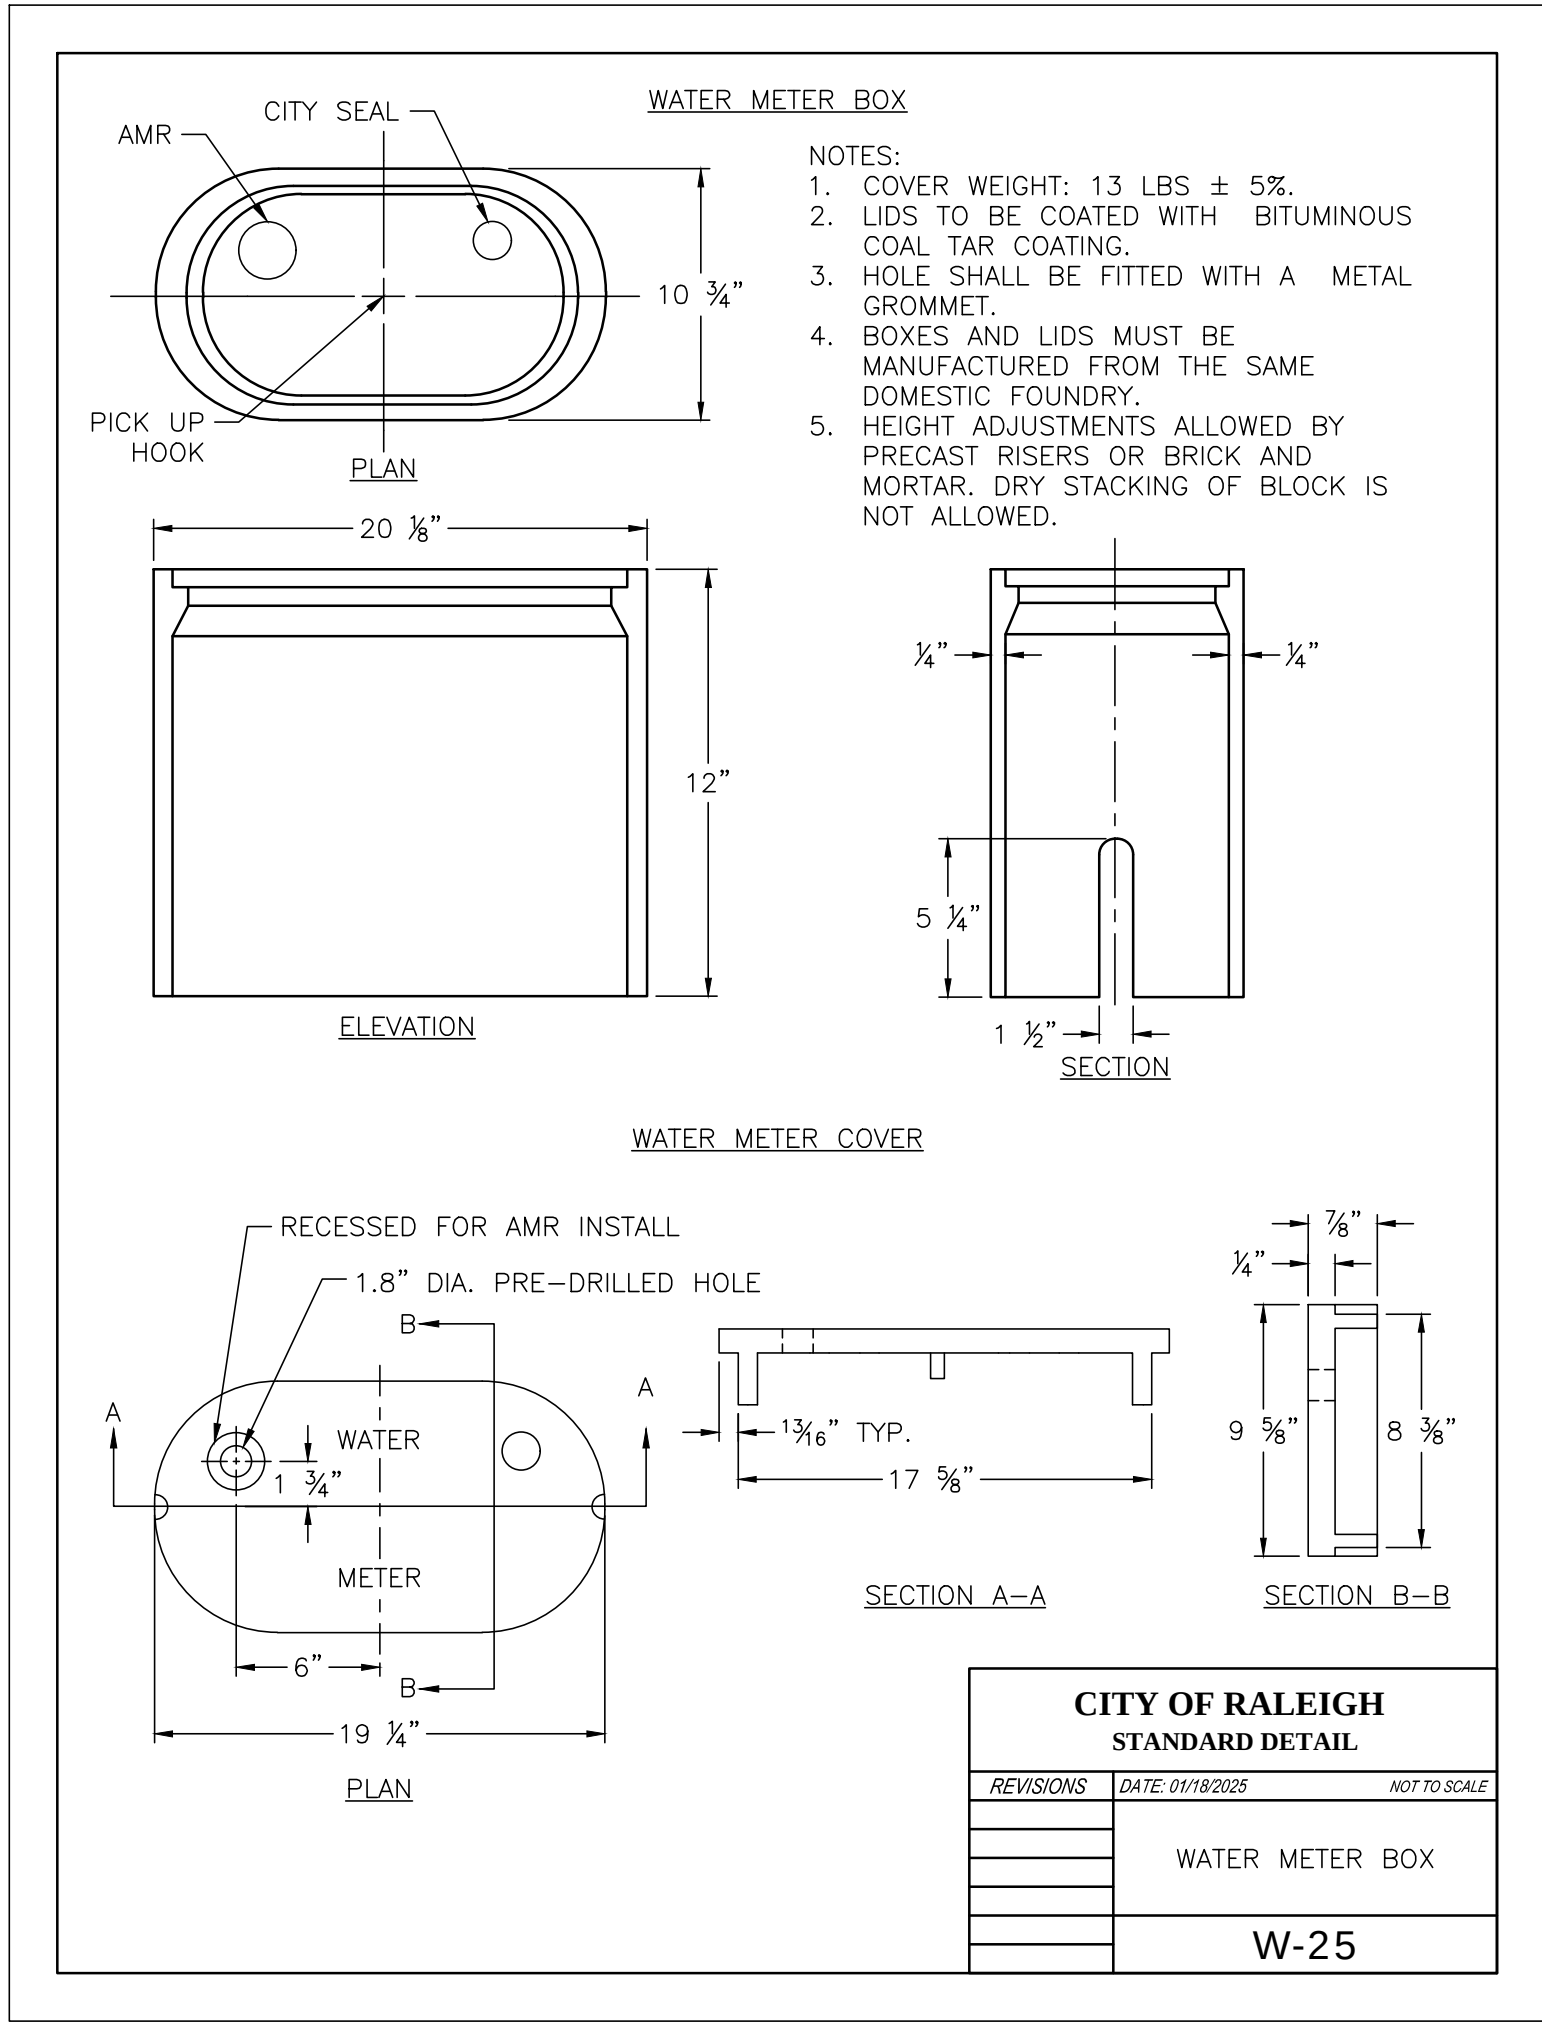


2 WATER METER BOX
N.T.S.

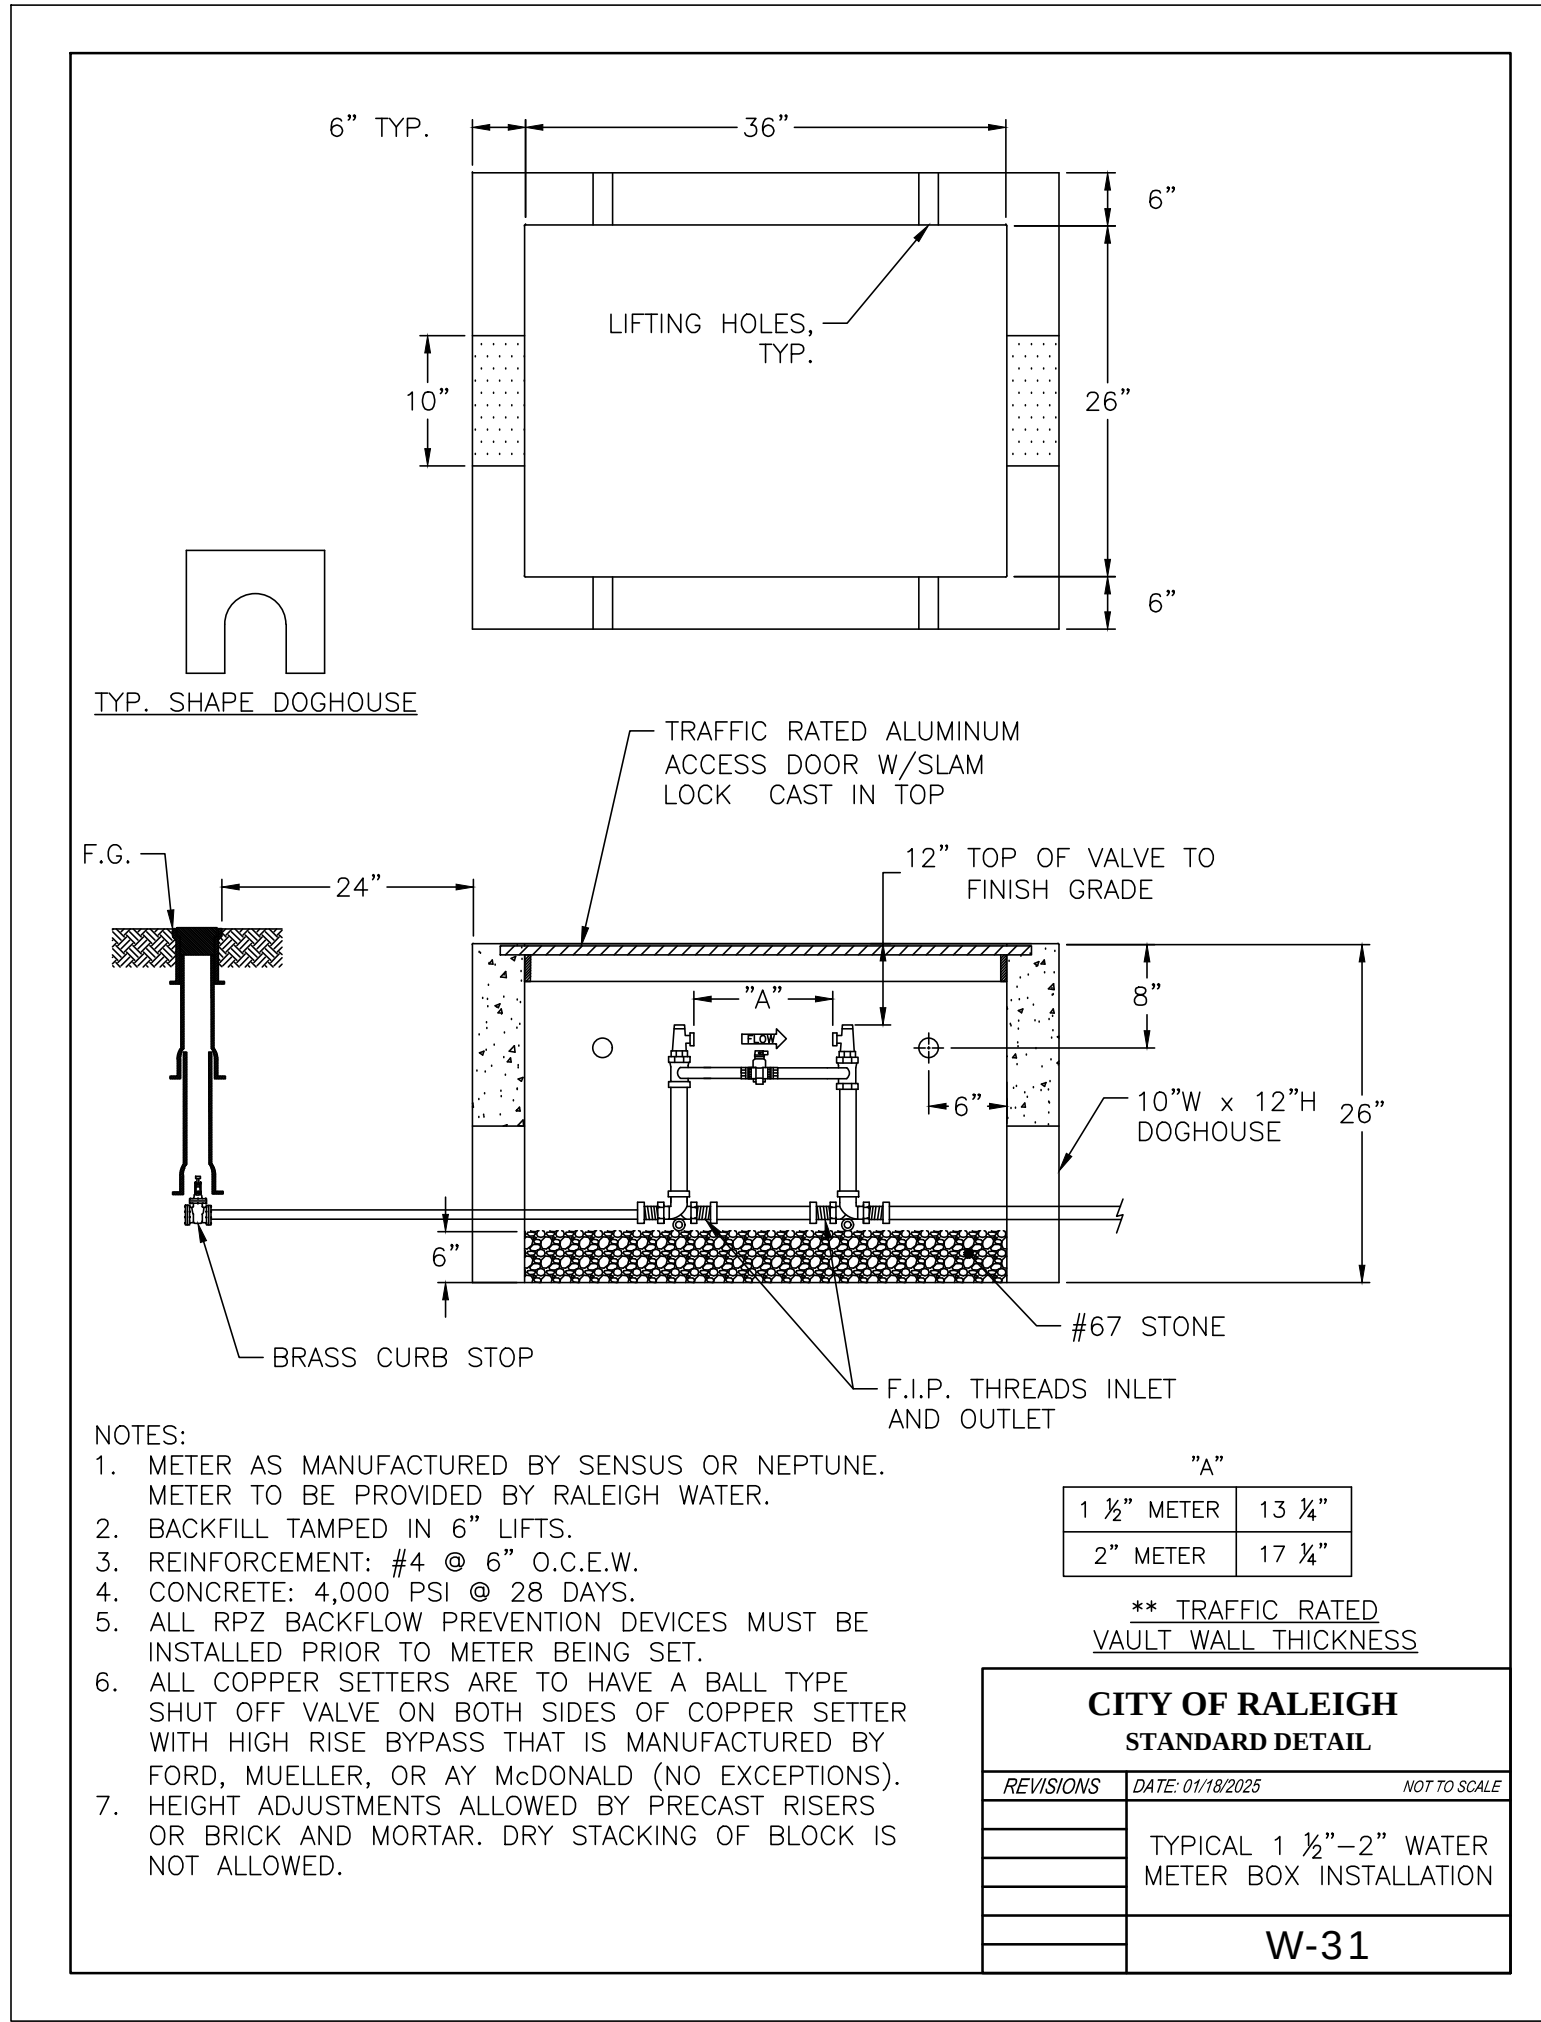


3 TYPICAL 1 1/2"-2" WATER METER BOX INSTALLATION
N.T.S.

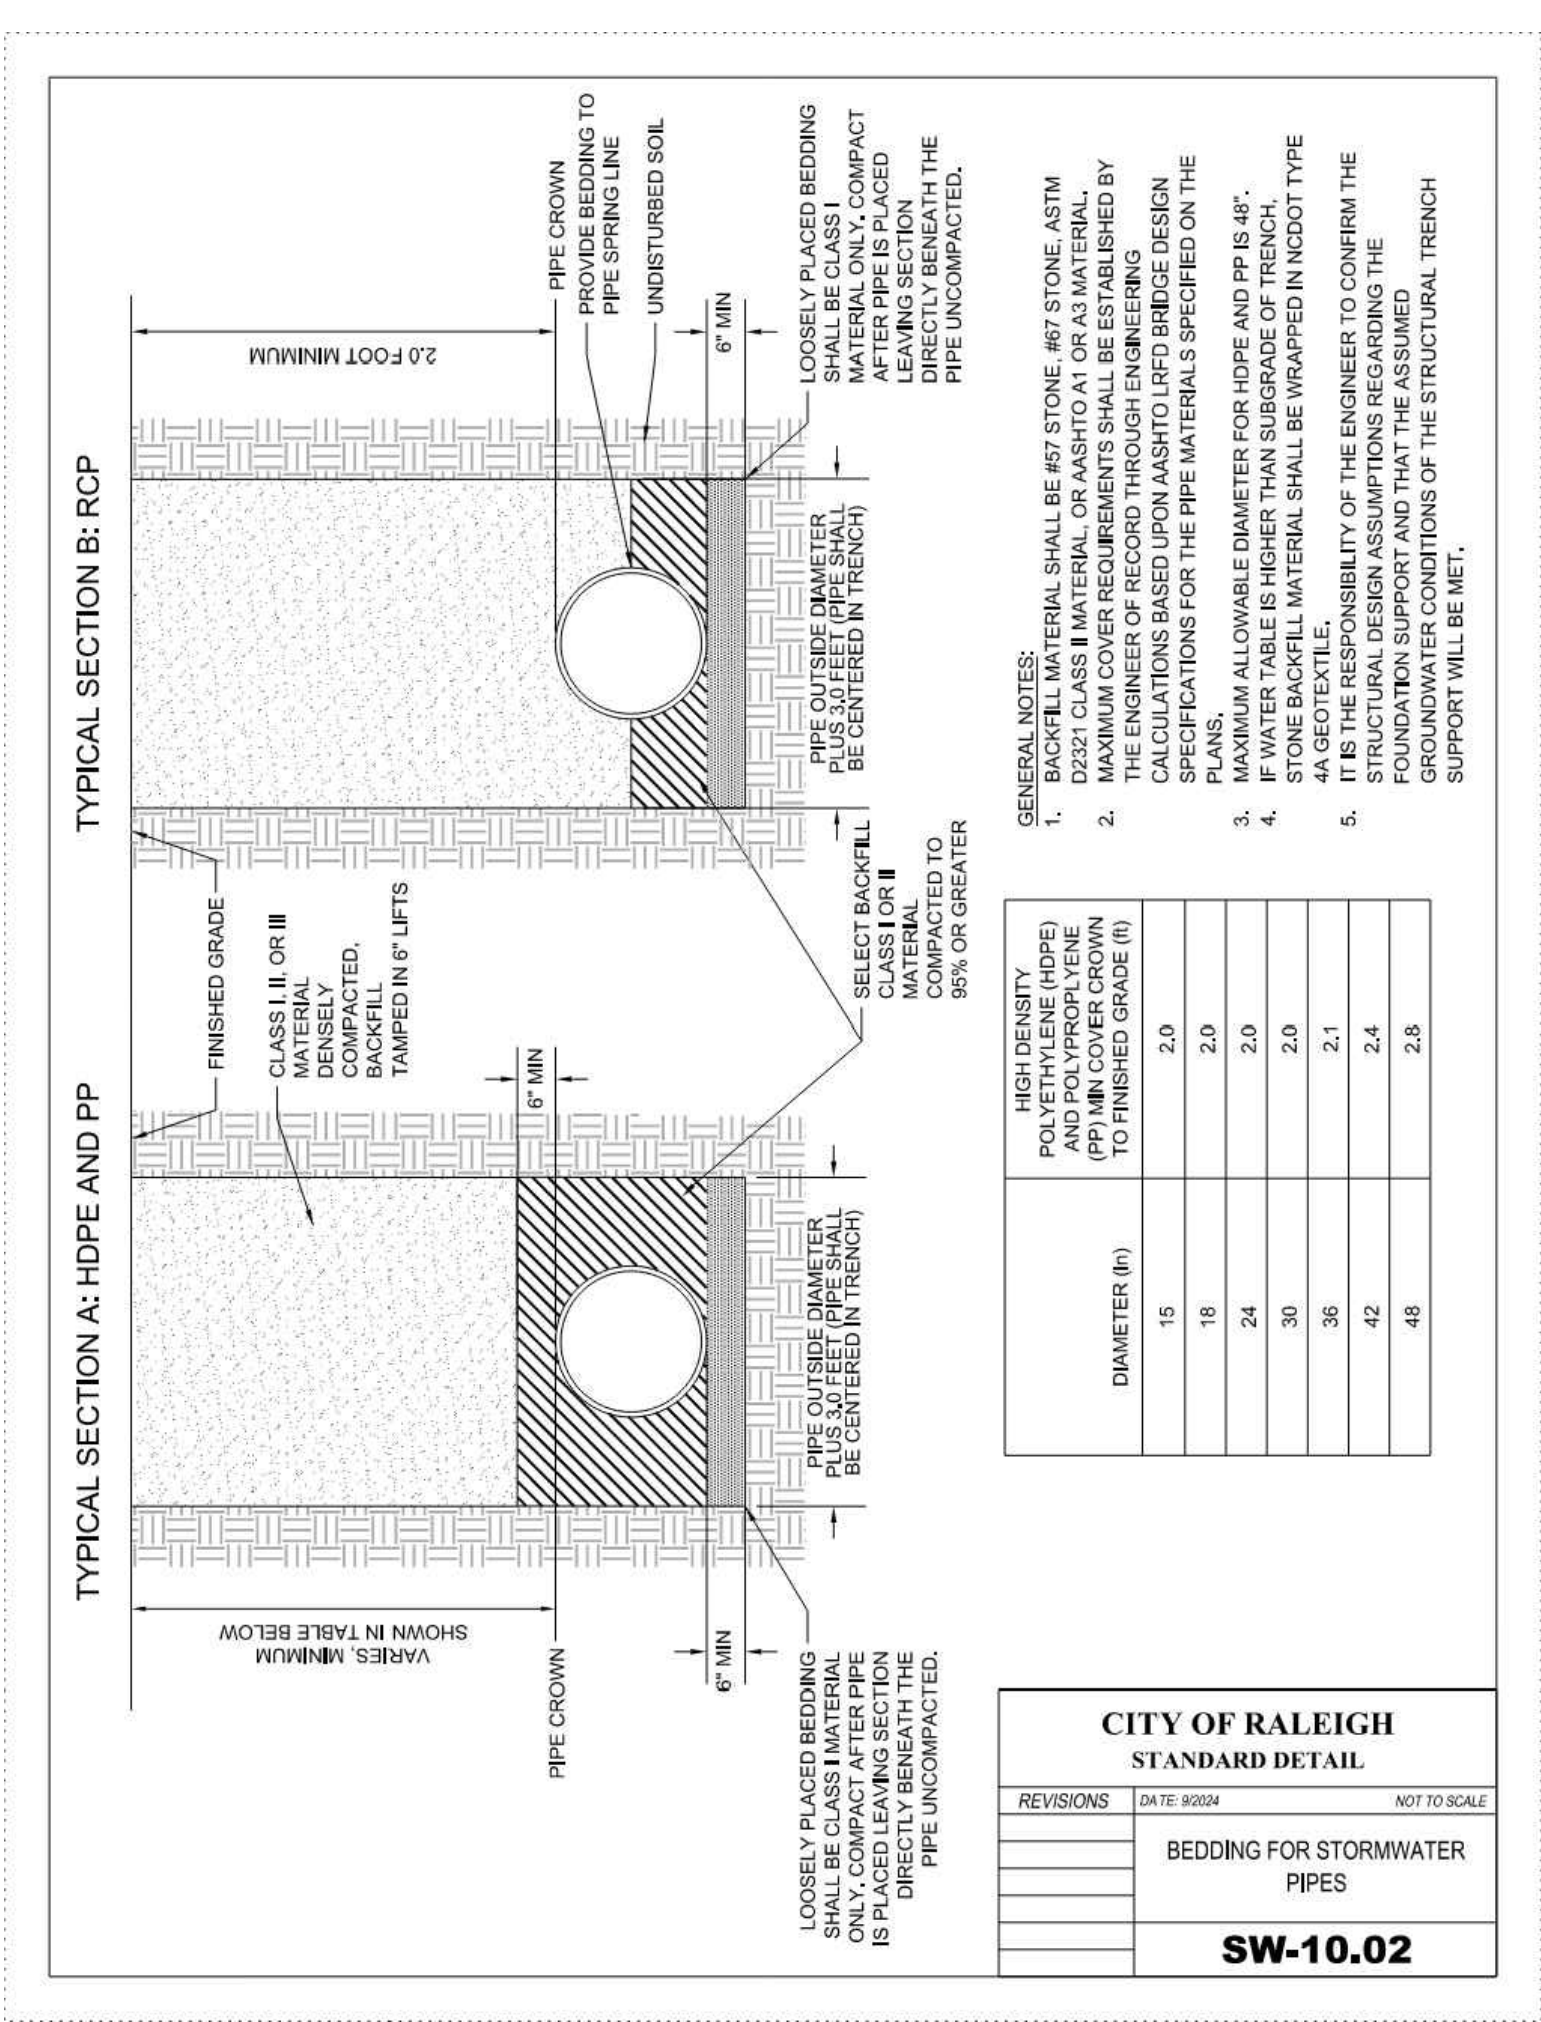


4 BEDDING FOR STORMWATER PIPES
N.T.S.

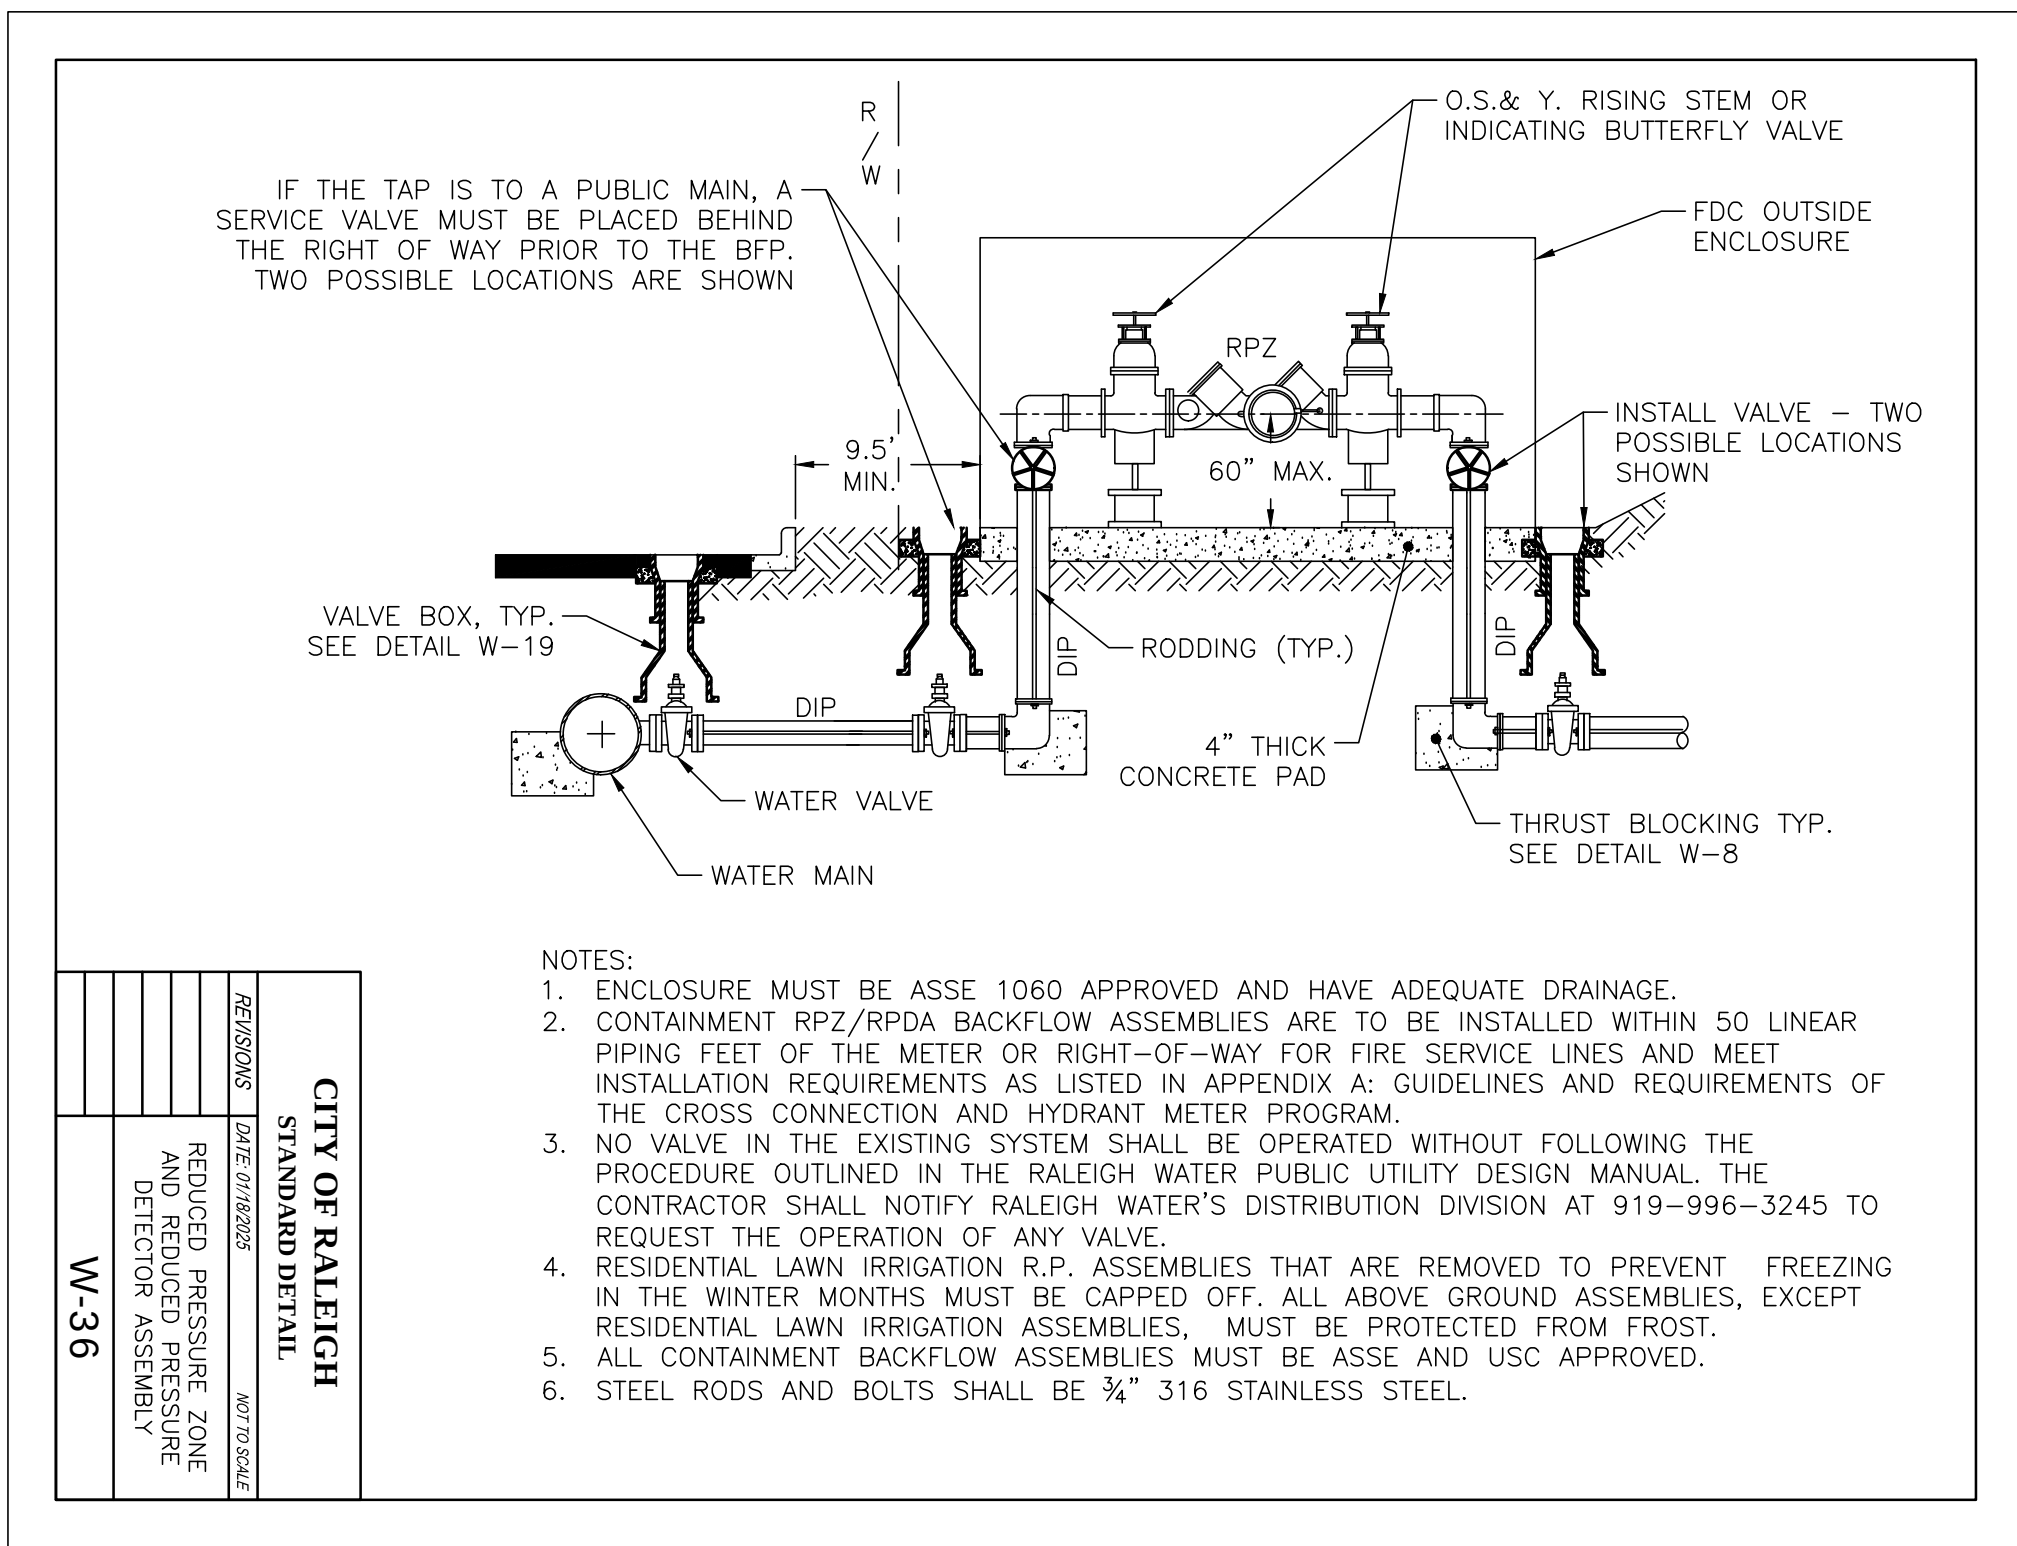





5 REDUCED PRESSURE ZONE AND REDUCED PRESSURE DETECTOR ASSEMBLY
N.T.S.

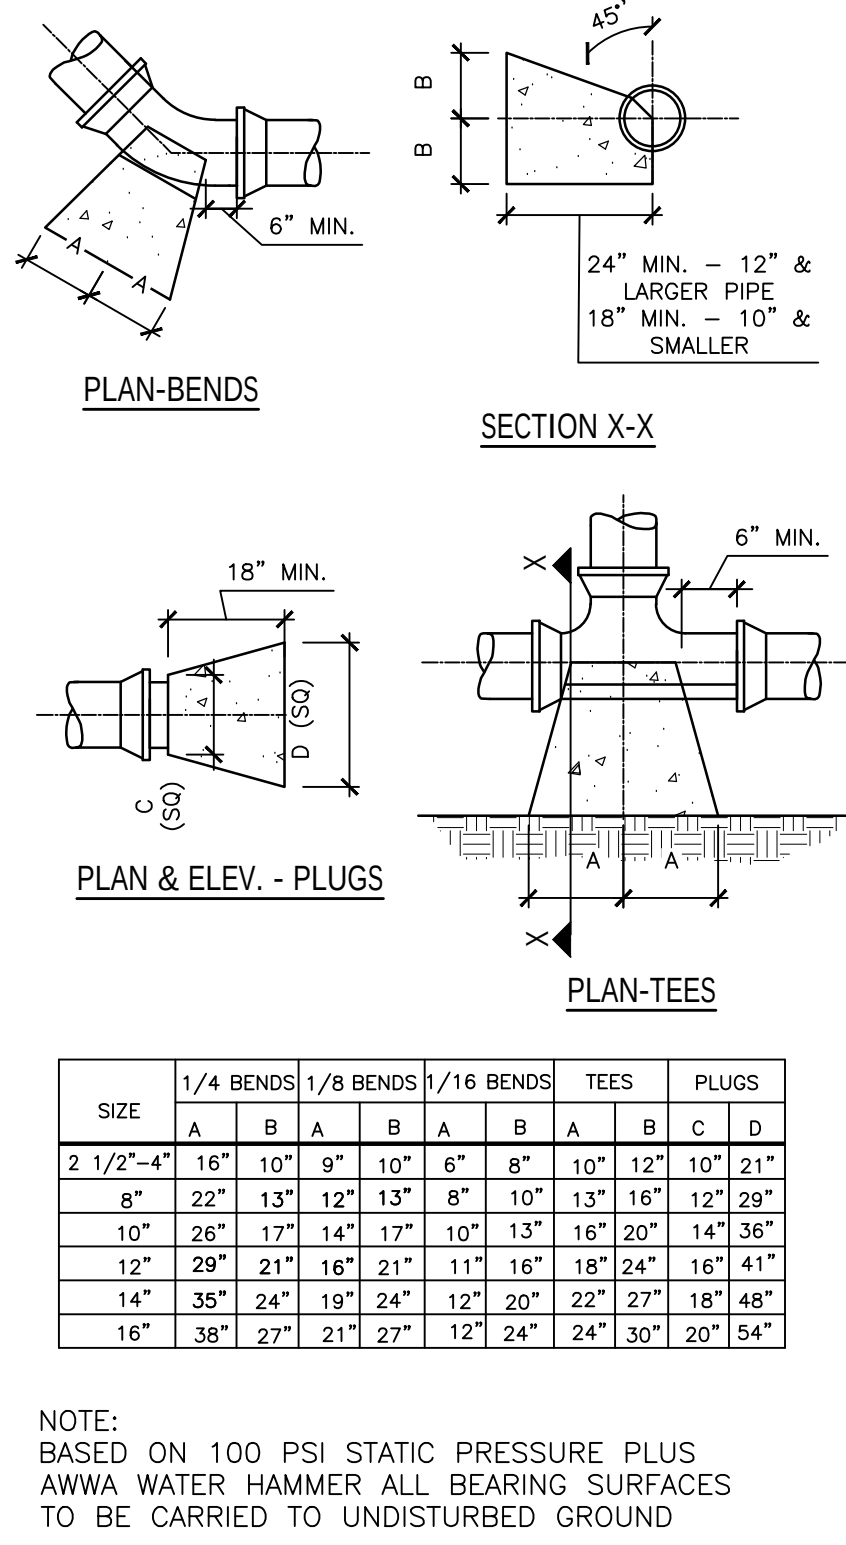

6 CONCRETE THRUST BLOCK
N.T.S.

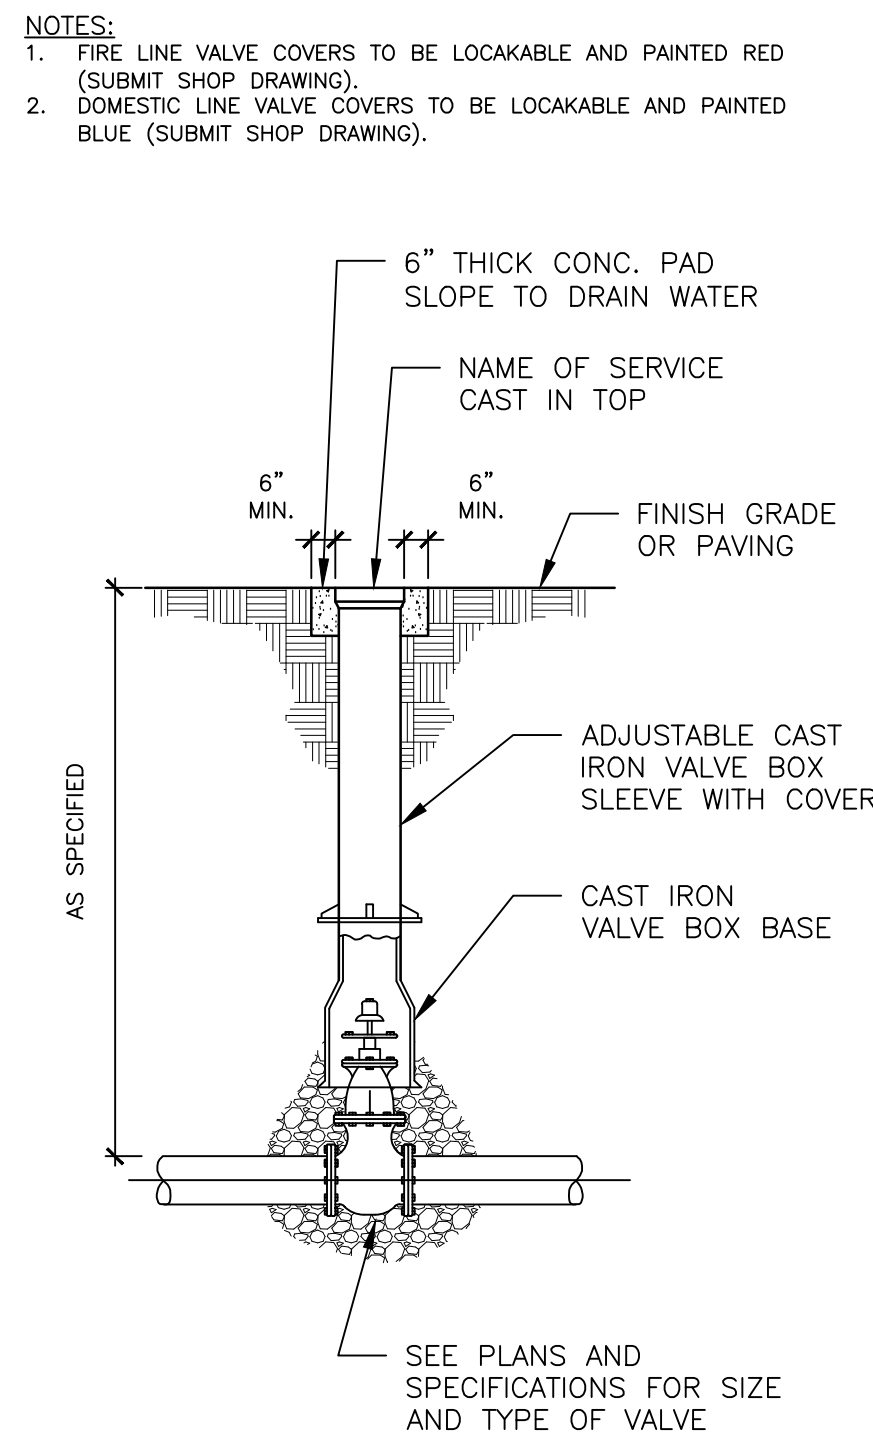

7 GATE VALVE
N.T.S.

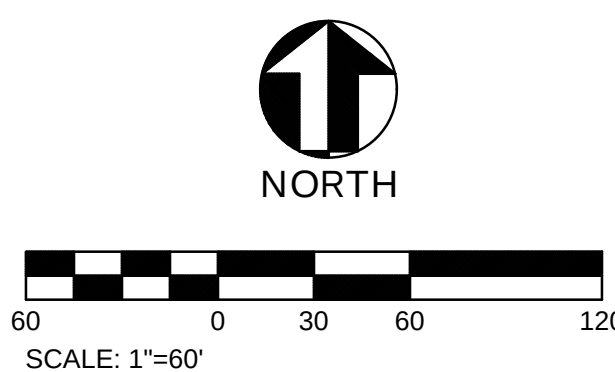   [illegible]


Y:\North Carolina\TX\TX-05\1725-500672-00_Zebulon_Land_Landscape_Plan.dwg (1725-500672-00_Zebulon_Land_Landscape_Plan.dwg)












STREETSCAPE BUFFER REQUIREMENTS	
STREETSCAPE BUFFER	
SHALL MAINTAIN A MINIMUM WIDTH OF AT LEAST 15' FROM THE LOT LINE.	
STREETSCAPE BUFFERS SHALL NOT BE LOCATED WITHIN REQUIRED SIGHT DISTANCE TRIANGLE.	
STREETSCAPE BUFFERS SHALL BE CONFIGURED AS A TYPE 'C' SEMI-OPAQUE BUFFER EXCEPT THAT THE MINIMUM NUMBER OF REQUIRED SHRUBS IS REDUCED FROM 25 TO 20, AND THE ON-CENTER SPACING IS REDUCED TO 5'.	
PLANT MATERIAL REQUIREMENTS	
4 UNDERSTORY TREES PER 100 LF	
6 UNDERSTORY TREES PER 100 LF (MAXIMUM SPACING OF 16' O.C.)	
20 SHRUBS PER 100 LF MAXIMUM SPACING OF 5' O.C.	
(75% OF REQUIRED SHRUBS NEED TO BE EVERGREEN)	
LOCATION	WATER PLANT ROAD FRONTAGE (OVERHEAD POWER LINES PRESENT)
TOTAL LF	324 LF
BUFFER WIDTH	15'
REQUIRED CANOPY TREES	N/A (OVERHEAD POWER LINES PRESENT)
REQUIRED UNDERSTORY TREES	33 REQUIRED UNDERSTORY TREES
PROVIDED UNDERSTORY TREES	33 PROVIDED UNDERSTORY TREES
REQUIRED SHRUBS	65 REQUIRED SHRUBS
PROVIDED SHRUBS	67 PROVIDED SHRUBS

PARKING LOT REQUIREMENTS	
ALL PARKING LOTS SHALL BE SERVED BY:	
ONE CANOPY TREE FOR EVERY 12 OFF-STREET PARKING SPACES PROVIDED.	
REQUIRED CANOPY TREES MAY BE PLACED AROUND, IN, OR NEAR THE PARKING LOT PROVIDED THAT NO PARKING SPACE IS MORE THAN 50' FROM THE TRUNK OF A CANOPY TREE.	
REQUIRED CANOPY TREES SHALL BE DISTRIBUTED THROUGHOUT PARKING AREAS AND MAY BE LOCATED IN LANDSCAPE ISLANDS, BETWEEN ROWS OF PARKING, IN DRIVEWAY MEDIANS, AND WITHIN TEN FEET OF THE PERIMETER OF THE PARKING LOT.	
A SINGLE CONTINUOUS ROW OF EVERGREEN SHRUBS PLANTED NO GREATER THAN THREE FEET ON-CENTER AND WITHIN FIVE FEET OF THE PARKING LOT EDGE.	
PARKING SPACES	50 SPACES / 12 = 5 TREES
REQUIRED CANOPY TREES	5 REQUIRED CANOPY TREES
PROVIDED CANOPY TREES	5 PROVIDED CANOPY TREES



SITE LANDSCAPING REQUIREMENTS	
ONE CANOPY TREE FOR EVERY 2,000 SQUARE FEET OF LOT AREA FOR THE FIRST 20,000 SQUARE FEET OF A LOT.	
20,000 SF / 2,000 SF =	10 CANOPY TREES
REQUIRED CANOPY TREES	10 REQUIRED CANOPY TREES
PROVIDED CANOPY TREES	10 PROVIDED CANOPY TREES

PERIMETER BUFFER REQUIREMENTS	
PLANT MATERIAL REQUIREMENTS	
4 UNDERSTORY TREES PER 100 LF	
15 SHRUBS PER 100 LF (50% MINIMUM EVERGREEN SHRUBS)	
BUFFER LOCATION	EASTERN PROPERTY BOUNDARY
BUFFER TYPE	TYPE 'A'
BUFFER LF	180 LF
BUFFER WIDTH	10' WIDE
TOTAL CANOPY TREES REQUIRED	NONE
TOTAL UNDERSTORY TREES REQUIRED	8 UNDERSTORY TREES REQUIRED
TOTAL UNDERSTORY TREES PROVIDED	8 UNDERSTORY TREES PROVIDED
TOTAL SHRUBS REQUIRED	27 SHRUBS REQUIRED
TOTAL SHRUBS PROVIDED	30 SHRUBS PROVIDED

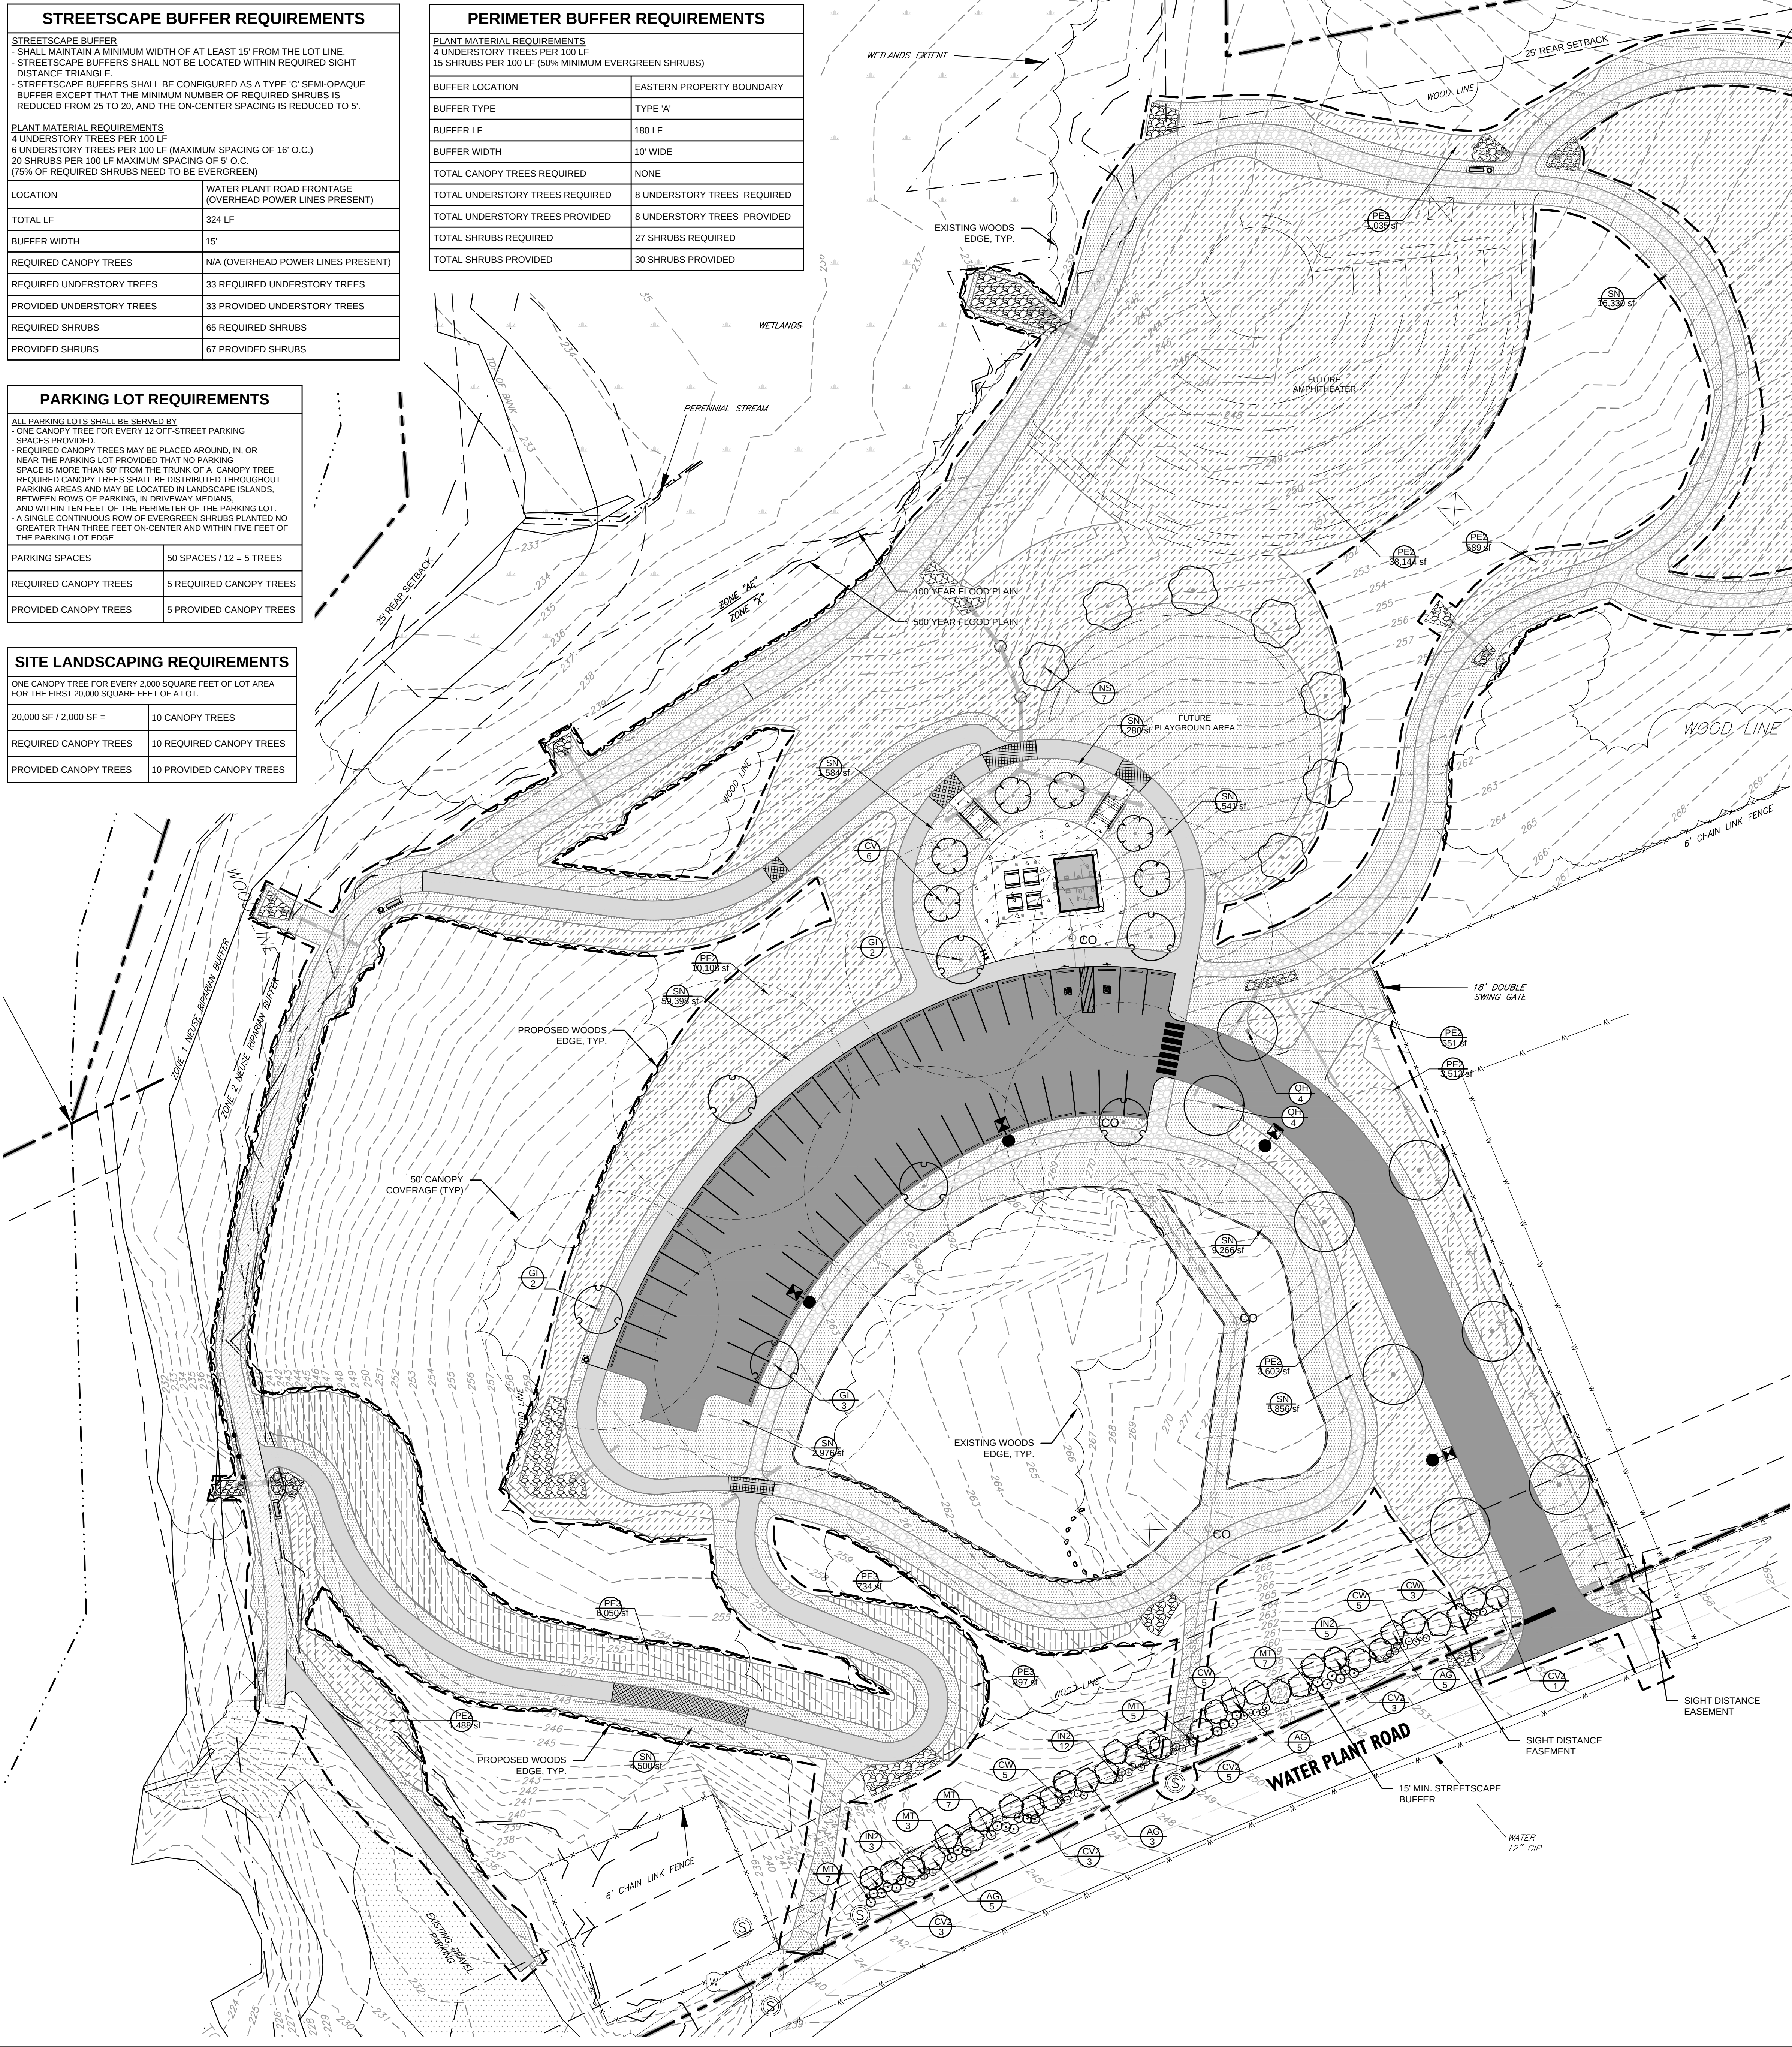

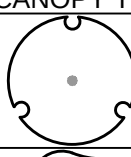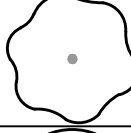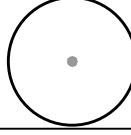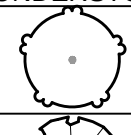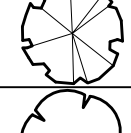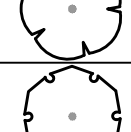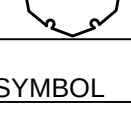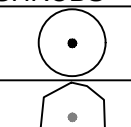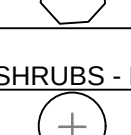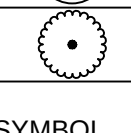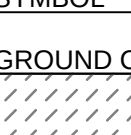PLANT SCHEDULE						
SYMBOL	CODE	QTY	BOTANICAL / COMMON NAME	ROOT	CAL.	REMARKS
CANOPY TREES						
	GI	7	Gleditsia triacanthos inermis 'Skycole' / Skyline® Honey Locust	B & B	2.5" Cal	
	NS	7	Nyssa sylvatica / Tupelo	B & B	2.5" Cal	
	QH	8	Quercus lyrata 'QLFTB' / Highbeam® Overcup Oak	B & B	2.5" Cal	
UNDERSTORY TREES						
	AG	18	Amelanchier x grandiflora 'Autumn Brilliance' / Autumn Brilliance Apple Serviceberry	B & B	1.5" Cal. min.	
	BD	8	Betula nigra 'Duraheat' / Duraheat River Birch	B & B	1.5" Cal. min.	Single Stem
	CV	6	Chionanthus virginicus / White Fringetree	B & B	1.5" Cal. min.	
	CV2	15	Crataegus viridis 'Winter King' / Winter King Hawthorn	B & B	1.5" Cal. min.	
SYMBOL	CODE	QTY	BOTANICAL / COMMON NAME	CONT	REMARKS	HEIGHT
SHRUBS						
	CW	18	Callicarpa americana 'Welch's Pink' / Welch's Pink American Beautyberry	3 gal		18" MIN.
	IV	15	Itea virginica 'Henry's Garnet' / Henry's Garnet Sweetspire	3 gal		18" MIN.
SHRUBS - EVERGREEN						
	IN2	20	Ilex vomitoria 'Nana' / Dwarf Yaupon Holly	3 gal		18" MIN.
	MT	44	Myrica cerifera 'Tom's Dwarf' / Tom's Dwarf Wax Myrtle	3 gal		18" MIN.
SYMBOL	CODE	QTY	BOTANICAL / COMMON NAME	CONT	REMARKS	SPACING
GROUND COVERS						
	PE2	79,218 sf	Pollinator meadow Mix / See Specs.	seed		
	SN	123,505 sf	Seeded lawn / See Specs.	seed		
	PE3	7,681 sf	Shade meadow Mix / See Specs.	seed		

LEGEND	
	SIGN
	EXISTING LIGHT POLE
	EXISTING UTILITY POLE
	ACCESSIBLE SPACE
	EXISTING FIRE HYDRANT
	EXISTING TREE TO REMAIN
	PROPOSED GROUND COVER
	PLANT LABEL
	PLANT QUANTITY
	EXISTING CURB AND GUTTER
	PROPOSED CURB AND GUTTER
	PROPERTY LINE
	EXISTING FENCE
	PROPOSED FENCE
	EXISTING UNDERGROUND ELECTRIC LINE
	EXISTING OVERHEAD UTILITY LINE
	EXISTING TREE LINE
	PROPOSED TREE LINE AFTER CLEARING
	PROPOSED MULCH LINE
	PROPOSED STORM DRAINAGE PIPE
	PROPOSED FOUNDATION DRAIN
	SANITARY SEWER LINE
	WATER LINE

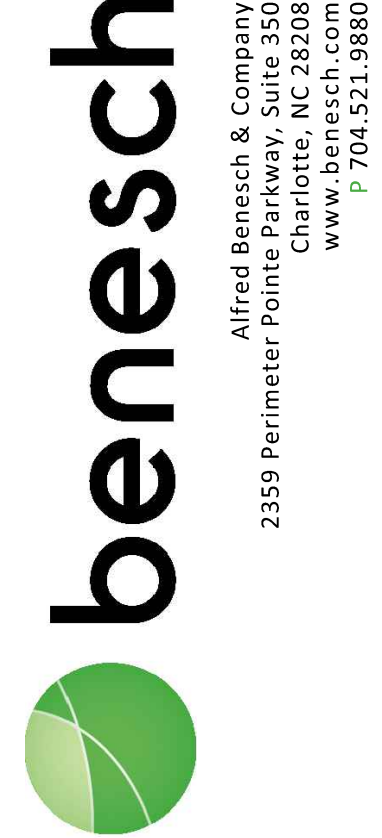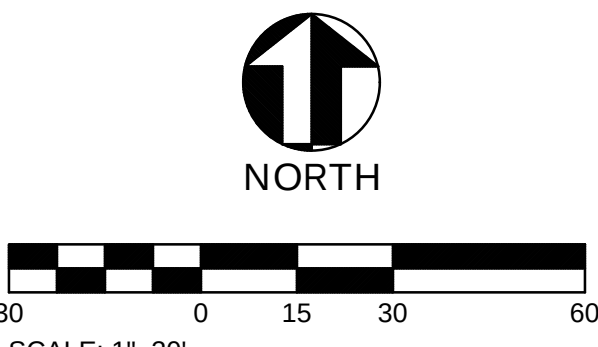

Seals:



Corp. NC License: F-1320

LITTLE RIVER PARK


1800 WEST GANNON AVENUE
ZEBULON, NORTH CAROLINA

Project No: 1725-500672.00
Date: 4.18.25
Revisions:

Sheet Title:
LANDSCAPE
PLAN

Sheet No:
C601

LIGHTING FIXTURE SCHEDULE										
MARK	MANUF.	CATALOG NUMBER	LAMP DATA		VOLTS	BALLAST DATA		INPUT WATTS	MOUNTING	DESCRIPTION
			NO.	TYPE		NO.	TYPE			
A	HE WILLIAMS	6DR-TL-L20/835-DIM-UNV-L-M-OF-WET/CC	-	LED	120/277	-	-	19	RECESSED	GENERAL - 6" WET LISTED RECESSED LED.
NOTES: I. CATALOG NUMBERS AND MANUFACTURERS ARE TO INDICATE TYPE AND QUALITY OF FIXTURE DESIRED. SUBMIT CUTSHEETS OF THESE AND ALTERNATE MANUFACTURERS FOR ARCHITECT AND OWNER APPROVAL PRIOR TO PURCHASE OF ANY FIXTURES. INFORMATION ON ALTERNATE FIXTURES PROPOSED BY THE CONTRACTOR SHALL INCLUDE THE ADD/DEDUCT ASSOCIATED WITH ACCEPTANCE OF THAT FIXTURE (OR THE ALTERNATE PACKAGE AS A WHOLE).										
LIGHTING SYSTEMS ENERGY CONSERVATION CODE SECTION 405										
THIS PROJECT IS CLASSIFIED AS - ☐ RESIDENTIAL ☒ COMMERCIAL (SEE BELOW)										
LIGHTING POWER DENSITY CALCULATION COMPLIANCE INTERIOR LIGHTING POWER DENSITY CALCULATION PER TABLE 405.4.2. SEE LIGHTING FIXTURE SCHEDULE FOR FIXTURE INFORMATION. RESTROOM INTERIOR WATTAGE SPECIFIED VS. ALLOWED <u>140 VS. 229</u> EXTERIOR LIGHTING POWER DENSITY CALCULATION PER TABLE 405.6.2. SEE LIGHTING FIXTURE SCHEDULE FOR FIXTURE INFORMATION. TRADABLE EXTERIOR WATTAGE SPECIFIED VS. ALLOWED <u>171 VS. 600</u> NONTRADABLE EXTERIOR WATTAGE SPECIFIED VS. ALLOWED <u>NA VS. NA</u>					DESIGNER STATEMENT: TO THE BEST OF MY KNOWLEDGE AND BELIEF, THE DESIGN OF THIS BUILDING COMPLIES WITH THE LIGHTING SYSTEMS REQUIREMENTS OF THE INTERNATIONAL ENERGY CONSERVATION CODE, SECTION 505 AND ANY LOCAL AMENDMENTS THEREOF. SIGNED: <u> II</u> NAME: <u>JAMES HOFFMAN III</u> TITLE: <u>ELECTRICAL ENGINEER</u>					
SECTION 406 COMPLIANCE - ☐ N/A ☐ 406.11 ☒ 406.12 ☐ 406.13 ☐ 406.14 ☐ 406.15 ☐ 406.16										

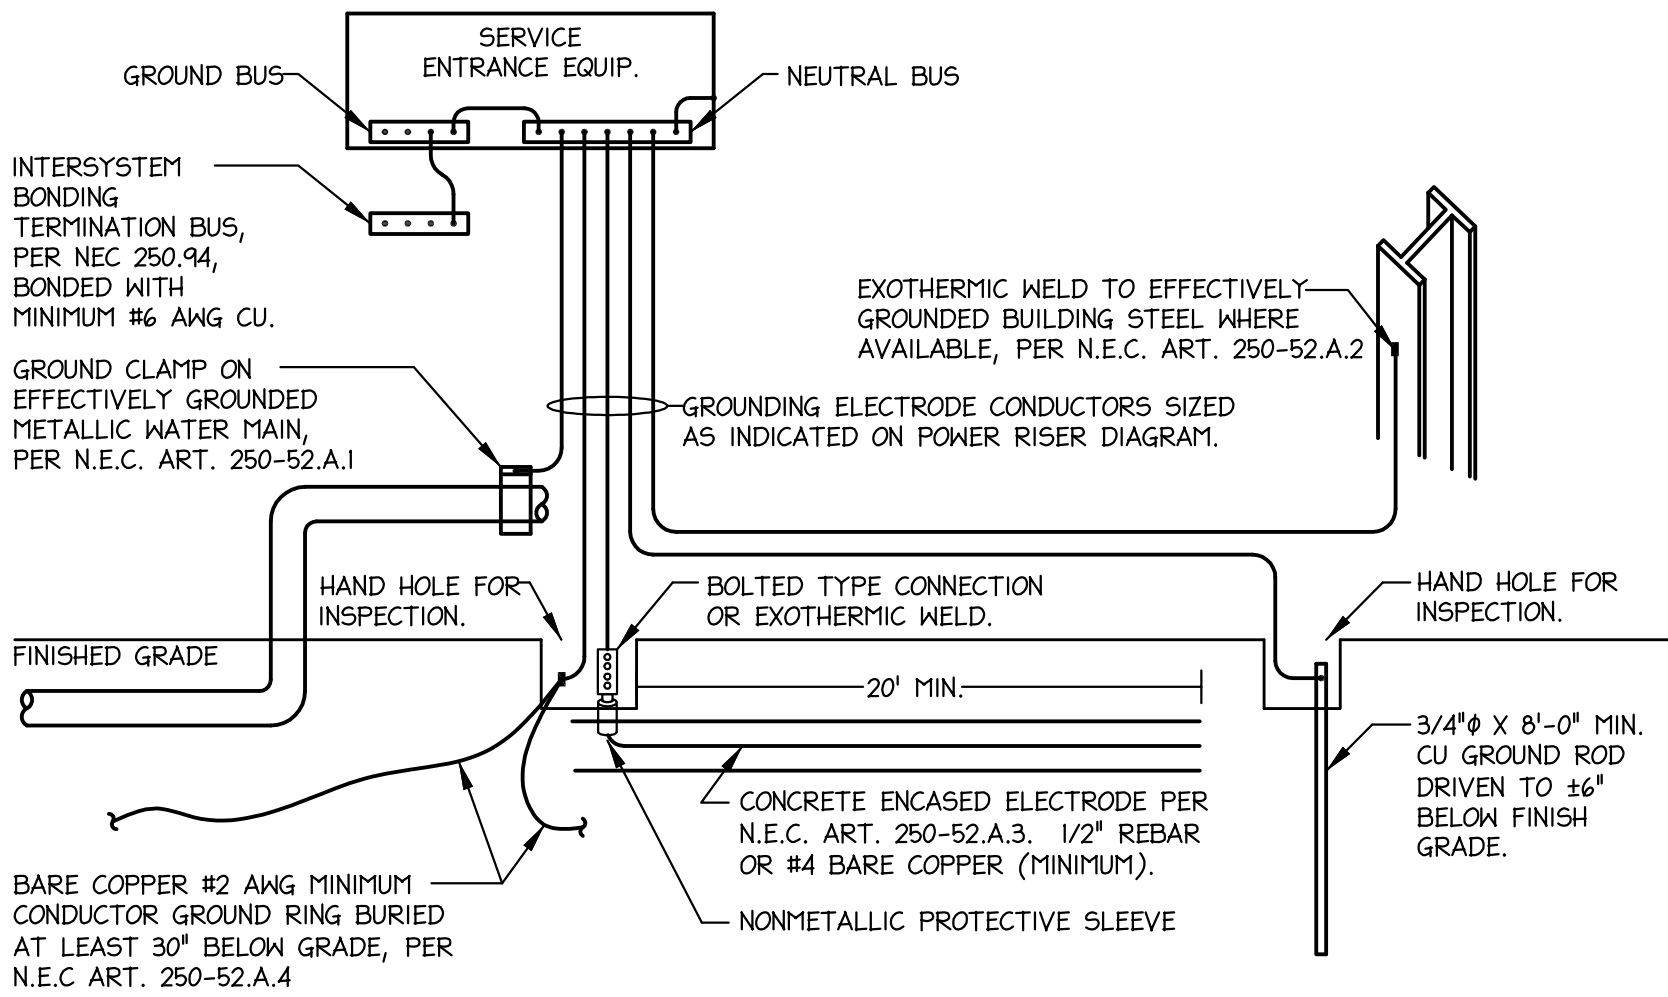

1 GROUNDING DETAIL NTS

GROUNDING ELECTRODES SHALL BE PROVIDED IN ACCORDANCE WITH NEC SECTION 250. ALL GROUNDING ELECTRODE CONDUCTORS SIZED AS INDICATED ON POWER RISER DIAGRAM. **ALL METHODS OF CREATING THE GROUNDING SYSTEM MAY NOT BE REQUIRED OR AVAILABLE.**

ELECTRICAL SYMBOL LEGEND


	CIRCUIT CONDUCTORS CONCEALED IN FLOOR, WALL OR CEILING. ARROWHEAD INDICATES HOMERUN TO PANEL NOTED.
	SINGLE POLE SWITCH, 20A, 120/277 VOLT, 48" A.F.F. TO CENTER.
	DUPLEX RECEPTACLE, 15 AMP, 120 VOLT, 18" A.F.F. TO CENTER. FOR SINGLE RECEPTACLE ON A CIRCUIT, USE A 20A RECEPTACLE. "GF" INDICATES GROUND FAULT CIRCUIT INTERRUPTER TYPE. "WP" INDICATES WEATHERPROOF. "EWC" INDICATES MOUNT INSIDE ENCLOSURE OF ELECTRIC WATER COOLER.
	240/120V PANEL, SURFACE OR RECESS MOUNTED, SEE SCHEDULE FOR DETAILS.
	SURFACE, RECESSED OR GROUND MOUNTED LIGHTING FIXTURE, SEE FIXTURE SCHEDULE FOR DETAILS.
	ELECTRIC UTILITY METER LOCATION.

ELECTRICAL ABBREVIATIONS


18"	DIMENSION INDICATES HEIGHT ABOVE FINISHED FLOOR AT WHICH CENTER OF DEVICE IS TO BE MOUNTED.
AFF	ABOVE FINISHED FLOOR.
AFG	ABOVE FINISHED GRADE.
EC	ELECTRICAL CONTRACTOR.
FPN	FUSE PER EQUIPMENT NAMEPLATE REQUIREMENTS.
GC	GENERAL CONTRACTOR.
MC	MECHANICAL CONTRACTOR.
PC	PLUMBING CONTRACTOR.
WP	INDICATES DEVICE TO HAVE WEATHERPROOF COVER.
UON	UNLESS OTHERWISE NOTED.

GENERAL ELECTRICAL NOTES

- ALL ELECTRICAL WORK SHALL BE IN ACCORDANCE WITH THE 2020 EDITION OF THE NATIONAL ELECTRICAL CODE AND ALL LOCAL AND STATE CODES.
- ALL MATERIAL, DEVICES, APPLIANCES, AND EQUIPMENT SHALL BE NEW AND SHALL CONFORM TO THE STANDARDS OF THE UNDERWRITER'S LABORATORIES, INC., AND THE NATIONAL ELECTRICAL MANUFACTURERS ASSOCIATION.
- ALL ELECTRICAL PERMITS AND INSPECTION FEES SHALL BE OBTAINED AND PAID FOR BY THE ELECTRICAL CONTRACTOR. DRAWINGS ARE DIAGRAMMATIC ONLY AND INDICATE ONLY THE GENERAL ARRANGEMENT. SEE ARCHITECTURAL DRAWINGS FOR EXACT DIMENSIONS.
- ELECTRICAL CONTRACTOR SHALL GUARANTEE ALL WORK AND MATERIALS FOR ONE YEAR EFFECTIVE THE DAY THE PROJECT IS ACCEPTED BY THE OWNER.
- ELECTRICAL CONTRACTOR SHALL MAKE ALL ELECTRICAL POWER CONNECTIONS TO HVAC, PLUMBING AND OTHER EQUIPMENT AS REQUIRED.
- A COMPLETE GROUNDING SYSTEM SHALL BE PROVIDED AND INSTALLED IN ACCORDANCE WITH ARTICLE 250 OF THE NEC, AND AS SHOWN ON THE DRAWINGS.
- ALL CUTTING AND PATCHING OF WALLS AND FLOORS FOR ELECTRICAL EQUIPMENT SHALL BE THE RESPONSIBILITY OF THE ELECTRICAL CONTRACTOR.
- CONDUCTORS SHALL BE COPPER RATED AT NOT LESS THAN 600 VOLTS. MINIMUM SIZE SHALL BE #12 AWG UNLESS OTHERWISE NOTED ON THE DRAWINGS. ALL WIRE #8 AWG AND LARGER SHALL BE STRANDED. ALL CONDUCTORS #10 AND SMALLER SHALL BE SOLID, UNLESS OTHERWISE NOTED. ALUMINUM CONDUCTORS AND MINIMUM SIZE OF #14 SHALL BE USED IN RESIDENTIAL UNITS. BRANCH CIRCUIT CONDUCTORS SHALL BE TYPE THIN OR THIN AS REQUIRED.
- USE SCHEDULE 40 PVC OUTDOORS WHERE NOT SUBJECT TO PHYSICAL DAMAGE OR BELOW FLOOR SLAB. MINIMUM CONDUIT SIZE TO BE 1/2". TYPE NM, MC AND AC CABLE MAY BE USED WHERE PERMISSIBLE BY NEC. FLEXIBLE CONDUIT SHALL BE USED FOR CONNECTIONS TO VIBRATING EQUIPMENT AND LUMINAIRES, BUT SHALL NOT EXCEED 6' IN LENGTH.
- PROVIDE A PULLWIRE IN ALL EMPTY CONDUITS.
- PROVIDE A TYPED DIRECTORY IN ALL PANELBOARDS CLEARLY DESCRIBING THE LOCATION OF AND TYPE OF LOAD BEING SERVED FOR ALL CIRCUITS. PROVIDE ENGRAVED PHENOLIC NAMEPLATES FOR ALL PANELBOARDS AND DISCONNECT SWITCHES, WHITE LETTERS ON BLACK BACKGROUND.
- FUSES 0 - 600 AMPS SHALL BE UL CLASS "RK-1" LOW PEAK DUAL ELEMENT TIME DELAY WITH 200,000 AMPERE INTERRUPTING RATING AS MANUFACTURED BY BUSSMANN, UNLESS NOTED OTHERWISE.
- ALL TERMINALS/LUGS SHALL BE 60/75" RATED. ALL TERMINALS, SPLICING CONNECTORS, LUGS, ETC SHALL BE IDENTIFIED FOR USE WITH THE MATERIAL (CU/AL) OF THE CONDUCTOR AND SHALL BE PROPERLY INSTALLED.
- VERIFY ALL REQUIREMENTS AND COORDINATE EXACT LOCATION OF INCOMING ELECTRICAL SERVICE WITH LOCAL POWER COMPANY PRIOR TO PROJECT START-UP. NOTIFY ENGINEER OF ANY CHANGES AS MAY BE REQUIRED.
- E.C. TO VERIFY DEVICE PLATE COLOR AND MATERIAL WITH ARCHITECT PRIOR TO PURCHASE.
- THE ELECTRICAL CONTRACTOR SHALL BE RESPONSIBLE FOR PROTECTING ALL ELECTRICAL EQUIPMENT FROM FOREIGN MATERIAL DURING CONSTRUCTION (PAINT, SPACKLE, ETC.).
- WHERE A HOME RUN IS SHOWN THE CIRCUIT SHALL BE INSTALLED IN A DEDICATED CONDUIT, DO NOT COMBINE WITH OTHER CIRCUITS. WHERE A CIRCUIT HOMERUN IS NOT SHOWN, THE CONTRACTOR SHALL COMBINE CIRCUITS AS FOLLOWS: A MAXIMUM OF THREE 20A BRANCH CIRCUITS MAY BE COMBINED IN A COMMON HOMERUN WITH SEPARATE NEUTRALS FOR A MAXIMUM TOTAL OF SIX CURRENT CARRYING CONDUCTORS. ALL BRANCH CIRCUITS LARGER THAN 20A SHALL BE SEPARATELY HOMERUN TO THE PANEL.
- RECEPTACLES IN COMMERCIAL AREAS SHALL BE SPECIFICATION GRADE EQUAL TO HUBBELL 5200/5300 SERIES; GROUND FAULT RECEPTACLES SHALL BE EQUAL TO HUBBELL GF-5362. LIGHTING SWITCHES SHALL BE SPECIFICATION GRADE EQUAL TO HUBBELL 1200 SERIES.
- ALL EXTERIOR FIXTURES AND DEVICES SHALL BE RATED FOR OPERATION AT 0' F AND SHALL BE DAMP OR WET LABELED AS REQUIRED.
- THE ELECTRICAL CONTRACTOR SHALL BE RESPONSIBLE FOR INSTALLING ALL ELECTRICAL EQUIPMENT, DEVICES, ETC. IN ACCORDANCE WITH LOCAL SEISMIC CODE REQUIREMENTS. PROVIDE SEISMIC RESTRAINTS, ACCESSORIES AND INSTALLATION DETAIL AS REQUIRED.
- ALL QUESTIONS MUST BE SUBMITTED IN RFI FORMAT TO THE ARCHITECT AND MUST BE ADDRESSED BY THE APPROPRIATE DESIGNER OF RECORD PRIOR TO BECOMING A PROPOSED CHANGE ORDER.

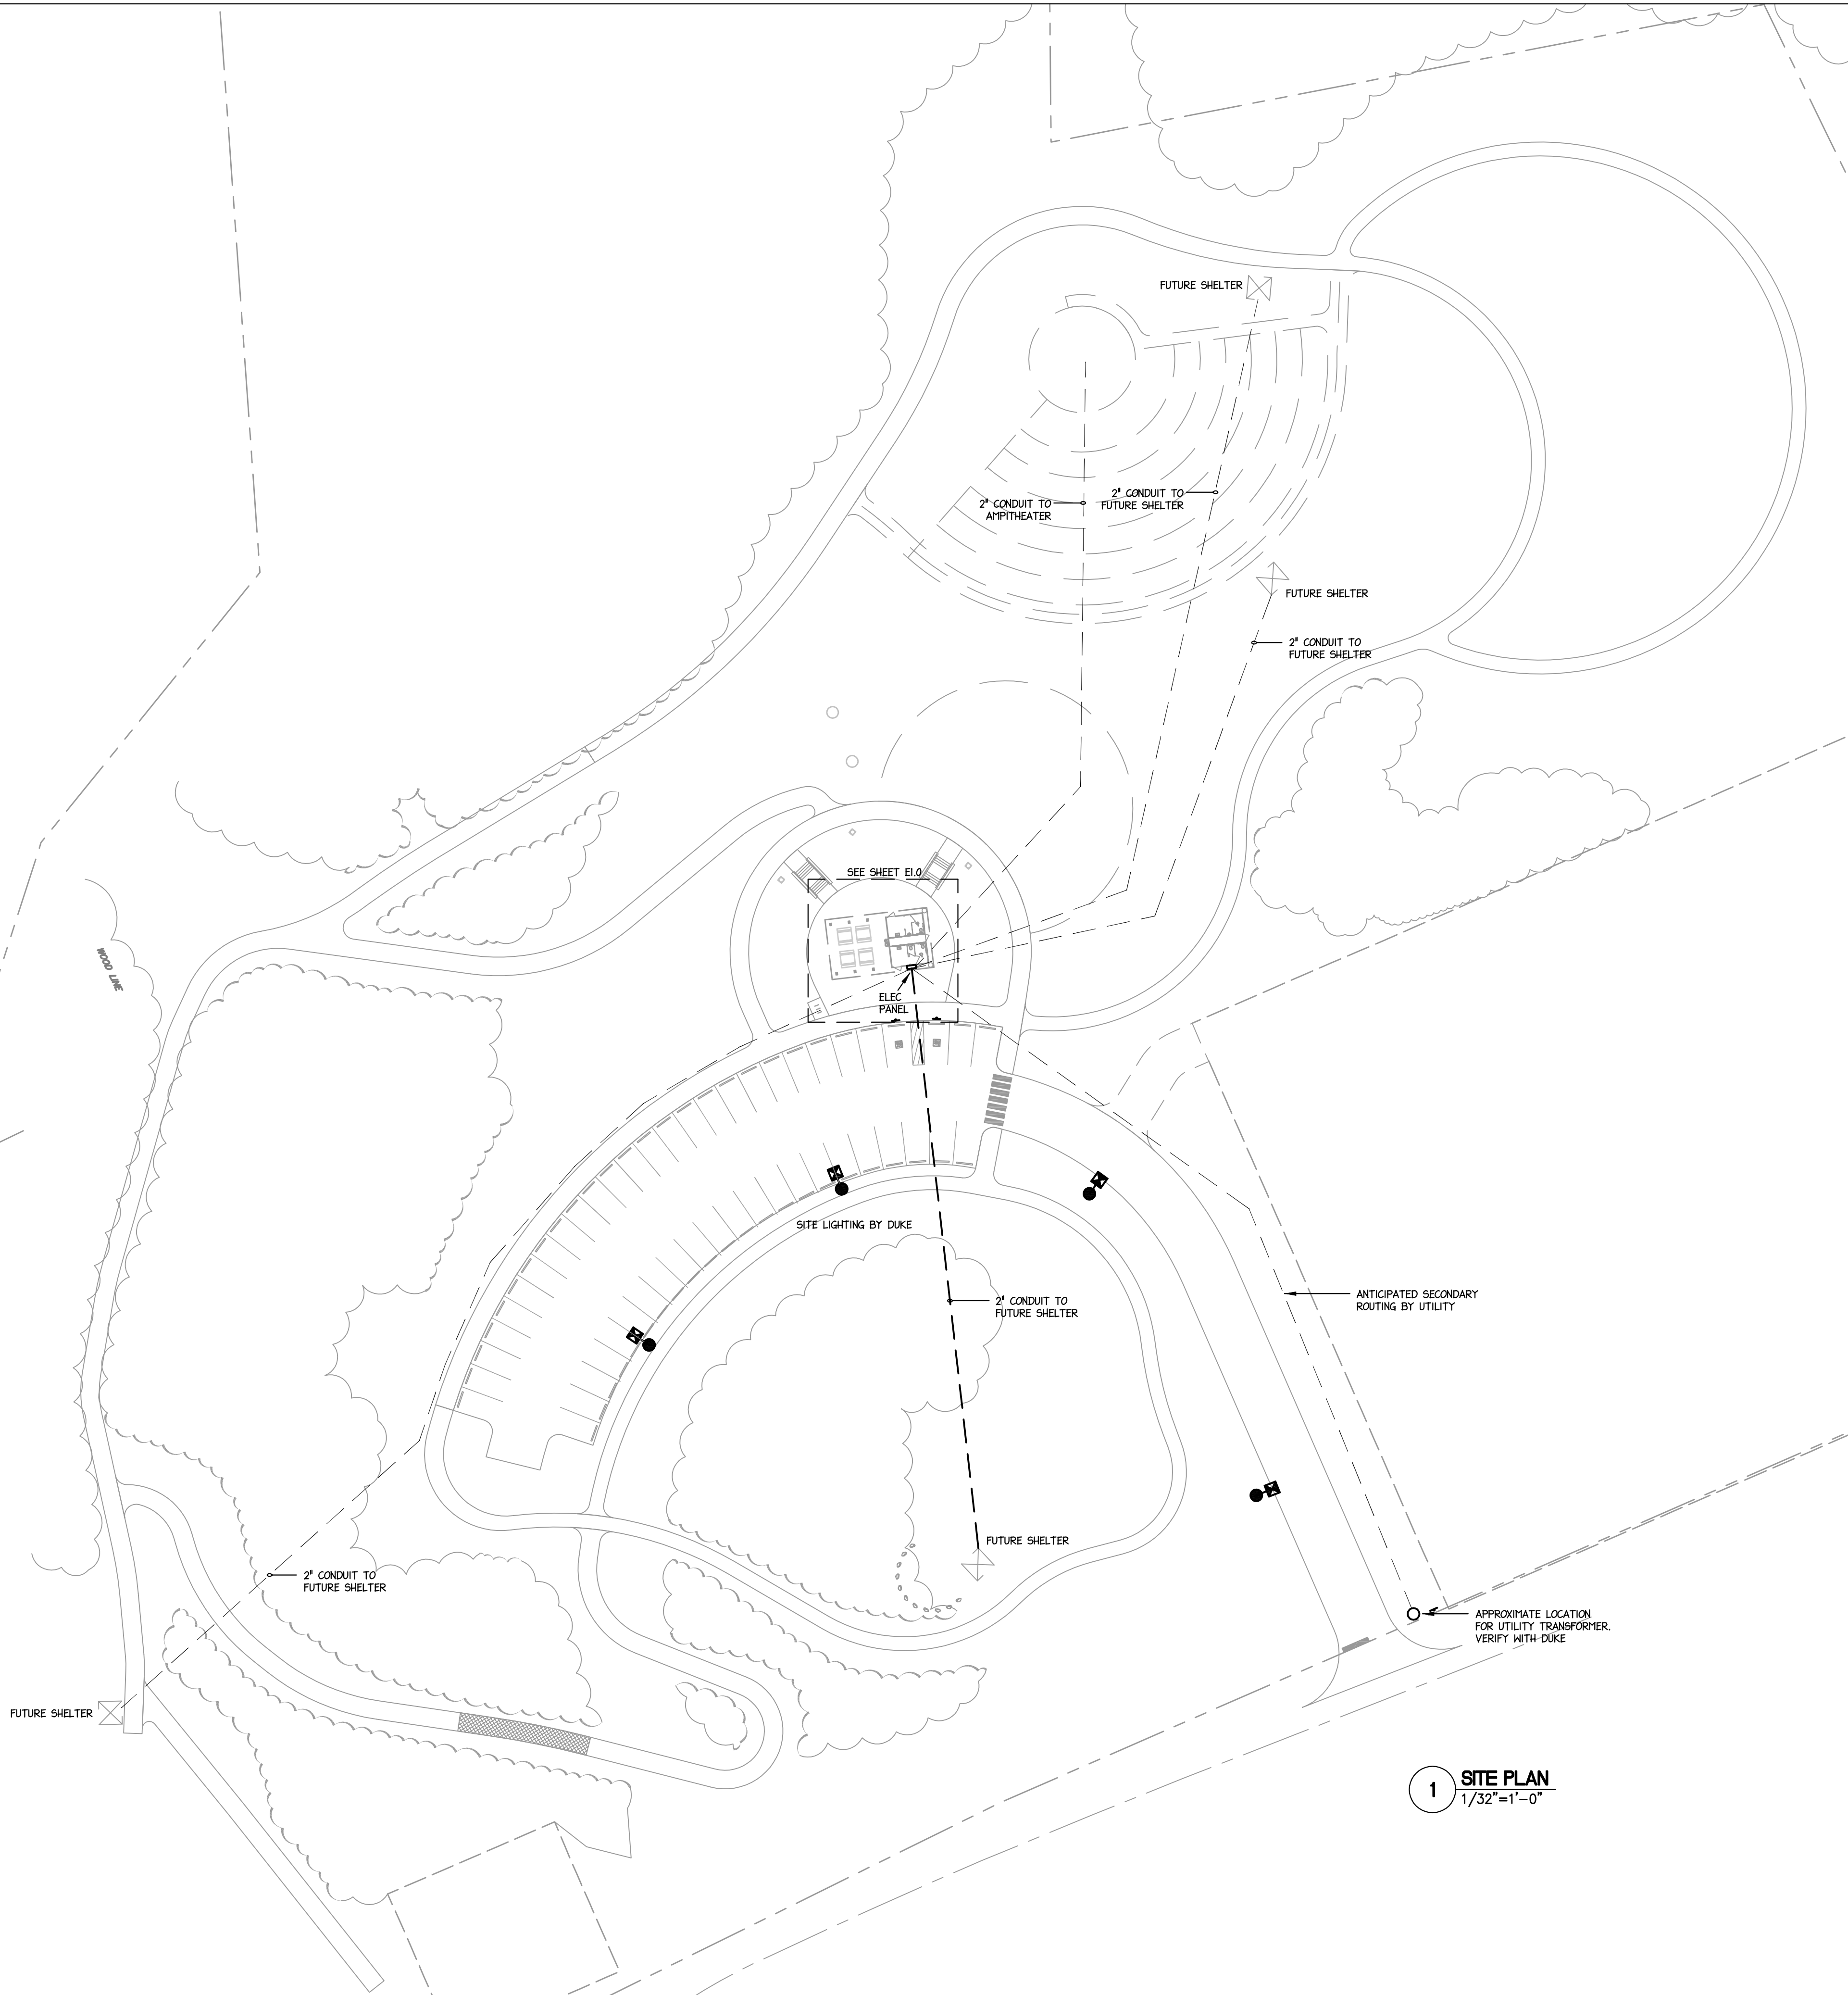

1 SITE PLAN
1/32"=1'-0"

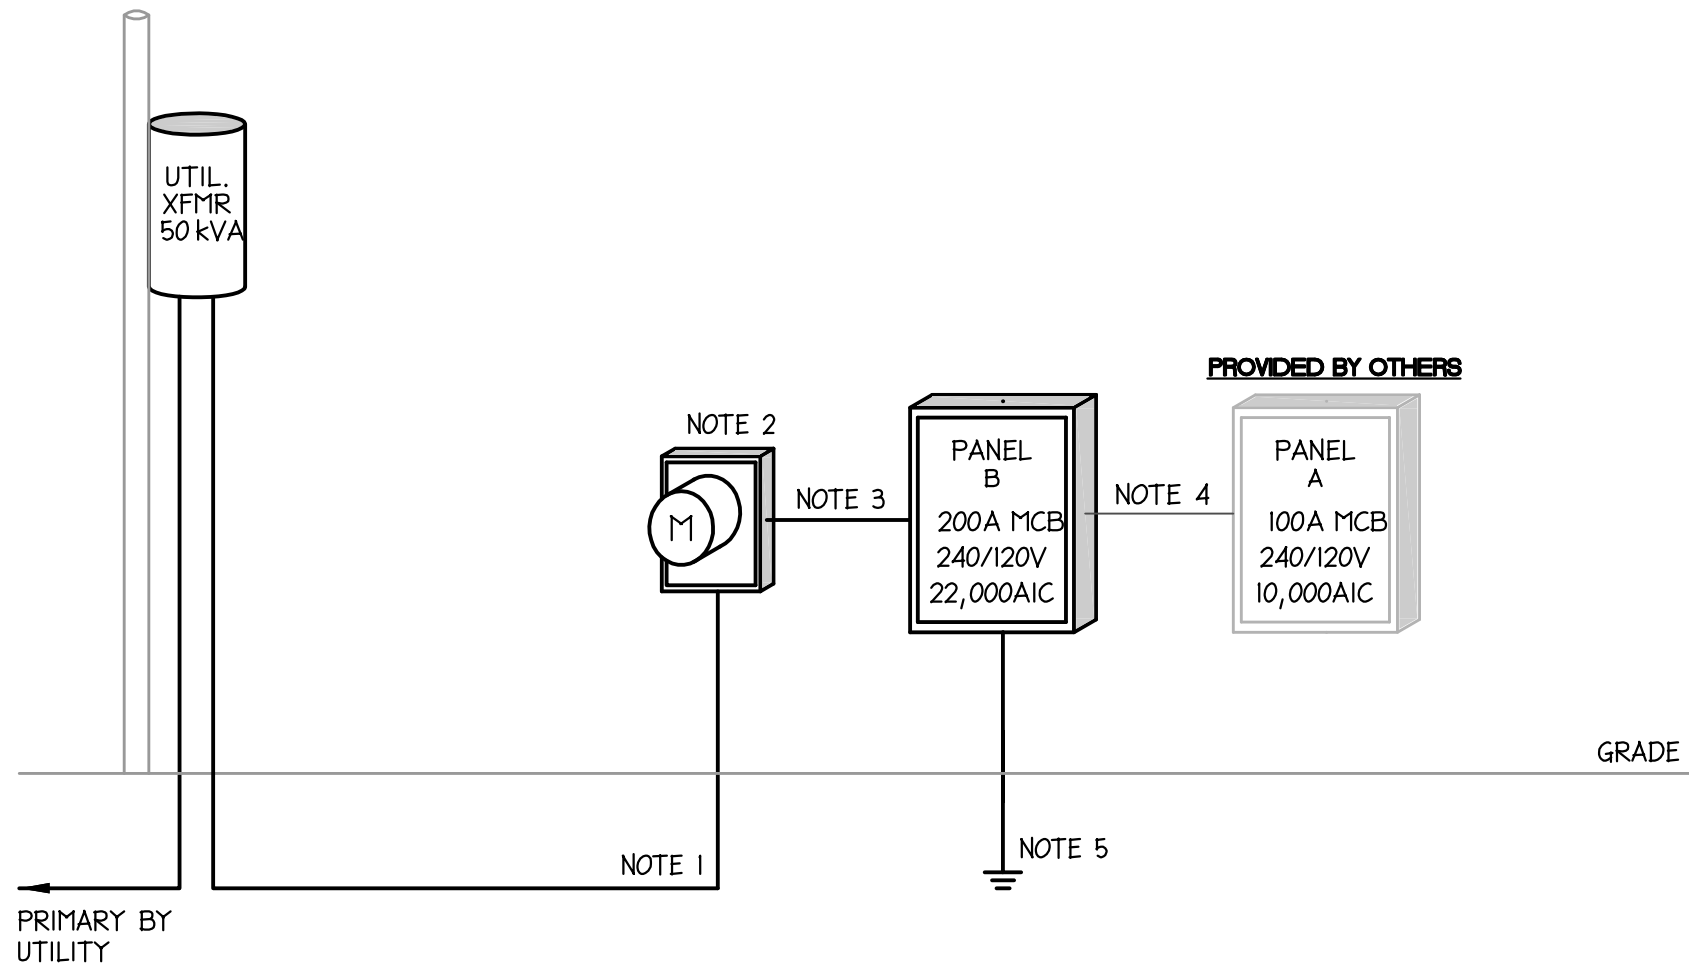

2 RESTROOM RISER DIAGRAM

DIAGRAMATIC ONLY

RISER DIAGRAM NOTES:

- SERVICE LATERAL CONDUCTORS TO METER PROVIDED AND INSTALLED BY UTILITY. COORDINATE FOR TRENCHING AND CONDUIT REQUIREMENTS.
- METER BASE PROVIDED AND INSTALLED BY ELECTRICAL CONTRACTOR, TO UTILITY REQUIREMENTS. METER PROVIDED AND INSTALLED BY UTILITY. MOUNT METER AT THE MINIMUM HEIGHT ABOVE FINAL GRADE. COORDINATE REQUIREMENTS WITH UTILITY.
- 3#250 KCM (AL), IN 2½" CONDUIT.
- 3#3 (AL), IN 1" CONDUIT.
- GROUNDING ELECTRODE CONDUCTOR SHALL BE #8 (CU) BONDED TO BUILDING STEEL (IF ANY), SLAB REINFORCING BARS (CONCRETE ENCASED ELECTRODE) AND DRIVEN GROUND ROD, SEE I/ED01.

PROVIDED BY OTHERS


EXISTING												1 PHASE 3 WIRE SURFACE MOUNTED NEMA 3R											
VOLTAGE: 240/120V AMPS: 100 - MCB												NEW											
PANEL: A												PANEL: B											
LOAD PER PHASE												LOAD PER PHASE											
- DESCRIPTION -	WIRE SIZE	BK SIZE	CT #	A	B	CT #	BK SIZE	WIRE SIZE	WIRE SIZE	- DESCRIPTION -	WIRE SIZE	BK SIZE	CT #	A	B	CT #	BK SIZE	WIRE SIZE	WIRE SIZE	- DESCRIPTION -	WIRE SIZE	BK SIZE	CT #
RECEPTACLE	12	20	1	0.5	0.9	2	20	12	1	LIGHTS	12	20	1	0.3	0.1	2	20	12	1	EXT. LIGHTING	12	20	1
SPACE	1	-	3	-	-	4	20	12	1	INSTA-HOT	1	-	3	-	-	4	20	12	1	EXT. RECEPTACLE	1	-	3
SPACE	1	-	5	-	-	6	20	12	1	INSTA-HOT	1	-	5	-	-	6	20	12	1	LTS: FUTURE SHELTER	1	-	5
SPACE	1	-	7	-	-	8	-	-	1	SPACE	1	-	7	-	-	8	-	-	1	REC: FUTURE SHELTER	1	-	7
SPACE	1	-	9	-	-	10	-	-	1	SPACE	1	-	9	-	-	10	-	-	1	LTS: FUTURE SHELTER	1	-	9
SPACE	1	-	11	-	-	12	-	-	1	SPACE	1	-	11	-	-	12	-	-	1	REC: FUTURE SHELTER	1	-	11
SPACE	1	-	13	-	-	14	-	-	1	SPACE	1	-	13	-	-	14	-	-	1	LTS: FUTURE SHELTER	1	-	13
SPACE	1	-	15	-	-	16	-	-	1	SPACE	1	-	15	-	-	16	-	-	1	REC: FUTURE SHELTER	1	-	15
SPACE	1	-	17	-	-	18	-	-	1	SPACE	1	-	17	-	-	18	-	-	1	SPACE	1	-	17
SPACE	1	-	19	-	-	20	-	-	1	SPACE	1	-	19	-	-	20	-	-	1	SPACE	1	-	19
SPACE	1	-	21	-	-	22	-	-	1	SPACE	1	-	21	-	-	22	-	-	1	SPACE	1	-	21
SPACE	1	-	23	-	-	24	-	-	1	SPACE	1	-	23	-	-	24	-	-	1	SPACE	1	-	23
SPACE	1	-	25	-	-	26	-	-	1	SPACE	1	-	25	-	-	26	-	-	1	SPACE	1	-	25
SPACE	1	-	27	-	-	28	-	-	1	SPACE	1	-	27	-	-	28	-	-	1	SPACE	1	-	27
SPACE	1	-	29	-	-	30	-	-	1	SPACE	1	-	29	-	-	30	-	-	1	SPACE	1	-	29
SPACE	1	-	31	-	-	32	-	-	1	SPACE	1	-	31	-	-	32	-	-	1	SPACE	1	-	31
SPACE	1	-	33	-	-	34	-	-	1	SPACE	1	-	33	-	-	34	-	-	1	SPACE	1	-	33
SPACE	1	-	35	-	-	36	-	-	1	SPACE	1	-	35	-	-	36	-	-	1	SPACE	1	-	35
SPACE	1	-	37	-	-	38	-	-	1	SPACE	1	-	37	-	-	38	-	-	1	SPACE	1	-	37
SPACE	1	-	39	-	-	40	-	-	1	SPACE	1	-	39	-	-	40	-	-	1	SPACE	1	-	39
SPACE	1	-	41	-	-	42	-	-	1	SPACE	1	-	41	-	-	42	-	-	1	SPACE	1	-	41
TOTAL CONNECTED KVA												TOTAL CONNECTED KVA											
PANEL RMS SYM. AMPS: SEE RISER												PANEL RMS SYM. AMPS: SEE RISER											
DEMAND KVA: 6.4												DEMAND KVA: 9.4											
DEMAND AMPS: 27												DEMAND AMPS: 39											

PANEL "A" LOAD SUMMARY			
LOAD TYPE	KVA CONN	DEM FACT	KVA DEM
LOADS ON 100AMP MCB			
LIGHTS	0.9	1.25	1.1
RECEPTACLES	IST 10kVA	0.5	1.0
	REMAINDER	-	0.5
WATER HEATER	4.8	1.0	4.8
TOTALS	6.2		6.4
TOTAL AMPS @ 240V 1Ø	26.7		

VOLTAGE: 240/120V AMPS: 200 - MCB												NEW PANEL: B												1 PHASE 3 WIRE SURFACE MOUNTED NEMA 3R											
- DESCRIPTION -												LOAD PER PHASE												- DESCRIPTION -											
	WIRE SIZE	BK SIZE	CT #	A	B	CT #	WIRE SIZE	BK SIZE	CT #		WIRE SIZE	BK SIZE	CT #	A	B	CT #	WIRE SIZE	BK SIZE	CT #		WIRE SIZE	BK SIZE	CT #												
SITE LIGHTING	12	20	1	0.3	0.1	2	20	12	1	EXT. LIGHTING	12	20	1	0.3	0.1	2	20	12	1	EXT. LIGHTING	12	20	1												
EQ: EWC	12	20	3		0.8 / 0.4	4	20	12	1	EXT. RECEPTACLE	12	20	3		0.8 / 0.4	4	20	12	1	EXT. RECEPTACLE	12	20	3												
LTS: FUTURE SHELTER	2	12	20	5	0.1 / 0.1	6	20	12	2	LTS: FUTURE SHELTER	2	12	20	5	0.1 / 0.1	6	20	12	2	LTS: FUTURE SHELTER	2	12	20												
REC: FUTURE SHELTER			7		0.2 / 0.2	8				REC: FUTURE SHELTER			7		0.2 / 0.2	8				REC: FUTURE SHELTER			7												
LTS: FUTURE SHELTER	2	12	20	9	0.1 / 0.1	10	20	12	2	LTS: FUTURE SHELTER	2	12	20	9	0.1 / 0.1	10	20	12	2	LTS: FUTURE SHELTER	2	12	20												
REC: FUTURE SHELTER			11		0.2 / 0.2	12				REC: FUTURE SHELTER			11		0.2 / 0.2	12				REC: FUTURE SHELTER			11												
SPARE	1	-	20	B	- / -	14	20	-	1	SPARE	1	-	20	B	- / -	14	20	-	1	SPARE	1	-	20												
SPARE	1	-	20	B	- / -	16	20	-	1	SPARE	1	-	20	B	- / -	16	20	-	1	SPARE	1	-	20												
SPARE	1	-	20	B	- / -	18	20	-	1	SPARE	1	-	20	B	- / -	18	20	-	1	SPARE	1	-	20												
SPARE	1	-	20	B	- / -	20	20	-	1	SPARE	1	-	20	B	- / -	20	20	-	1	SPARE	1	-	20												
SPACE	1	-	-	21	- / -	22	-	-	1	SPACE	1	-	-	21	- / -	22	-	-	1	SPACE	1	-	-												
SPACE	1	-	-	23	- / -	24	-	-	1	SPACE	1	-	-	23	- / -	24	-	-	1	SPACE	1	-	-												
SPACE	1	-	-	25	- / -	26	-	-	1	SPACE	1	-	-	25	- / -	26	-	-	1	SPACE	1	-	-												
SPACE	1	-	-	27	- / -	28	-	-	1	SPACE	1	-	-	27	- / -	28	-	-	1	SPACE	1	-	-												
SPACE	1	-	-	29	- / -	30	-	-	1	SPACE	1	-	-	29	- / -	30	-	-	1	SPACE	1	-	-												
SPACE	1	-	-	31	- / -	32	-	-	1	SPACE	1	-	-	31	- / -	32	-	-	1	SPACE	1	-	-												
SPACE	1	-	-	33	- / -	34	-	-	1	SPACE	1	-	-	33	- / -	34	-	-	1	SPACE	1	-	-												
SPACE	1	-	-	35	- / -	36	-	-	1	SPACE	1	-	-	35	- / -	36	-	-	1	SPACE	1	-	-												
SPACE	1	-	-	37	- / -	38	-	-	1	SPACE	1	-	-	37	- / -	38	-	-	1	SPACE	1	-	-												
SPACE	1	-	-	39	- / -	40	100	#	2	PANEL A	1	-	-	39	- / -	40	100	#	2	PANEL A	1	-	-												
SPACE	1	-	-	41	- / -	42					1	-	-	41	- / -	42					1	-	-												
TOTAL CONNECTED KVA												TOTAL CONNECTED KVA												DEMAND KVA: 9.4											
PANEL RMS SYM. AMPS: SEE RISER												PANEL RMS SYM. AMPS: SEE RISER												DEMAND AMPS: 39											

- PANEL SHALL BE SERVICE ENTRANCE RATED, EQUAL TO SIEMENS PI PANELBOARD.
- ATC - CIRCUIT THROUGH 24-HR, 7-DAY, MULTI-POLE ASTRONOMICAL TIMECLOCK. LOCATE TIMECLOCK ADJACENT TO PANEL.
- GFI - PROVIDE GFI BREAKER FOR CIRCUIT. GFI RECEPTACLES MAY BE USED IN LIEU OF GFI BREAKERS SO LONG AS THE DEVICE(S) CONFORM TO NEC CODE REQUIREMENTS FOR GFI PROTECTION.

PANEL "B" LOAD SUMMARY			
LOAD TYPE	KVA CONN	DEM FACT	KVA DEM
LOADS ON 200AMP MCB			
LIGHTS	1.7	1.25	2.1
RECEPTACLES	IST 10kVA	1.7	1.0
	REMAINDER	-	0.5
WATER HEATER	4.8	1.0	4.8
EQUIPMENT	0.8	1.0	0.8
TOTALS	9.0		9.4
TOTAL AMPS @ 240V 1Ø	39.2		

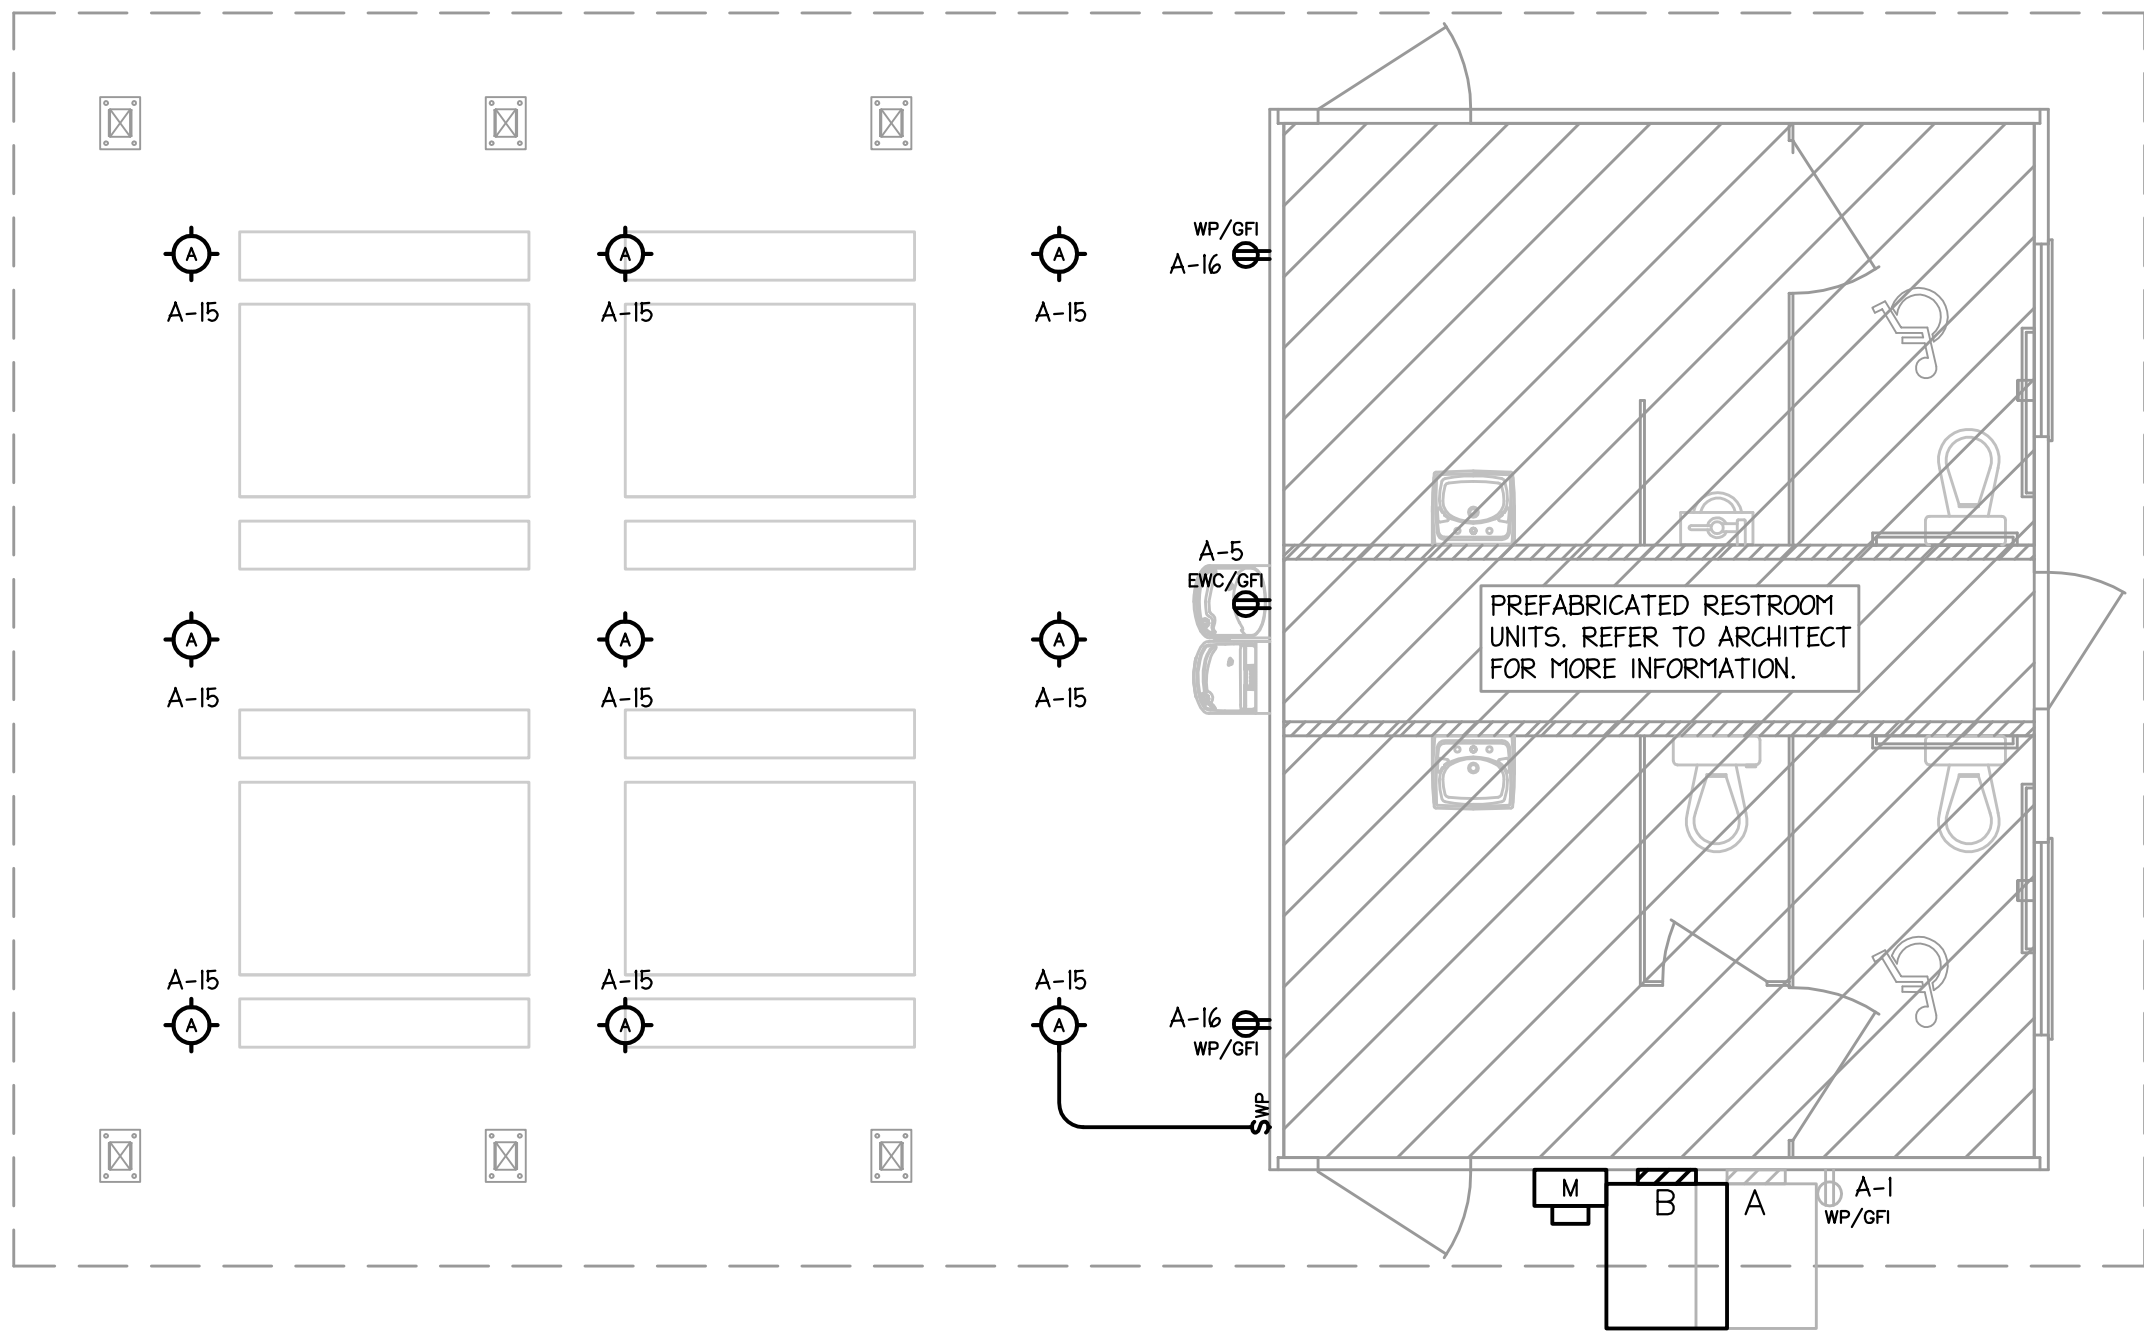

1 RESTROOM FLOOR PLAN

1/4"=1'-0"

GENERAL NOTES: (THIS SHEET)

- FAINT ITEMS ARE PROVIDED BY OTHERS.